

# 1860 SKY

## 40' EXPLORATION SERIES

40' X 61'-4"

REVISION SCHEDULE			
NO.	DATE	DESCRIPTION	BY
▲	09-11-25	-CREATED NEW MASTER	MR



**SHEET INDEX:**

- 00 COVER SHEET
- 00.1 GENERAL NOTES
- 01.0 SLAB INTERFACE PLAN "A"
- 02.0 FLOOR PLAN W/ NOTES "A"
- 02.1 FLOOR PLAN W/ DIMENSIONS "A"
- 03.A EXTERIOR ELEVS.- FRONT/ REAR "A"
- 03.1A EXTERIOR ELEVS.- LEFT/ RIGHT "A"
- 04.0 ROOF PLAN
- E1 UTILITY PLAN "A"
- AD1 DETAILS
- 07.0 FOUNDATION PLAN "A"
- 08A.1 TRUSS LAYOUT "A"
- 09.1 PRECAST LINTEL LAYOUT "A"
- D1 TYPICAL STRUCTURAL DETAILS
- D2 TYPICAL STRUCTURAL DETAILS
- D3 TYPICAL STRUCTURAL DETAILS
- D4 TYPICAL STRUCTURAL DETAILS
- D5 TYPICAL STRUCTURAL DETAILS

**SHEET INDEX:**

- 00 COVER SHEET
- 00.1 GENERAL NOTES
- 01.0 SLAB INTERFACE PLAN "B"
- 02.0 FLOOR PLAN W/ NOTES "B"
- 02.1 FLOOR PLAN W/ DIMENSIONS "B"
- 03.B EXTERIOR ELEVS.- FRONT/ REAR "B"
- 03.1B EXTERIOR ELEVS.- LEFT/ RIGHT "B"
- 04.0 ROOF PLAN
- E1 UTILITY PLAN "B"
- AD1 DETAILS
- 07.0 FOUNDATION PLAN "B"
- 08B.1 TRUSS LAYOUT "B"
- 09.1 PRECAST LINTEL LAYOUT "B"
- D1 TYPICAL STRUCTURAL DETAILS
- D2 TYPICAL STRUCTURAL DETAILS
- D3 TYPICAL STRUCTURAL DETAILS
- D4 TYPICAL STRUCTURAL DETAILS
- D5 TYPICAL STRUCTURAL DETAILS

**SHEET INDEX:**

- 00 COVER SHEET
- 00.1 GENERAL NOTES
- 01.0 SLAB INTERFACE PLAN "C"
- 02.0 FLOOR PLAN W/ NOTES "C"
- 02.1 FLOOR PLAN W/ DIMENSIONS "C"
- 03.C EXTERIOR ELEVS.- FRONT/ REAR "C"
- 03.1C EXTERIOR ELEVS.- LEFT/ RIGHT "C"
- 04.0 ROOF PLAN
- E1 UTILITY PLAN "C"
- AD1 DETAILS
- 07.0 FOUNDATION PLAN "C"
- 08C.1 TRUSS LAYOUT "C"
- 09.1 PRECAST LINTEL LAYOUT "C"
- D1 TYPICAL STRUCTURAL DETAILS
- D2 TYPICAL STRUCTURAL DETAILS
- D3 TYPICAL STRUCTURAL DETAILS
- D4 TYPICAL STRUCTURAL DETAILS
- D5 TYPICAL STRUCTURAL DETAILS

THIS STRUCTURE IS DESIGNED IN ACCORDANCE WITH THE 2018 EDITION, 2023 OF THE FLORIDA BUILDING CODE-RESIDENTIAL AND IS CERTIFIED AS SUCH

LOT: 0000, COMMUNITY

PARK SQUARE HOMES RESERVES COPYRIGHT & OTHER RIGHTS RESTRICTING THESE DOCUMENTS TO THE ORIGINAL SITE OR PURPOSE FOR WHICH THEY WERE PREPARED. REPRODUCTIONS, CHANGES OR ASSIGNMENTS ARE PROHIBITED.

1860 SKY

40' EXPLORATION SERIES

COVER SHEET

REVISIONS

DELTA #	DATE

DATE: 09-11-25

SCALE: AS NOTED

DRAWN: MR

SHEET: 00

**ITEG**  
THOMPSON ENGINEERING GROUP, INC.  
4407 Vineyard Road Suite A8 Orlando, FL 32811  
Phone: (407) 244-1790  
www.iteg.com

**Park Square HOMES**  
A DIVISION OF PARK SQUARE ENTERPRISES, INC.  
5200 Vineyard Road, Suite 200  
Orlando, Florida 32811  
Phone: (407) 529 - 3000

**ABBREVIATIONS:**

A/C	AIR CONDITIONER
AFF	ABOVE FINISHED FLOOR
A.H.U.	AIR HANDLER UNIT
ALT.	ALTERNATE
ALUM.	ALUMINUM
BRG.	BEARING
CAB.	CABINET
C.A.N.T.	CANTILEVER
C.	CENTER LINE
C.L.G.	CEILING
C.J.	CONTROL JOINT
CMU	CONCRETE MASONRY UNIT
CONT.	CONTINUOUS
CPT.	CARPET
D.	DRYER SPACE
D.H.	DOUBLE HUNG
DIA.	DIAMETER
DISP.	DISPOSAL
D.V.	DRYER VENT
DW	DISHWASHER
E.H.	EACH
ELEC	ELECTRICAL
ELEV	ELEVATION
E.O.R.	ENGINEER OF RECORD
E.W.	EACH WAY
FBC	FLORIDA BUILDING CODE
FBC(B)	FLORIDA BUILDING CODE, BUILDING
FBC(E)	FLORIDA BUILDING CODE, ENERGY CONSERVATION
FBC(M)	FLORIDA BUILDING CODE, MECHANICAL
FBC(P)	FLORIDA BUILDING CODE, PLUMBING
FBC(R)	FLORIDA BUILDING CODE, RESIDENTIAL
F.F.E.	FINISHED FLOOR ELEVATION
F.G.	FIXED GLASS
FLR.	FLOOR
FR	FIRE RATED
F.T.	FOOT / FEET
FTG.	FOOTING
F.V.	FIELD VERIFY
GALV.	GALVANIZED
G.C.	GENERAL CONTRACTOR
GFCI	GROUND FAULT CIRCUIT INTERRUPTER
GFI	GROUND FAULT INTERRUPTER
G.T.	GIRDER TRUSS
GYP	GYP SUM
HDR.	HEADER
HGT.	HEIGHT
H.B.	HOSE BIB
HORIZ.	HORIZONTAL
H.S.	HARD SURFACE
IL.	ICEMAKER LINE
IL.Ø.	IN LIEU OF
INT.	INTERIOR
L.A.	LAUNDRY TUB
LOC.	LOCATION
MAX.	MAXIMUM
M. CA.	MEDICINE CABINET
MECH.	MECHANICAL
MIN.	MINIMUM
MONO.	MONOLITHIC
MPH	MILES PER HOUR
NO.	NUMBER
N.T.S.	NOT TO SCALE
O.C.	ON CENTER
O.H.C.	OVERHEAD CABINETS
O.H.GD	OVERHEAD GARAGE DOOR
OPT.	OPTIONAL
FED.	PEDESTAL SINK
PLF	POUNDS PER LINEAR FOOT
PLT. HGT.	PLATE HEIGHT
PSF	POUNDS PER SQUARE FOOT
P.T.	PRESSURE TREATED
PWR	POWER
REF. SP.	REFRIGERATOR SPACE
REQ'D	REQUIRED
RM.	ROOM
RO.	ROUGH OPENING
R/S	ROD AND SHELF
SC	SOLID CORE
SGD	SLIDING GLASS DOOR
SH	SINGLE HUNG
SIM.	SIMILAR
SFF	SPRUE PINE FUR
SQ. FT.	SQUARE FOOT/ FEET
SUB	SUB-CONTRACTOR
SYF	SOUTHERN YELLOW PINE
TEMP.	TEMPERED
T.M.	TOP OF MASONRY
T.W.	TOP OF WALL
TRANS.	TRANSOM
TYP.	TYPICAL
U.N.O.	UNLESS NOTED OTHERWISE
VERT.	VERTICAL
V.A.	VAPOR PROOF
VTR	VENT THRU ROOF
W.	WITH
W.C.	WATER CLOSET
W.	WASHER SPACE
W.H.	WATER HEATER
WP	WEATHER PROOF
W.S.	WATER SOFTENER

PER FBC R301- TABLE R301.5		
GUARDRAILS & HANDRAILS	CONC. LOAD	200 LBS
GUARDRAIL IN-FILL COMPONENTS	CONC. LOAD	50 LBS
STAIRS	CONC. LOAD	300 LBS
PER FBC R312- R312.1.2 & R312.1.3 & R311.7.8.1		
GUARDRAILS HEIGHT		36" MIN.
HANDRAIL HEIGHT		34" MIN. TO 38" MAX.
GUARDRAIL OPENING LIMITATIONS		4" IN DIAMETER MAX.
EERO- R310.2.1- FBCR2023		
SH25	NET CLEAR OPNG. HEIGHT 32" X NET CLEAR OPNG. WIDTH 21 1/2" = 6.119 SQFT	NET CLEAR OPNG OF NOT LESS THAN 5.7 SQFT MIN. NET CLEAR OPNG. HEIGHT DIMENSION SHALL BE 24". THE MIN. NET CLEAR OPNG. WIDTH DIMENSION SHALL BE 20". MIN. NET CLEAR OPNG. FOR GRADE-FLOOR EMERGENCY ESCAPE & RESCUE OPNG. SHALL BE - 5 SQFT
SH25	63" H. X 31" W. UDW SIZE	

**THE ANSI STANDARD FOR MEASURING HOUSES:**

NATIONAL STANDARD Z165-1936 NEW CONSTRUCTION THE ANSI STANDARDS BASE FLOOR AREA CALCULATIONS ON THE EXTERIOR DIMENSIONS OF THE BUILDING AT EACH FLOOR LEVEL & INCLUDE ALL INTERIOR WALLS & VOIDS. FOR ATTACHED UNITS, THE OUTSIDE DIMENSION IS THE CENTER LINE OF THE COMMON WALLS. INTERNAL ROOM DIMENSIONS AREN'T USED IN THIS SYSTEM OF MEASURING. THE ANSI STANDARDS BASE FLOOR AREA CALCULATIONS ON THE EXTERIOR DIMENSIONS OF THE BUILDING AT EACH FLOOR LEVEL & INCLUDE ALL INTERIOR WALLS & VOIDS. FOR ATTACHED UNITS, THE OUTSIDE DIMENSION IS THE CENTER LINE OF THE COMMON WALLS. INTERNAL ROOM DIMENSIONS AREN'T USED IN THIS SYSTEM OF MEASURING.

THE ANSI STANDARDS BASE FLOOR AREA CALCULATIONS ON THE EXTERIOR DIMENSIONS OF THE BUILDING AT EACH FLOOR LEVEL & INCLUDE ALL INTERIOR WALLS & VOIDS SEPARATED INTO TWO AREAS:

- AIR-CONDITIONED SPACE
- NON-AIR-CONDITIONED SPACE (GARAGES, PATIOS, PORCHES, BREEZEWAYS)

THE ANSI STANDARDS DEFINE "FINISHED AREA" AS AN ENCLOSED AREA IN A HOUSE SUITABLE FOR YEAR-ROUND USE, EMBODYING WALLS, FLOORS & CEILINGS THAT ARE LIKE THE REST OF THE MEASUREMENTS MUST BE TAKEN TO THE NEAREST INCH OR TENTH OF A FOOT, & FLOOR AREA MUST BE REPORTED TO THE NEAREST SQUARE FOOT. THESE WOULD INCLUDE BONUS/ATTIC SPACES & ARE USUALLY LISTED SEPARATELY.

**MISCELLANEOUS:**

- CONTRACTOR TO VERIFY ALL DIMENSIONS ON JOB SITE.
- DO NOT SCALE PRINTS! PLANS ARE TO SCALED AS NOTED, UNLESS SPECIFIED N.T.S. CONSTRUCTION TO BE FROM CALCULATED DIMENSIONS ONLY. ANY DISCREPANCIES OR ERRORS TO BE REPORTED PROMPTLY TO SUPERVISOR FOR CLARIFICATION.
- PULL ALL DIMENSIONS FROM THE REAR OF PLAN
- ALL FINISH FLOOR ELEVATIONS ARE TO TOP OF ROUGH SLAB OR TO TOP OF STRUCTURE UNO.
- ANCHOR THE CONDENSER UNIT TO SLAB PER CODE: M [307.1] - M1307.2
- IT IS THE RESPONSIBILITY OF THE GENERAL CONTRACTOR TO INSTALL ALL MATERIALS MEETING FLORIDA APPROVAL COMPLIANCE TO AVOID WATER INTRUSION & MOISTURE INTRUSION ON WINDOWS, DOORS, ROOF & ANY OTHER AREA AROUND EACH SINGLE FAMILY HOUSE/ APARTMENT/ CONDOMINIUM/ TOWNHOUSE.

**EXTERIOR WALLS:**

- ASSUME ALL EXTERIOR WALLS TO BE LOAD BEARING.
- SEE STRUCTURAL DRAWINGS FOR CMU WALL REINFORCEMENT LOCATIONS
- INTERIOR SURFACE OF CMU WALL TO HAVE 1/2" GPBD APPLIED TO 1X P.T. VERTICAL FURRING BATTS SPACED @ 16" O.C. ATTACH FURRING TO CONCRETE WALL AS REQUIRED.
- SECOND FLOOR EXTERIOR WALLS TO BE WOOD STUDS.
- REFER TO DETAIL SHEETS FOR FLASHING REQUIREMENTS AT ALL WOOD TO MASONRY INTERFACES
- REFER TO TYPICAL DETAIL SHEET FOR EXTERIOR WALL FINISH SPECIFICATIONS
- ALL EXTERIOR CEILING (PORCH & PATIOS) SHALL HAVE SAG-RESISTANT GYP SOFFIT BOARD.

**INTERIOR WALLS:**

- ALL INTERIOR WALLS SHALL HAVE STANDARD 1/2" GYP BD, EXCEPT IN HIGH HUMIDITY & WET AREAS.
- HIGH HUMIDITY & WET AREAS SHALL HAVE 1/2" DENS-SHIELD TILE BACKER GYPSUM BOARD.
- ALL INTERIOR CEILINGS SHALL HAVE PER FBCR 102.3.5 1/2" SAG-RESISTANT GYP BD. INSTALL PERPENDICULAR TO FRAMING.
- TILE IN TUBS, SHOWERS, & WALL PANELS IN SHOWER AREAS ARE TO HAVE CEMENT, FIBER-CEMENT, OR GLASS MAT GYPSUM BACKERS R102.3.7 / R102.4.2 2023 FBC-R 8TH EDITION.
- 2023 FBC-R 8TH EDITION TABLE R302.6: 5/8" TYPE 'X' GYPSUM BOARD OR EQUIVALENT IS REQUIRED FOR A GARAGE CEILING WITH HABITABLE ROOMS ABOVE. 1/2" MINIMUM GYPSUM BOARD IS REQUIRED ON GARAGE SIDE OF INTERIOR WALLS.
- ALL PLATES & SLEEPERS ON CONCRETE SLAB, WHICH ARE IN DIRECT CONTACT WITH THE EARTH, SHALL BE PRESSURE TREATED.
- ALL INTERIOR WALL PLATES, OTHER THAN SHEAR WALLS, ON CONC. SLAB TO BE ATTACHED W/ POWER ACTUATED FASTENERS, SPACED @ 48" O.C. MAX.
- ALL WOOD BRG. INTERIOR PARTITIONS SHALL BE 2X4 STUDS SPACED @ 16" O.C. WITH DOUBLE TOP PLATE, UNO.
- WOOD CONSTRUCTION SHALL CONFORM TO THE AMERICAN FOREST & PAPER ASSOCIATION (AF&PA) "NATIONAL SPECIFICATION FOR WOOD CONSTRUCTION", LATEST EDITION.

**MEANS OF EGRESS:**

- NOT LESS THAN ONE EGRESS DOOR SHALL BE PROVIDED IN EACH DWELLING UNIT. THE EGRESS DOOR SHALL BE SIDE-HINGED, & SHALL PROVIDE A CLEAR WIDTH OF NOT LESS THAN 32 INCHES WHERE MEASURED BETWEEN THE FACE OF THE DOOR & THE STOP, WITH THE DOOR OPEN 90 DEGREES. THE CLEAR HEIGHT OF THE DOOR OPENING SHALL BE NOT LESS THAN 78 INCHES IN HEIGHT MEASURED FROM THE TOP OF THE THRESHOLD TO THE BOTTOM OF THE STOP.
- RAMP SERVING EGRESS DOOR REQUIRED BY SECTION R311.2 SHALL HAVE A SLOPE OF NOT MORE THAN 1 UNIT VERTICAL IN 12 UNITS HORIZONTAL (8.3 % SLOPE). ALL OTHER RAMPS SHALL HAVE A MAXIMUM SLOPE OF 1 UNIT VERTICAL IN 8 UNITS HORIZONTAL (12.5% SLOPE)
- THE WIDTH OF A HALLWAY SHALL BE NOT LESS THAN 36 INCHES MEASURED FROM FINISHED MATERIALS.
- WINDOWS DESIGNATED AS EGRESS SHALL COMPLY WITH SECTION R310.2
- ALL EMERGENCY ESCAPE AND RESCUE OPENINGS SHALL HAVE THE BOTTOM OF THE CLEAR OPENING NOT MORE THAN 44" MIN. AFF. - R310.2 - FBC-R (2023)
- IN DWELLING UNITS, WHERE THE BOTTOM OF THE CLEAR OPENING OF AN OPERABLE WINDOW OPENING IS LOCATED LESS THAN 24" ABOVE FINISH FLOOR & GREATER THAN 12" FINISHED GRADE MUST COMPLY WITH FBCR 312.2

**TERMITE PROTECTION:**

- PENETRATION. PROTECTIVE SLEEVES AROUND PIPING PENETRATING CONCRETE SLAB-ON-GRADE FLOORS SHALL NOT BE OF CELLULOSE CONTAINING MATERIALS. IF SOIL TREATMENT IS USED FOR SUBTERRANEAN TERMITE PROTECTION, THE SLEEVE SHALL HAVE A MAXIMUM WALL THICKNESS OF 0.010 INCH, & BE SEALED WITHIN THE SLAB USING A NON-CORROSIVE CLAMPING DEVICE TO ELIMINATE THE ANNULAR SPACE BETWEEN THE PIPE & THE SLEEVE. NO TERMITICIDES SHALL BE APPLIED INSIDE THE SLEEVE.
- PROTECTION AGAINST DECAY & TERMITES. - CONDENSATE LINES, IRRIGATION SPRINKLER SYSTEM RISERS FOR SPRAY HEADS, & ROOF DOWNSPOUTS SHALL DISCHARGE AT LEAST 1 FOOT (305 MM) AWAY FROM THE STRUCTURE SIDEWALL, WHETHER BY UNDERGROUND PIPING, TAIL EXTENSIONS, OR SPLASH BLOCKS. GUTTERS WITH DOWNSPOUTS ARE REQUIRED ON ALL BUILDINGS WITH EAVES OF LESS THAN 6 INCHES (152 MM) HORIZONTAL PROJECTION EXCEPT FOR GABLE END RAKES OR ON A ROOF ABOVE ANOTHER ROOF.

**DOORS AND WINDOWS:**

- WINDOW & DOOR SUPPLIERS SHALL PROVIDE CURRENT ROUGH OPENING INFORMATION WHICH SHALL HAVE PRECEDENCE OVER THE WINDOW & DOOR SCHEDULES ON PLAN.
- CONTRACTOR & SUPPLIER TO VERIFY WINDOW LOCATION, TYPE (FIN VS. FLANGE) HEADER HEIGHTS, & ROUGH OPENINGS PRIOR TO DELIVERY.
- WINDOWS & DOORS SHALL BE INSTALLED IN ACCORDANCE WITH THE MANUFACTURER'S INSTALLATION INSTRUCTIONS
- ALL GLASS LOCATED IN HAZARDOUS LOCATIONS SHALL BE TEMPERED & COMPLY WITH SECTION R308 OF THE 2023 FBC-R 8TH EDITION.
- WINDOW CONTRACTOR TO VERIFY ROUGH OPENINGS OF ALL FIELD ASSEMBLED FIXED GLASS WINDOW UNITS PRIOR TO INSTALLATION.
- WINDOW ROUGH OPENING INCLUDES 1X P.T. FRAME ATTACHED TO CMU'S.
- DOOR ROUGH OPENING INCLUDES 2X P.T. FRAME ATTACHED TO CMU'S.
- ALL WINDOWS IN WIND BORN DEBRIS AREAS SHALL BE PROTECTED FROM WIND BORN DEBRIS. PROVIDE SHUTTERS CERTIFIED TO MEET MIAMI-DADE IMPACT TEST. SHUTTERS MUST BE ROLL-DOWN, PANEL ACCORDION OR OTHER APPROVED DESIGN TYPE. BUILDER TO SUBMIT MANUFACTURER, MODEL NO. INSTALLATION INSTRUCTIONS, & COPY OF MIAMI-DADE IMPACT TEST DATA FOR PROPOSED SHUTTERS.
- WINDOW & DOOR ASSEMBLIES TO CONFORM TO 2023 FBC-R CHAPTER 6, SECTION 609. INTERIOR FACE OF WINDOW, FASTEN BUCK TO MASONRY W/ 1/4" X 3" TAPCONS, 6" FROM EDGES & 16" O.C. MAX. 2X P.T. BUCKS/NAILERS SHALL EXTEND BEYOND.
- BUCKS LESS THAN 2X TO BE FASTENED W/ CUT NAILS OR EQUIVALENT. STRUCTURAL CONNECTION OF WINDOW TO STRUCTURE BY OTHERS IN THIS CASE.
- EXTERIOR WINDOWS & SLIDING DOORS SHALL BE TESTED & COMPLY WITH AAMA/WDMA/CSA 101/19.2/4440 OR TAS 202 (HVHZ SHALL COMPLY WITH TAS 202 AND ASTM E1300). EXTERIOR SIDE HINGED DOORS SHALL COMPLY WITH AAMA/WDMA/CSA 101/19.2/4440 OR ANSI/UMA100 OR SECTION R609.5 IN THE 2023 FBC-R.
- ALL GARAGE/OVERHEAD DOORS SHALL BE LISTED & TESTED FOR 30 SECONDS AT DESIGN PRESSURE (+/-) TO INCLUDE A 10 SECOND GUST AT 15 TIMES THE DESIGN PRESSURE.

**ROOFING:**

- THE ROOF PLAN DEPICTED IS NOT INTENDED TO SERVE AS A TRUSS DESIGN.
- SEE BUILDING SECTIONS, WALL SECTIONS & ELEVATIONS FOR BEARING HEIGHTS
- 12' OVERHANG UNO/ PLUMB CUT FASCIA/ ROOF PITCH PER ELEVATION/ SHINGLES UNO.
- FLASHING SHALL BE INSTALLED AT WALL & ROOF INTERSECTIONS, AT GUTTERS, AT ALL CHANGES IN ROOF SLOPE OR DIRECTION, & AROUND ROOF OPENINGS.
- STEP FLASHING SHALL BE USED ON ALL ROOF TO WALL INTERSECTIONS ON RAKES.
- ALL PENETRATIONS THROUGH ROOF ARE TO BE LOCATED ON REAR OR IF NECESSARY ON THE SIDE OF THE ROOF BEHIND THE FRONT FACADE ZONE.
- CLAY & CONCRETE TILE (IF APPLICABLE):
  - PER FBC-R 2023 8TH EDITION R305.3, THE INSTALLATION OF CLAY AND CONCRETE TILE SHALL BE IN ACCORDANCE WITH THE MANUFACTURER'S INSTALLATION INSTRUCTIONS, OR RECOMMENDATIONS OF FRSA/TRI FLORIDA HIGH WIND CONCRETE & CLAY ROOF TILE INSTALLATION MANUAL, LATEST EDITION, WHERE THE VASD IS DETERMINED IN ACCORDANCE WITH SECTION R301.2.1.3.
  - UNLESS OTHERWISE NOTED, REQUIRED UNDERLAYMENT SHALL COMPLY WITH THE UNDERLAYMENT MANUFACTURER'S INSTALLATION INSTRUCTIONS IN ACCORDANCE WITH THE FRSA/TRI FLORIDA HIGH WIND CONCRETE & CLAY ROOF TILE INSTALLATION MANUAL, LATEST EDITION, WHERE THE VASD IS DETERMINED IN ACCORDANCE WITH SECTION R301.2.1.3.
  - ASPHALT SHINGLES (IF APPLICABLE):
    - WIND RESISTANCE OF ASPHALT SHINGLES. - ASPHALT SHINGLES SHALL BE INSTALLED IN ACCORDANCE WITH 2023 FBC-R (8TH EDITION), SECTION R305.2.6 AND R305.2.6.1.
    - ASPHALT SHINGLES SHALL ONLY BE USED ON ROOF SLOPES OF TWO UNITS VERTICAL IN 12 UNITS HORIZONTAL (2:12) OR GREATER. FOR ROOF SLOPES FROM TWO UNITS VERTICAL IN 12 UNITS HORIZONTAL (2:12) & LESS THAN FOUR UNITS VERTICAL IN 12 UNITS HORIZONTAL (4:12), TWO LAYERS OF UNDERLAYMENT COMPLYING WITH ASTM D226, TYPE II, ASTM D4869, TYPE III OR TYPE IV OR ASTM D8251 IS REQUIRED IN ACCORDANCE WITH SECTION R305.11. FOR ROOF SLOPES FROM FOUR UNITS VERTICAL IN 12 UNITS HORIZONTAL (4:12) & GREATER, ONE LAYER OF UNDERLAYMENT COMPLYING WITH ASTM D226, TYPE II, ASTM D4869, TYPE III OR IV OR ASTM D8251 IS REQUIRED IN ACCORDANCE WITH SECTION R305.11.
    - AS AN ALTERNATIVE, THE ENTIRE ROOF DECK SHALL BE COVERED WITH AN APPROVED SELF-ADHERING POLYMER MODIFIED BITUMEN UNDERLAYMENT COMPLYING WITH ASTM D1910 INSTALLED IN ACCORDANCE WITH BOTH THE UNDERLAYMENT MANUFACTURER'S & ROOF COVERING MANUFACTURER'S INSTALLATION INSTRUCTIONS FOR THE DECK MATERIAL, ROOF VENTILATION CONFIGURATION & CLIMATE EXPOSURE FOR THE ROOF COVERING TO BE INSTALLED. REFER TO R305.11.1.

**INSULATION:**

- INSULATE ALL EXTERIOR FRAME WALLS WITH R-13 BATT FIBERGLASS INSULATION.
- INSULATE CONDITIONED ATTIC SPACE WITH R-30 BLOWN FIBERGLASS. INACCESSIBLE ATTIC SPACE SHALL RECEIVE R-30 BATT INSULATION.
- INSULATE ALL CMU WALLS (THAT REQUIRE 1" P.T. FURRING STRIPS) WITH R41 FI-FOIL PANELS.
- APPLY HILT! FOAM FILLER AT EXTERIOR WALLS AROUND: WINDOW FRAMES, EXTERIOR DOOR FRAMES, GAPS AROUND PIPES, VENTS, OUTLETS, ETC.
- INSULATE ALL ATTIC KNEE WALLS WITH R-38 BATTS.
- APPLY OWENS CORNING ENERGY COMPLETE TO THE TOP OF ALL CONDITIONED SPACE WALLS THAT INTERACT WITH UNCONDITIONED ATTIC SPACE ABOVE.

**CABINETS:**

- CABINET MANUFACTURE'S SHOP DRAWINGS TAKE PRECEDENCE OVER THE INTERIOR CABINET ELEVATIONS SHOWN ON THESE DRAWINGS.
- SEE SUPPLIER / MFR'S DRAWINGS FOR KITCHEN, CABBINTRY/MILLWORK & RESTROOM LAYOUTS.

**PLUMBING:**

- PLUMBING CONTRACTOR SHALL BE RESPONSIBLE TO PROPERLY SIZE, DESIGN, & INSTALL ALL PLUMBING SYSTEM COMPONENTS BY THE TERMS OF THEIR APPROVAL, IN ACCORDANCE WITH THE CONDITIONS OF THE LISTING, & PER THE CURRENT EDITION OF THE FBC(P), THE FBC(R), THE FBC, OR AS APPLICABLE.
- PROVIDE RECESS HOT & COLD WATER WITH DRAIN @ WASHER SPACE.
- PROVIDE COLD WATER LINE FOR ICE MAKER LINE @ REF. SPACE.
- VENT DRYER THRU ROOF, NO VENT STACKS SHALL PENETRATE THROUGH ROOF CRICKETS, VALLEYS, OR RIDGES. BUILDER SHALL VERIFY & APPROVE ALL LOCATIONS.

**ELECTRICAL:**

- IAW NEC 2020- 210.12- ALL 15A OR 20A, 120V BRANCH CIRCUITS SUPPLYING OUTLETS OR DEVICES IN THE FOLLOWING LOCATIONS REQUIRE AFCI PROTECTION- KITCHEN, FAMILY RMS, DINING RMS, LIVING RMS, PARLORS, LIBRARIES, BEDROOMS, DENS, CLOSETS, SUNROOMS, RECREATION RMS, HALLWAYS OR SIMILAR AREAS SHALL BE PROTECTED BY A LISTED AFCI DEVICE OF THE COMBINATION TYPE.
- IAW NEC 2020- 406.12, ALL 15A AND 20A, 125V RECEPTACLES SHALL BE LISTED AS TAMPER RESISTANT.
- ALL SERVICES SUPPLYING DWELLING UNITS SHALL BE PROVIDED WITH A SURGE-PROTECTION DEVICE (SPD). THE SPD SHALL BE A TYPE (1) OR TYPE (2) SPD.
- ALL OUTLETS IN BATHROOMS, KITCHEN, GARAGES & LAUNDRY ROOM SHALL BE GFCI
- SMOKE ALARMS SHALL BE IN ALL SLEEPING AREAS, SHALL BE INTERCONNECTED, SHALL BE WITHIN 1' TO 3' OF PEAK & SHALL BE 3' FROM THE SUPPLY OR RETURN AIR- STREAM & EQUIPPED W/ A BATTERY BACKUP. ALARMS MAY NOT BE CONNECTED WHERE ALARMS ARE WIRELESS & ALL ALARMS SOUND UPON ACTIVATION IAW FBC-R R314.3 & R314.4.
- ALL ELECTRICAL WORK TO BE DONE PER NFPA70-NEC 2020
  - ADDITIONAL ELECTRODE MAY BE REQUIRED IN ACCORDANCE WITH NEC 250.53(A)(2)
  - ALL DWELLING UNIT RECEPTACLE WILL BE IN ACCORDANCE WITH NFPA70-NEC2020 - ARTICLE 210-52

**MECHANICAL:**

- EQUIPMENT LOCATIONS TO BE FIELD VERIFIED & MAY VARY DEPENDANT UPON COMMUNITY & MUNICIPALITY CODES.
- COMPLETE DUCT DESIGN W/ SIZES & R-VALUE COMPLYING W/ THE FLORIDA ENERGY EFFICIENCY CODE FOR BUILDING CONSTRUCTION 610.1 ABC1
- APPLIANCES SHALL BE ACCESSIBLE FOR INSPECTION, SERVICE, REPAIR & REPLACEMENT WITHOUT REMOVING PERMANENT CONSTRUCTION.
  - CHAPTER 13 OF THE FBC-R 2023 8TH EDITION, SECTION M1305.1
- AIR CONDITIONING SYSTEM SHALL BE COMPLETELY BALANCED. ALL ROOMS ISOLATED FROM THE RETURN AIR SHALL BE PROVIDED WITH MEANS TO COMPLY WITH SECTION M1602 OF THE FBC-R 2023 8TH EDITION.
- ALL WATER HEATERS HAVING AN IGNITION SOURCE TO BE ELEVATED SUCH THAT THE SOURCE OF IGNITION IS MINIMUM 18" ABOVE GARAGE FLOOR UNLESS WATER HEATER IS LISTED AS FLAMMABLE VAPOR IGNITION RESISTANT. IAW FBC-R 2023 8TH EDITION P280.17
- ALL EQUIPMENT & APPLIANCES, INCLUDING WATER HEATERS HAVING AN IGNITION SOURCE TO BE ELEVATED SUCH THAT THE SOURCE OF IGNITION IS MINIMUM 18" ABOVE GARAGE FLOOR UNLESS IT IS LISTED AS FLAMMABLE VAPOR IGNITION RESISTANT. IAW FBC-R 2023 8TH EDITION.
  - THE MAXIMUM ALLOWABLE EXHAUST DUCT LENGTH SHALL BE DETERMINED BY ONE OF THE METHODS SPECIFIED IN SECTIONS M1502.4.5.1 THROUGH M1502.4.5.3

**STAIRS:**

- SEE STAIR SECTIONS FOR TREAD & RISER GENERAL REQUIREMENTS.
- ACCESSIBLE SPACE UNDER STAIRS SHALL BE PROTECTED BY 1/2" GYPSUM BOARD.
- HANDRAIL CONTINUITY PER R311.7.2.- HANDRAILS FOR STAIRS SHALL BE CONTINUOUS FOR FULL LENGTH OF THE FLIGHT, FROM A POINT DIRECTLY ABOVE THE TOP RISER OF THE FLIGHT TO A POINT DIRECTLY ABOVE THE LOWEST RISER OF THE FLIGHT. HANDRAIL ENDS SHALL BE RETURNED OR SHALL TERMINATE IN NEUEL POST OR SAFETY TERMINALS. HANDRAILS ADJACENT TO A WALL SHALL HAVE A SPACE OF NO LESS THAN 1 1/2"(38MM) BETWEEN THE WALL & THE HANDRAIL.

**SWIMMING POOLS:**

- CHAPTER 45 PRIVATE SWIMMING POOLS - OUTDOOR SWIMMING POOLS SHALL BE PROVIDED WITH A BARRIER COMPLYING W/ R450.11.1. THROUGH R450.11.14.

THIS STRUCTURE IS DESIGNED IN ACCORDANCE WITH THE 8th EDITION, 2023 OF THE FLORIDA BUILDING CODE-RESIDENTIAL AND IS CERTIFIED AS SUCH

LOT: 0000, COMMUNITY

PARK SQUARE HOMES RESERVES COPYRIGHT & OTHER RIGHTS RESTRICTING THESE DOCUMENTS TO THE ORIGINAL SITE OR PURPOSE FOR WHICH THEY WERE PREPARED. REPRODUCTIONS, CHANGES OR ASSIGNMENTS ARE PROHIBITED.



A DIVISION OF PARK SQUARE ENTERPRISES, INC.  
5200 Vineyard Road, Suite 200  
Orlando, Florida 32811  
Phone: (407) 529 - 3000

www.hteg.com

1860 SKY

40' EXPLORATION SERIES

REVISIONS	
DELTA #	DATE

DATE: 09-11-25

SCALE: AS NOTED



DRAWN: MR

SHEET:

00.1

FOUNDATION NOTES

1. CONTRACTOR VERIFY ALL DIMENSIONS ON JOB SITE.
2. DO NOT SCALE PRINTS! CONSTRUCTION TO BE FROM CALCULATED DIMENSIONS ONLY. ANY DISCREPANCIES OR ERRORS TO BE REPORTED PROMPTLY TO SUPERVISOR FOR CLARIFICATION.
3. WATER HEATER T & P RELIEF VALVE SHALL BE FULL SIZE TO EXTERIOR. WATER HEATER AT OR ABOVE FLOOR LEVEL SHALL BE IN A PAN WITH DRAIN TO EXTERIOR. WATER HEATER SHALL HAVE APPROVED THERMAL EXPANSION DEVICE.
4. PAVERS MAY BE USED I.O. CONCRETE SLABS IN PATIO, PORCH, DRIVE AND WALKWAY AREAS. DELETE SLAB IN AREAS PAVERS ARE USED. VERIFY W/ COMMUNITY SPECIFICATIONS.
5. MECHANICAL EQUIP. LOCATIONS TO BE FIELD VERIFIED & MAY BE DEFENDANT UPON COMMUNITY AND MUNICIPALITY CODES.
6. IN LIEU OF TREATING THE SOIL, AN ALTERNATIVE TO TERMITE TREATED SOIL CAN BE TERMICIDE.
7. BORA-CARE TO BE APPLIED ON INTERIOR WALLS IAW MANUFACTURER'S INSTRUCTIONS AND SPECIFICATIONS, PURSUANT TO FEC-R- CURRENT EDITION.

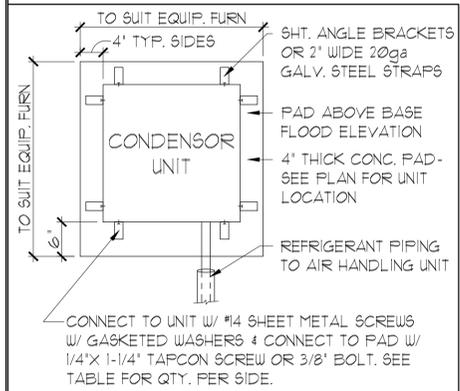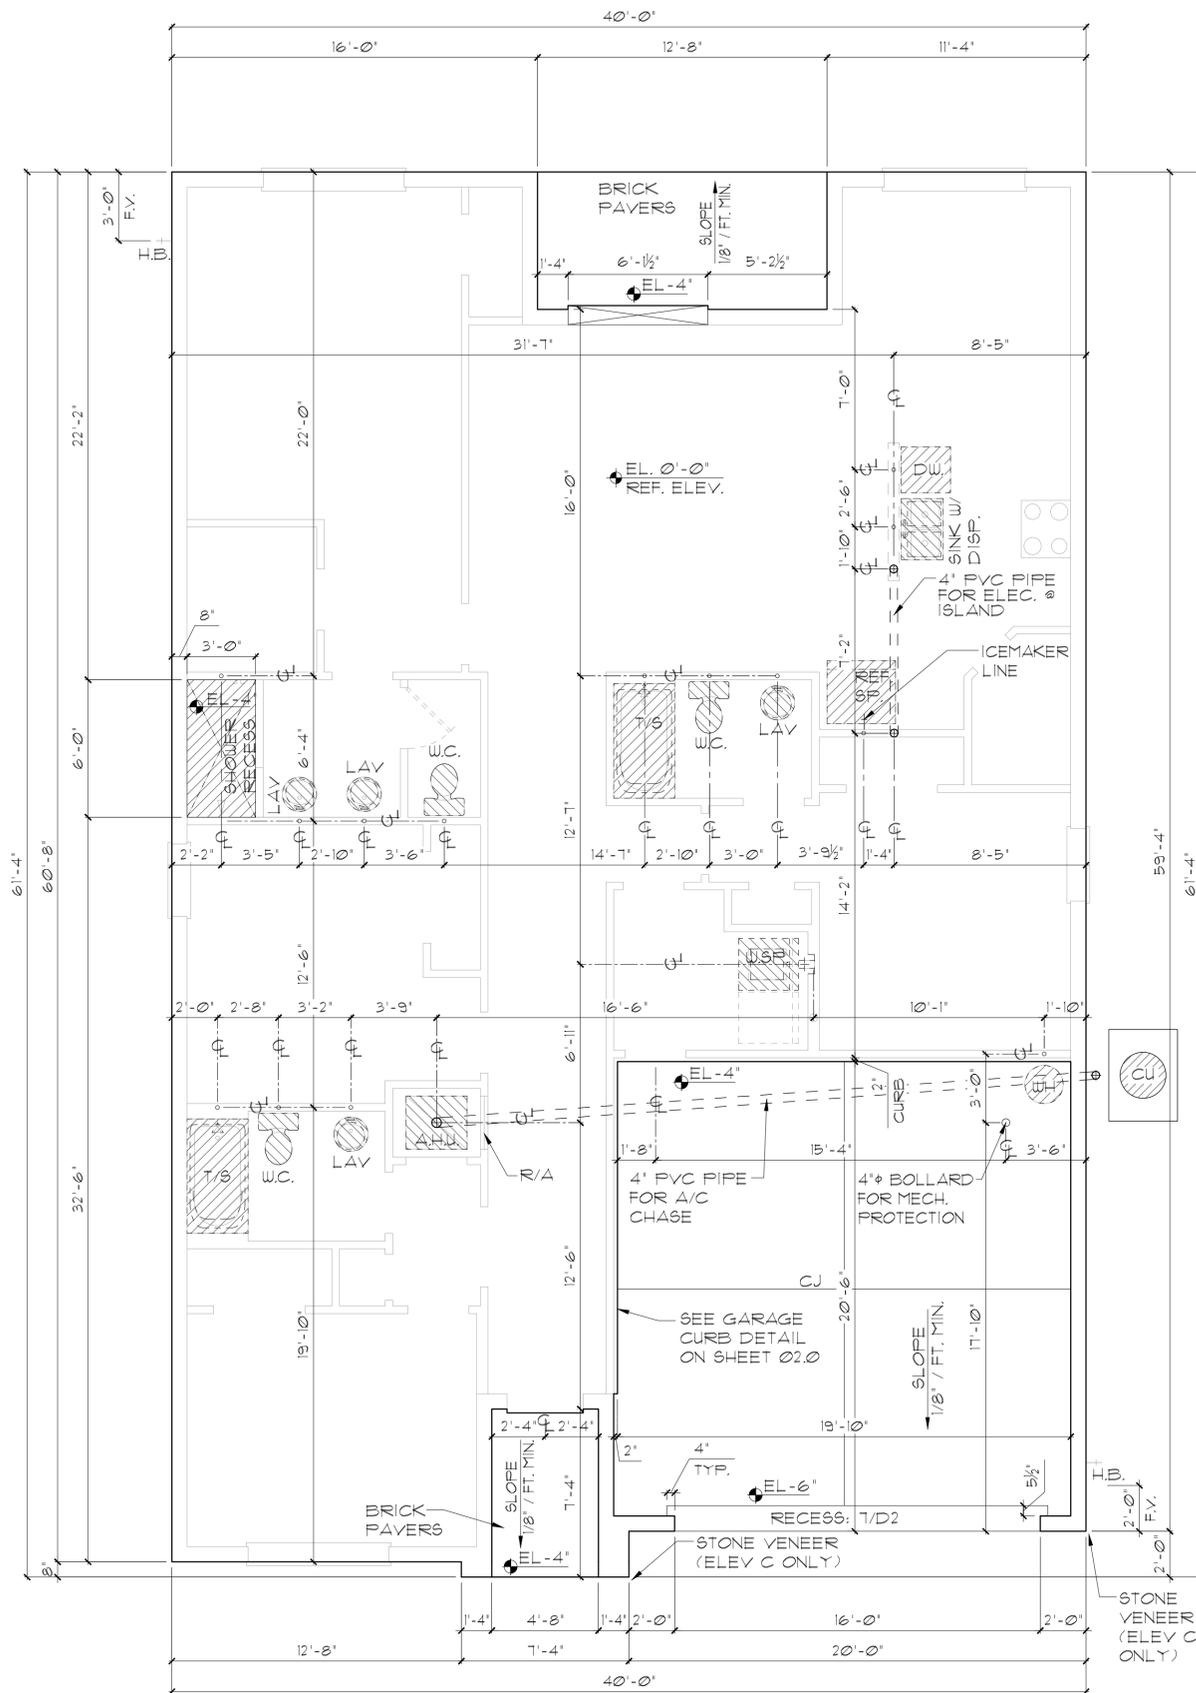

ANCHOR SPACING TABLE	
LENGTH / SIDE	NO. OF ANCHOR/SIDES
LESS THAN 12'	ONE / SIDE
12' - 24'	TWO / SIDE
24' - 36'	THREE / SIDE
36' UP & 5tons & UP	FOUR / SIDE

1 COND. ANCHOR DET. N.T.S.

THIS STRUCTURE IS DESIGNED IN ACCORDANCE WITH THE 2018 EDITION, 2023 OF THE FLORIDA BUILDING CODE-RESIDENTIAL AND IS CERTIFIED AS SUCH

LOT: 0000, COMMUNITY

PARK SQUARE HOMES RESERVES COPYRIGHT & OTHER RIGHTS RESTRICTING THESE DOCUMENTS TO THE ORIGINAL SITE OR PURPOSE FOR WHICH THEY WERE PREPARED. REPRODUCTIONS, CHANGES OR ASSIGNMENTS ARE PROHIBITED.

**ITEG**  
 THOMPSON ENGINEERING GROUP, INC.  
 1447 Vineyard Road Suite A8 Orlando, FL 32811  
 Tel: (407) 241-1790 Fax: (407) 241-1790 www.iteg.com

A DIVISION OF PARK SQUARE ENTERPRISES, INC.  
 5200 Vineyard Road, Suite 200 Orlando, Florida 32811 Phone: (407) 529 - 3000

**Park Square HOMES**  
 SLAB INTERFACE PLAN  
 1860 SKY  
 40' EXPLORATION SERIES



REVISIONS	
DELTA #	DATE

DATE: 09-11-25  
SCALE: AS NOTED  
DRAWN: MR  
SHEET: 01.0

ELEVATION A & C STD  
SLAB INTERFACE PLAN  
1/8"=1'-0" (11X17) 1/4"=1'-0" (22X34)

FOUNDATION NOTES

1. CONTRACTOR VERIFY ALL DIMENSIONS ON JOB SITE.
2. DO NOT SCALE PRINTS! CONSTRUCTION TO BE FROM CALCULATED DIMENSIONS ONLY. ANY DISCREPANCIES OR ERRORS TO BE REPORTED PROMPTLY TO SUPERVISOR FOR CLARIFICATION.
3. WATER HEATER T & P RELIEF VALVE SHALL BE FULL SIZE TO EXTERIOR. WATER HEATER AT OR ABOVE FLOOR LEVEL SHALL BE IN A PAN WITH DRAIN TO EXTERIOR. WATER HEATER SHALL HAVE APPROVED THERMAL EXPANSION DEVICE.
4. PAVERS MAY BE USED I.L.O. CONCRETE SLABS IN PATIO, PORCH, DRIVE AND WALKWAY AREAS. DELETE SLAB IN AREAS PAVERS ARE USED. VERIFY W/ COMMUNITY SPECIFICATIONS.
5. MECHANICAL EQUIP. LOCATIONS TO BE FIELD VERIFIED & MAY BE DEFENDANT UPON COMMUNITY AND MUNICIPALITY CODES.
6. IN LIEU OF TREATING THE SOIL, AN ALTERNATIVE TO TERMITE TREATED SOIL CAN BE TERMICIDE.
7. BORA-CARE TO BE APPLIED ON INTERIOR WALLS IAW MANUFACTURER'S INSTRUCTIONS AND SPECIFICATIONS, PURSUANT TO FEC-R- CURRENT EDITION.

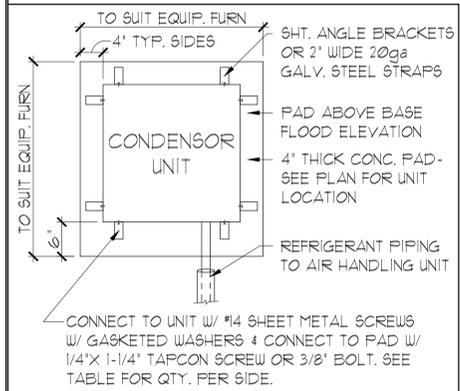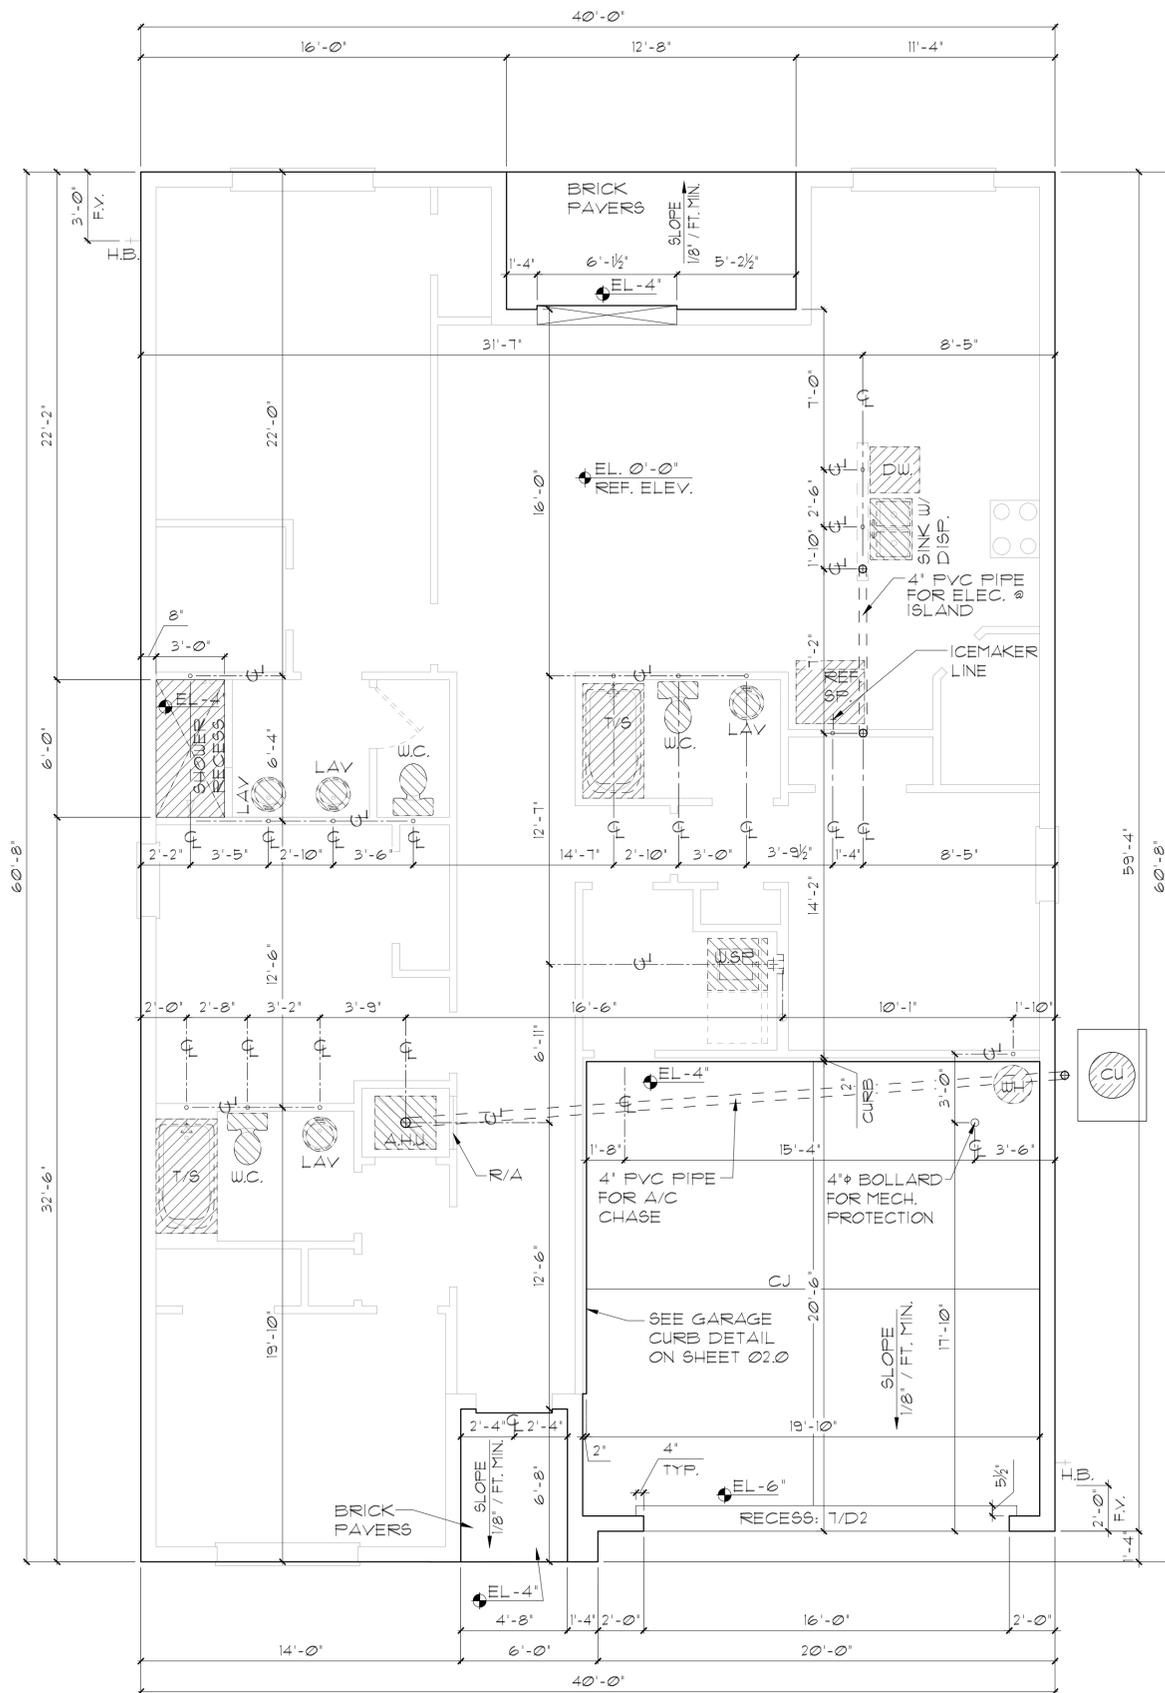

ANCHOR SPACING TABLE	
LENGTH / SIDE LESS THAN 12'	NO. OF ANCHOR/SIDES ONE / SIDE
12' - 24'	TWO / SIDE
24' - 36'	THREE / SIDE
36' UP & 5tons & UP	FOUR / SIDE

1 COND. ANCHOR DET. N.T.S.

ELEVATION B STD  
SLAB INTERFACE PLAN  
1/8"=1'-0" (11X17) 1/4"=1'-0" (22X34)

THIS STRUCTURE IS DESIGNED IN ACCORDANCE WITH THE 2018 EDITION, 2023 OF THE FLORIDA BUILDING CODE-RESIDENTIAL AND IS CERTIFIED AS SUCH

LOT: 0000, COMMUNITY

PARK SQUARE HOMES RESERVES COPYRIGHT & OTHER RIGHTS RESTRICTING THESE DOCUMENTS TO THE ORIGINAL SITE OR PURPOSE FOR WHICH THEY WERE PREPARED. REPRODUCTIONS, CHANGES OR ASSIGNMENTS ARE PROHIBITED.

**ITEG**  
 THOMPSON ENGINEERING GROUP, INC.  
 1447 Vineyard Road Suite A8 Orlando, FL 32811  
 Tel: (407) 724-1790 Fax: (407) 724-1790 www.iteg.com


A DIVISION OF PARK SQUARE ENTERPRISES, INC.  
 5200 Vineyard Road, Suite 200 Orlando, Florida 32811 Phone: (407) 529 - 3000

**Park Square HOMES**  
 SLAB INTERFACE PLAN  
 1860 SKY  
 40' EXPLORATION SERIES

REVISIONS	
DELTA #	DATE

DATE: 09-11-25  
SCALE: AS NOTED  
DRAWN: MR  
SHEET: 01.0

DISCLAIMER: CONTRACTOR/SUB-CONTRACTOR IS RESPONSIBLE TO REVIEW ALL INFORMATION CONTAINED HEREIN PRIOR TO COMMENCEMENT OF CONSTRUCTION. PARK SQUARE HOMES IS NOT RESPONSIBLE FOR ANY MISINTERPRETATIONS, ERRORS, OMISSIONS OR CUSTOM CHANGES MISSED AND NOT REPORTED PRIOR TO CONSTRUCTION. NO EXCEPTIONS.

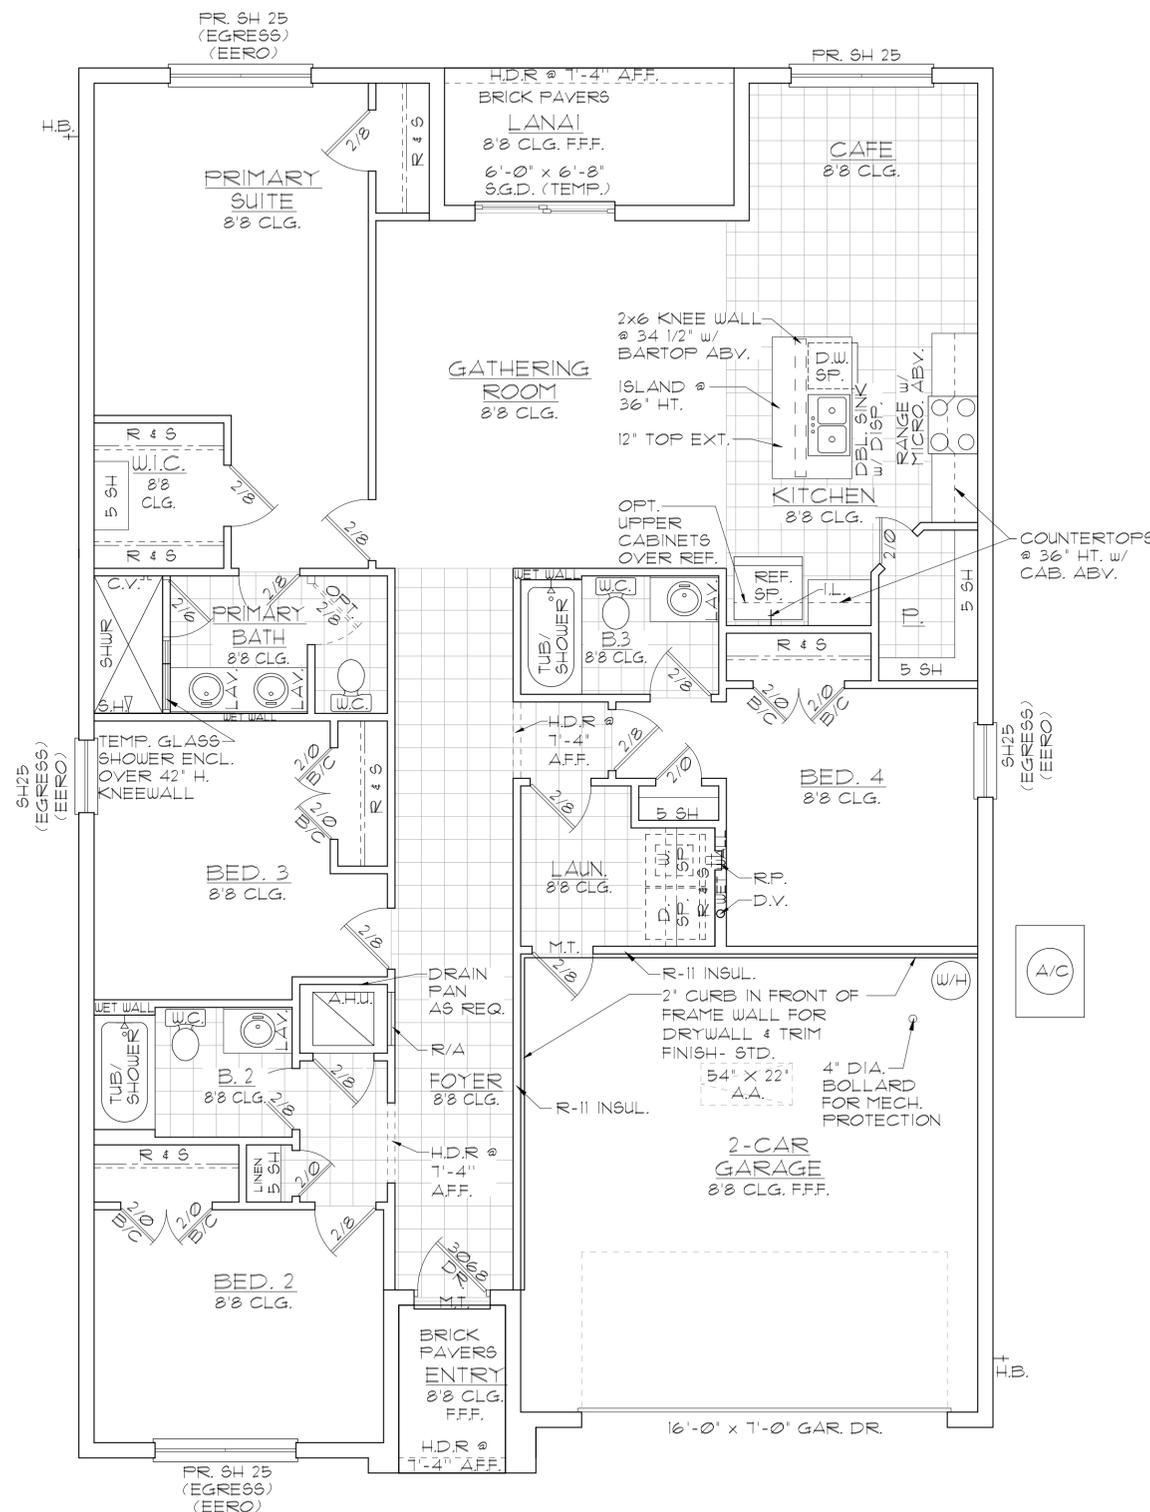

- ### GENERAL NOTES
- CONTRACTOR TO VERIFY ALL DIMENSIONS ON JOB SITE.
  - DO NOT SCALE PRINTS! CONSTRUCTION TO BE FROM CALCULATED DIMENSIONS ONLY. ANY DISCREPANCIES OR ERRORS TO BE REPORTED PROMPTLY TO SUPERVISOR FOR CLARIFICATION.
  - ALL INTERIOR FRAME WALL DIMENSIONS TO BE 3-1/2" UNLESS NOTED OTHERWISE.
  - ALL EXTERIOR BLOCK WALL DIMENSIONS TO BE 1-5/8" UNLESS NOTED OTHERWISE.
  - DOOR FROM HOUSE TO GARAGE MUST BE SOLID WOOD DOOR NO LESS THAN 1 3/8" IN THICKNESS, SOLID OR HONEYCOMB CORE STEEL DOORS NOT LESS THAN 1 3/8" THICK, OR 20 MIN. FIRE RATED (AW R302.5).
  - GARAGE SHALL BE SEPARATED FROM THE RESIDENCE & ITS ATTIC AREA BY NOT LESS THAN 1/2" GYP. BD. APPLIED TO THE GAR. SIDE. PROVIDE 5/8" TYPE 'X' GYP. BD. AT CEILING ONLY APPLIED PERPENDICULAR TO CEILING FRAME.
  - PULL ALL DIMENSIONS FROM THE REAR OF THE PLAN.
  - SEE GENERAL NOTES PAGE FOR ADDITIONAL INFO.
- ### WALL LEGEND
- [Symbol] DENOTES CONC. BLOCK WALL HGT. @ 8'-0" AFF.
  - [Symbol] DENOTES CONC. BLOCK WALL HGT. @ 10'-0" AFF.
  - [Symbol] DENOTES 2x INSULATED FRAME WALL
- NOTE: SEE COLOR SHEET FOR FLOORING & INTERIOR DOOR HEIGHT REQUIREMENTS


### AREA CALCULATIONS

TOTAL LIVING	1,860 SF.
GARAGE	427 SF.
ENTRY	41 SF.
LANAI	76 SF.
<b>TOTAL UNDER ROOF</b>	<b>2,404 SF.</b>

## ELEVATION A STD

### FLOOR PLAN W/ NOTES

1/8" = 1'-0" (11X17) 1/4" = 1'-0" (22X34)

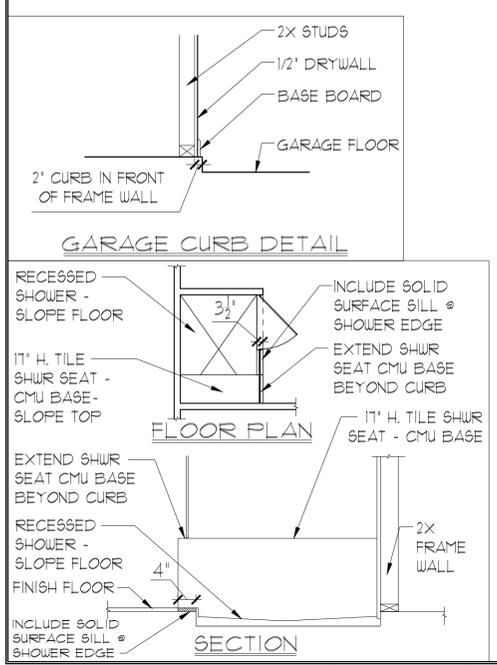

THIS STRUCTURE IS DESIGNED IN ACCORDANCE WITH THE 2018 EDITION, 2023 OF THE FLORIDA BUILDING CODE-RESIDENTIAL AND IS CERTIFIED AS SUCH

**LOT: 0000, COMMUNITY**

1860 SKY

40' EXPLORATION SERIES

REVISIONS

DELTA #	DATE

DATE: 09-11-25

SCALE: AS NOTED

DRAWN: MR

SHEET: 02.0


**ITEC**  
 THOMPSON ENGINEERING GROUP, INC.  
 4401 Vineyard Road Suite #8 Orlando, FL 32811  
 Phone: (407) 241-1790  
 www.itec.com

A DIVISION OF PARK SQUARE ENTERPRISES, INC.  
 5200 Vineyard Road, Suite 200  
 Orlando, Florida 32811  
 Phone: (407) 529 - 3000

**Park Square HOMES**

FLOOR PLAN W/ NOTES

DISCLAIMER: CONTRACTOR/SUB-CONTRACTOR IS RESPONSIBLE TO REVIEW ALL INFORMATION CONTAINED HEREIN PRIOR TO COMMENCEMENT OF CONSTRUCTION. PARK SQUARE HOMES IS NOT RESPONSIBLE FOR ANY MISINTERPRETATIONS, ERRORS, OMISSIONS OR CUSTOM CHANGES MISSED AND NOT REPORTED PRIOR TO CONSTRUCTION. NO EXCEPTIONS.

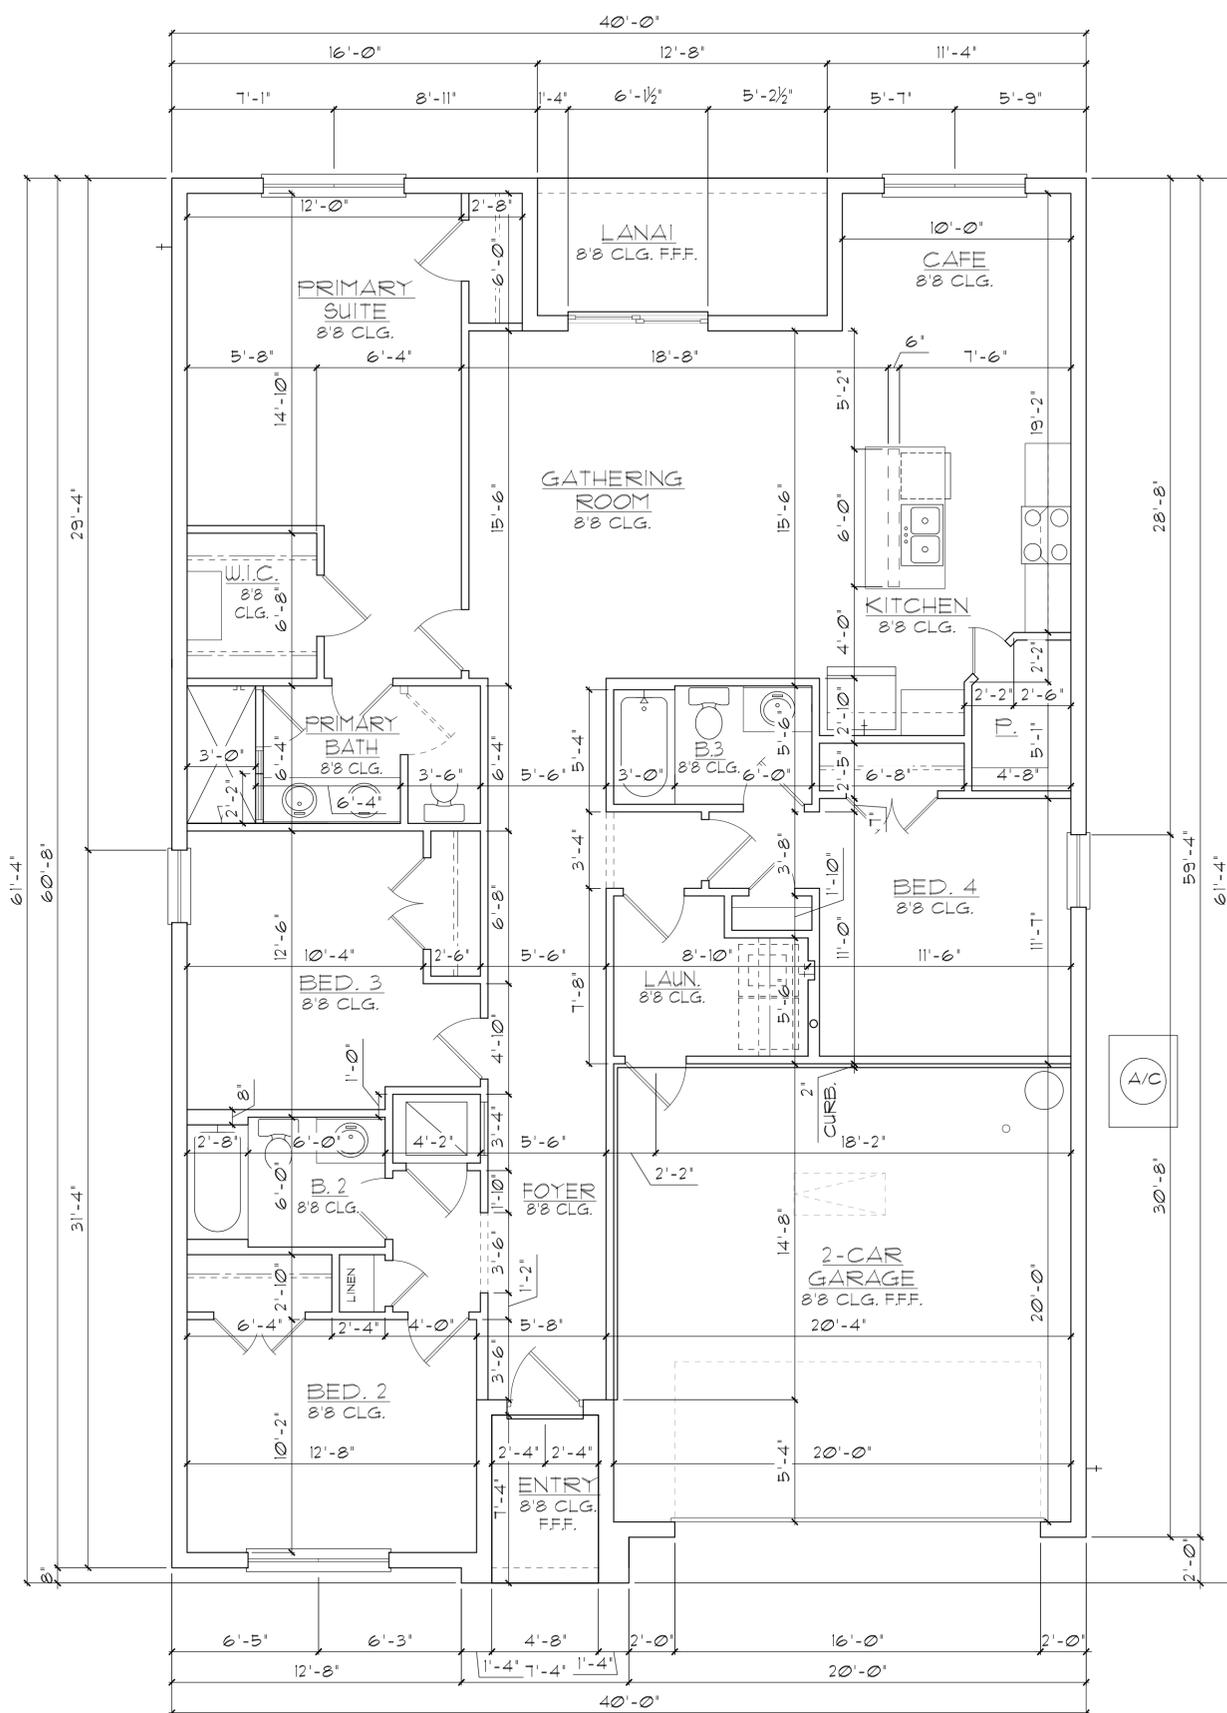

- ### GENERAL NOTES
- CONTRACTOR TO VERIFY ALL DIMENSIONS ON JOB SITE.
  - DO NOT SCALE PRINTS! CONSTRUCTION TO BE FROM CALCULATED DIMENSIONS ONLY. ANY DISCREPANCIES OR ERRORS TO BE REPORTED PROMPTLY TO SUPERVISOR FOR CLARIFICATION.
  - ALL INTERIOR FRAME WALL DIMENSIONS TO BE 3-1/2" UNLESS NOTED OTHERWISE.
  - ALL EXTERIOR BLOCK WALL DIMENSIONS TO BE 1-5/8" UNLESS NOTED OTHERWISE.
  - DOOR FROM HOUSE TO GARAGE MUST BE SOLID WOOD DOOR NO LESS THAN 1 3/8" IN THICKNESS, SOLID OR HONEYCOMB CORE STEEL DOORS NOT LESS THAN 1 3/8" THICK, OR 20 MIN. FIRE RATED (AW R302.5).
  - GARAGE SHALL BE SEPARATED FROM THE RESIDENCE & ITS ATTIC AREA BY NOT LESS THAN 1/2" GYP. BD. APPLIED TO THE GAR. SIDE. PROVIDE 5/8" TYPE 'X' GYP. BD. AT CEILING ONLY APPLIED PERPENDICULAR TO CEILING FRAME.
  - PULL ALL DIMENSIONS FROM THE REAR OF THE PLAN.
  - SEE GENERAL NOTES PAGE FOR ADDITIONAL INFO.

### WALL LEGEND

	DENOTES CONC. BLOCK WALL HGT. @ 8'-0" AFF.
	DENOTES CONC. BLOCK WALL HGT. @ 10'-0" AFF.
	DENOTES 2x INSULATED FRAME WALL


NOTE: SEE COLOR SHEET FOR FLOORING & INTERIOR DOOR HEIGHT REQUIREMENTS

### AREA CALCULATIONS

TOTAL LIVING	1,860 SF.
GARAGE	427 SF.
ENTRY	41 SF.
LANAI	76 SF.
<b>TOTAL UNDER ROOF</b>	<b>2,404 SF.</b>

## ELEVATION A STD FLOOR PLAN W/ DIMENSIONS

1/8"=1'-0" (11X17) 1/4"=1'-0" (22X34)

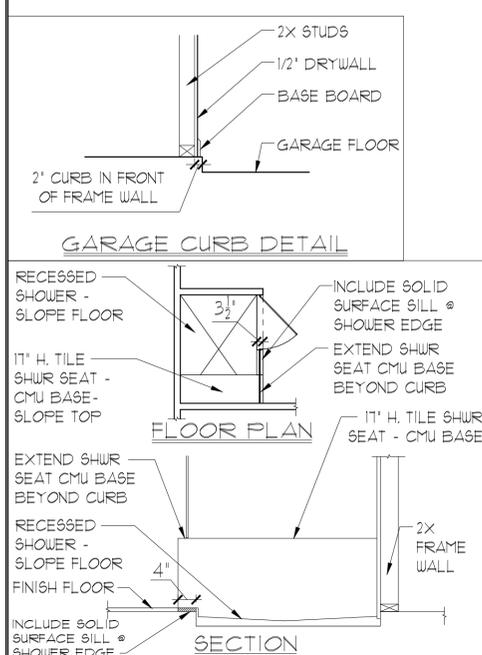

THIS STRUCTURE IS DESIGNED IN ACCORDANCE WITH THE 2018 EDITION, 2023 OF THE FLORIDA BUILDING CODE-RESIDENTIAL AND IS CERTIFIED AS SUCH

LOT: 0000, COMMUNITY



A DIVISION OF PARK SQUARE ENTERPRISES, INC.  
5200 Vineyard Road, Suite 200  
Orlando, Florida 32811  
Phone: (407) 629-3000




FLOOR PLAN W/ DIMENSIONS

1860 SKY  
40' EXPLORATION SERIES

REVISIONS	
DELTA #	DATE
DATE:	09-11-25
SCALE:	AS NOTED
DRAWN:	MR
SHEET:	02.1

DISCLAIMER: CONTRACTOR/SUB-CONTRACTOR IS RESPONSIBLE TO REVIEW ALL INFORMATION CONTAINED HEREIN PRIOR TO COMMENCEMENT OF CONSTRUCTION. PARK SQUARE HOMES IS NOT RESPONSIBLE FOR ANY MISINTERPRETATIONS, ERRORS, OMISSIONS OR CUSTOM CHANGES MISSED AND NOT REPORTED PRIOR TO CONSTRUCTION. NO EXCEPTIONS.

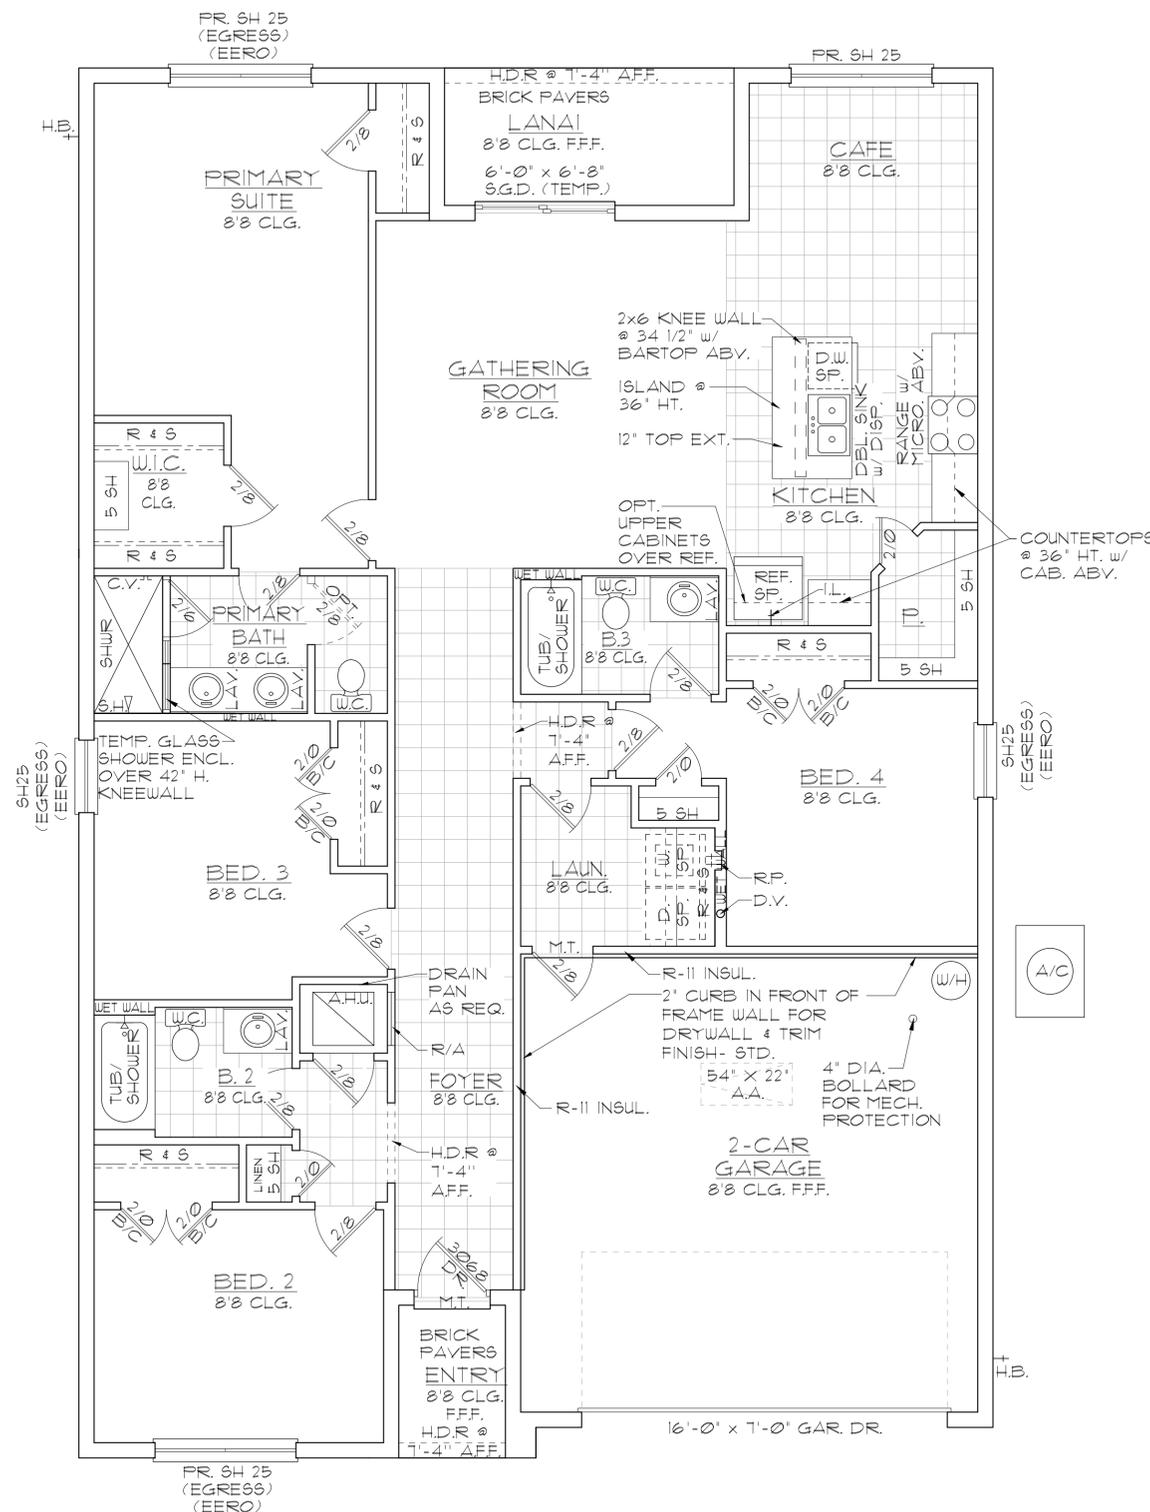

- ### GENERAL NOTES
- CONTRACTOR TO VERIFY ALL DIMENSIONS ON JOB SITE.
  - DO NOT SCALE PRINTS! CONSTRUCTION TO BE FROM CALCULATED DIMENSIONS ONLY. ANY DISCREPANCIES OR ERRORS TO BE REPORTED PROMPTLY TO SUPERVISOR FOR CLARIFICATION.
  - ALL INTERIOR FRAME WALL DIMENSIONS TO BE 3-1/2" UNLESS NOTED OTHERWISE.
  - ALL EXTERIOR BLOCK WALL DIMENSIONS TO BE 1-5/8" UNLESS NOTED OTHERWISE.
  - DOOR FROM HOUSE TO GARAGE MUST BE SOLID WOOD DOOR NO LESS THAN 1 3/8" IN THICKNESS, SOLID OR HONEYCOMB CORE STEEL DOORS NOT LESS THAN 1 3/8" THICK, OR 20 MIN. FIRE RATED (AW R302.5).
  - GARAGE SHALL BE SEPARATED FROM THE RESIDENCE & ITS ATTIC AREA BY NOT LESS THAN 1/2" GYP. BD. APPLIED TO THE GAR. SIDE. PROVIDE 5/8" TYPE 'X' GYP. BD. AT CEILING ONLY APPLIED PERPENDICULAR TO CEILING FRAME.
  - PULL ALL DIMENSIONS FROM THE REAR OF THE PLAN.
  - SEE GENERAL NOTES PAGE FOR ADDITIONAL INFO.
- ### WALL LEGEND
- [Symbol] DENOTES CONC. BLOCK WALL HGT. @ 8'-0" AFF.
  - [Symbol] DENOTES CONC. BLOCK WALL HGT. @ 10'-0" AFF.
  - [Symbol] DENOTES 2x INSULATED FRAME WALL
- NOTE: SEE COLOR SHEET FOR FLOORING & INTERIOR DOOR HEIGHT REQUIREMENTS


### AREA CALCULATIONS

TOTAL LIVING	1,860 SF.
GARAGE	421 SF.
ENTRY	36 SF.
LANAI	76 SF.
<b>TOTAL UNDER ROOF</b>	<b>2,393 SF.</b>

## ELEVATION B STD

### FLOOR PLAN W/ NOTES

1/8" = 1'-0" (11X17) 1/4" = 1'-0" (22X34)

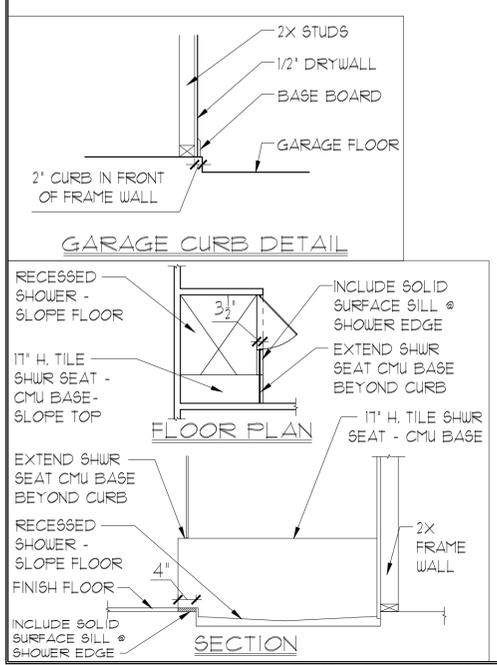

THIS STRUCTURE IS DESIGNED IN ACCORDANCE WITH THE 2018 EDITION, 2023 OF THE FLORIDA BUILDING CODE-RESIDENTIAL AND IS CERTIFIED AS SUCH  
**LOT: 0000, COMMUNITY**  
**1860 SKY**  
**40' EXPLORATION SERIES**

**ITEC**  
 THOMPSON ENGINEERING GROUP, INC.  
 4401 Vineyard Road Suite #8 Orlando, FL 32811  
 Tel: (407) 241-1790  
 Fax: (407) 241-1790  
 www.itec.com


**Park Square HOMES**  
 A DIVISION OF PARK SQUARE ENTERPRISES, INC.  
 5200 Vineyard Road, Suite 200  
 Orlando, Florida 32811  
 Phone: (407) 529 - 3000

**FLOOR PLAN W/ NOTES**

REVISIONS	
DELTA #	DATE

DATE: 09-11-25  
 SCALE: AS NOTED  
 DRAWN: MR  
 SHEET: 02.0


DISCLAIMER: CONTRACTOR/SUB-CONTRACTOR IS RESPONSIBLE TO REVIEW ALL INFORMATION CONTAINED HEREIN PRIOR TO COMMENCEMENT OF CONSTRUCTION. PARK SQUARE HOMES IS NOT RESPONSIBLE FOR ANY MISINTERPRETATIONS, ERRORS, OMISSIONS OR CUSTOM CHANGES MISSED AND NOT REPORTED PRIOR TO CONSTRUCTION. NO EXCEPTIONS.

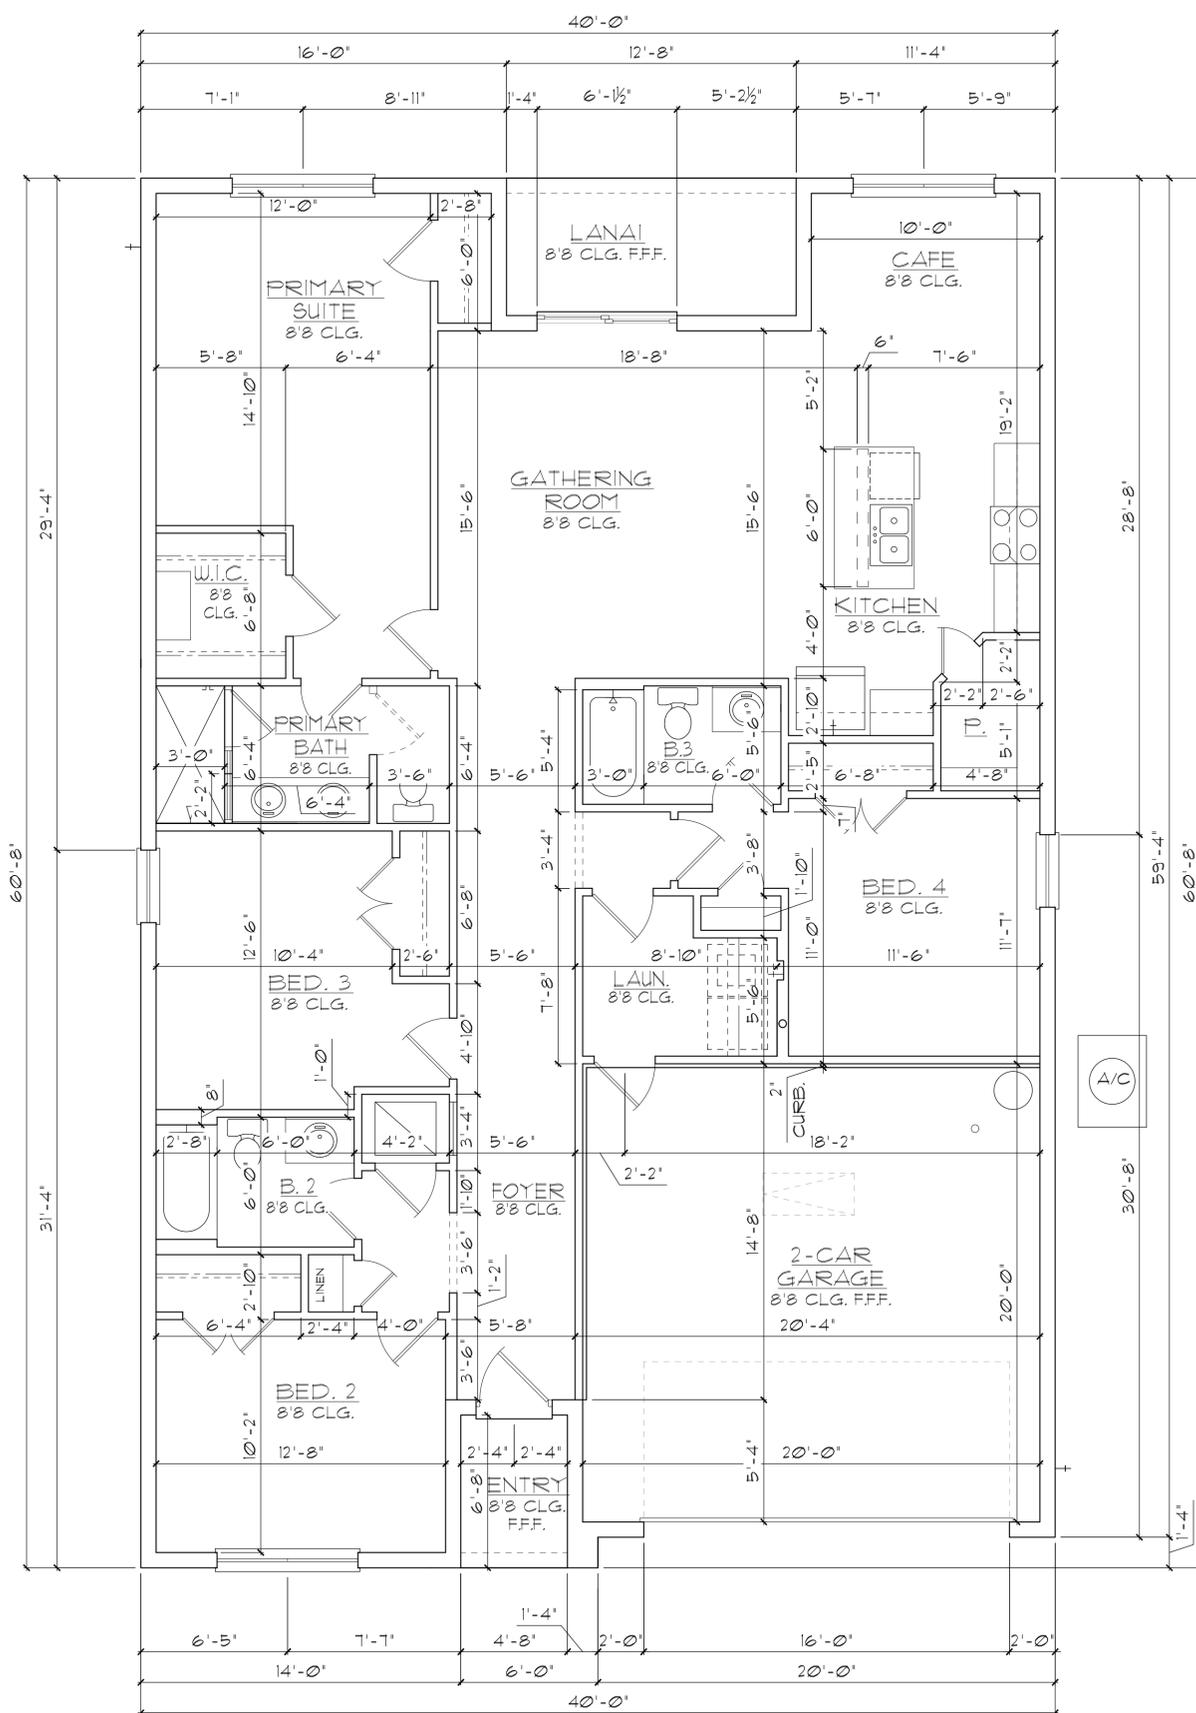

- ### GENERAL NOTES
- CONTRACTOR TO VERIFY ALL DIMENSIONS ON JOB SITE.
  - DO NOT SCALE PRINTS! CONSTRUCTION TO BE FROM CALCULATED DIMENSIONS ONLY. ANY DISCREPANCIES OR ERRORS TO BE REPORTED PROMPTLY TO SUPERVISOR FOR CLARIFICATION.
  - ALL INTERIOR FRAME WALL DIMENSIONS TO BE 3'-1/2" UNLESS NOTED OTHERWISE.
  - ALL EXTERIOR BLOCK WALL DIMENSIONS TO BE 1'-5/8" UNLESS NOTED OTHERWISE.
  - DOOR FROM HOUSE TO GARAGE MUST BE SOLID WOOD DOOR NO LESS THAN 1 3/8" IN THICKNESS, SOLID OR HONEYCOMB CORE STEEL DOORS NOT LESS THAN 1 3/8" THICK, OR 20 MIN. FIRE RATED (AW R302.5).
  - GARAGE SHALL BE SEPARATED FROM THE RESIDENCE & ITS ATTIC AREA BY NOT LESS THAN 1/2" GYP. BD. APPLIED TO THE GAR. SIDE. PROVIDE 5/8" TYPE 'X' GYP. BD. AT CEILING ONLY APPLIED PERPENDICULAR TO CEILING FRAME.
  - PULL ALL DIMENSIONS FROM THE REAR OF THE PLAN.
  - SEE GENERAL NOTES PAGE FOR ADDITIONAL INFO.
- ### WALL LEGEND
- [Symbol] DENOTES CONC. BLOCK WALL HGT. @ 8'-0" AFF.
  - [Symbol] DENOTES CONC. BLOCK WALL HGT. @ 10'-0" AFF.
  - [Symbol] DENOTES 2x INSULATED FRAME WALL
- NOTE: SEE COLOR SHEET FOR FLOORING & INTERIOR DOOR HEIGHT REQUIREMENTS

### AREA CALCULATIONS

TOTAL LIVING	1,860 SF.
GARAGE	421 SF.
ENTRY	36 SF.
LANAI	76 SF.
<b>TOTAL UNDER ROOF</b>	<b>2,393 SF.</b>

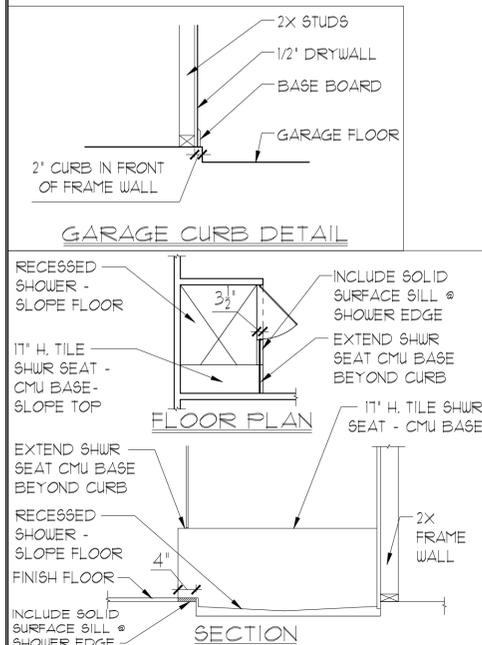

## ELEVATION B STD FLOOR PLAN W/ DIMENSIONS

1/8"=1'-0" (11X17) 1/4"=1'-0" (22X34)

THIS STRUCTURE IS DESIGNED IN ACCORDANCE WITH THE 2018 EDITION, 2023 OF THE FLORIDA BUILDING CODE-RESIDENTIAL AND IS CERTIFIED AS SUCH

**LOT: 0000, COMMUNITY**

PARK SQUARE HOMES RESERVES COPYRIGHT & OTHER RIGHTS RESTRICTING THESE DOCUMENTS TO THE ORIGINAL SITE OR PURPOSE FOR WHICH THEY WERE PREPARED. REPRODUCTIONS, CHANGES OR ASSIGNMENTS ARE PROHIBITED.

**1860 SKY**

**40' EXPLORATION SERIES**

**REVISIONS**

DELTA #	DATE

DATE: 09-11-25

SCALE: AS NOTED

DRAWN: MR

SHEET: 02.1


**ITEG**  
THOMPSON ENGINEERING GROUP, INC.  
1447 Vineyard Road Suite A8 Orlando, FL 32811  
Tel: (407) 244-1790  
www.iteg.com

A DIVISION OF PARK SQUARE ENTERPRISES, INC.  
5200 Vineyard Road, Suite 200  
Orlando, Florida 32811  
Phone: (407) 629 - 3000

**Park Square HOMES**

**FLOOR PLAN W/ DIMENSIONS**

DISCLAIMER: CONTRACTOR/SUB-CONTRACTOR IS RESPONSIBLE TO REVIEW ALL INFORMATION CONTAINED HEREIN PRIOR TO COMMENCEMENT OF CONSTRUCTION. PARK SQUARE HOMES IS NOT RESPONSIBLE FOR ANY MISINTERPRETATIONS, ERRORS, OMISSIONS OR CUSTOM CHANGES MISSED AND NOT REPORTED PRIOR TO CONSTRUCTION. NO EXCEPTIONS.

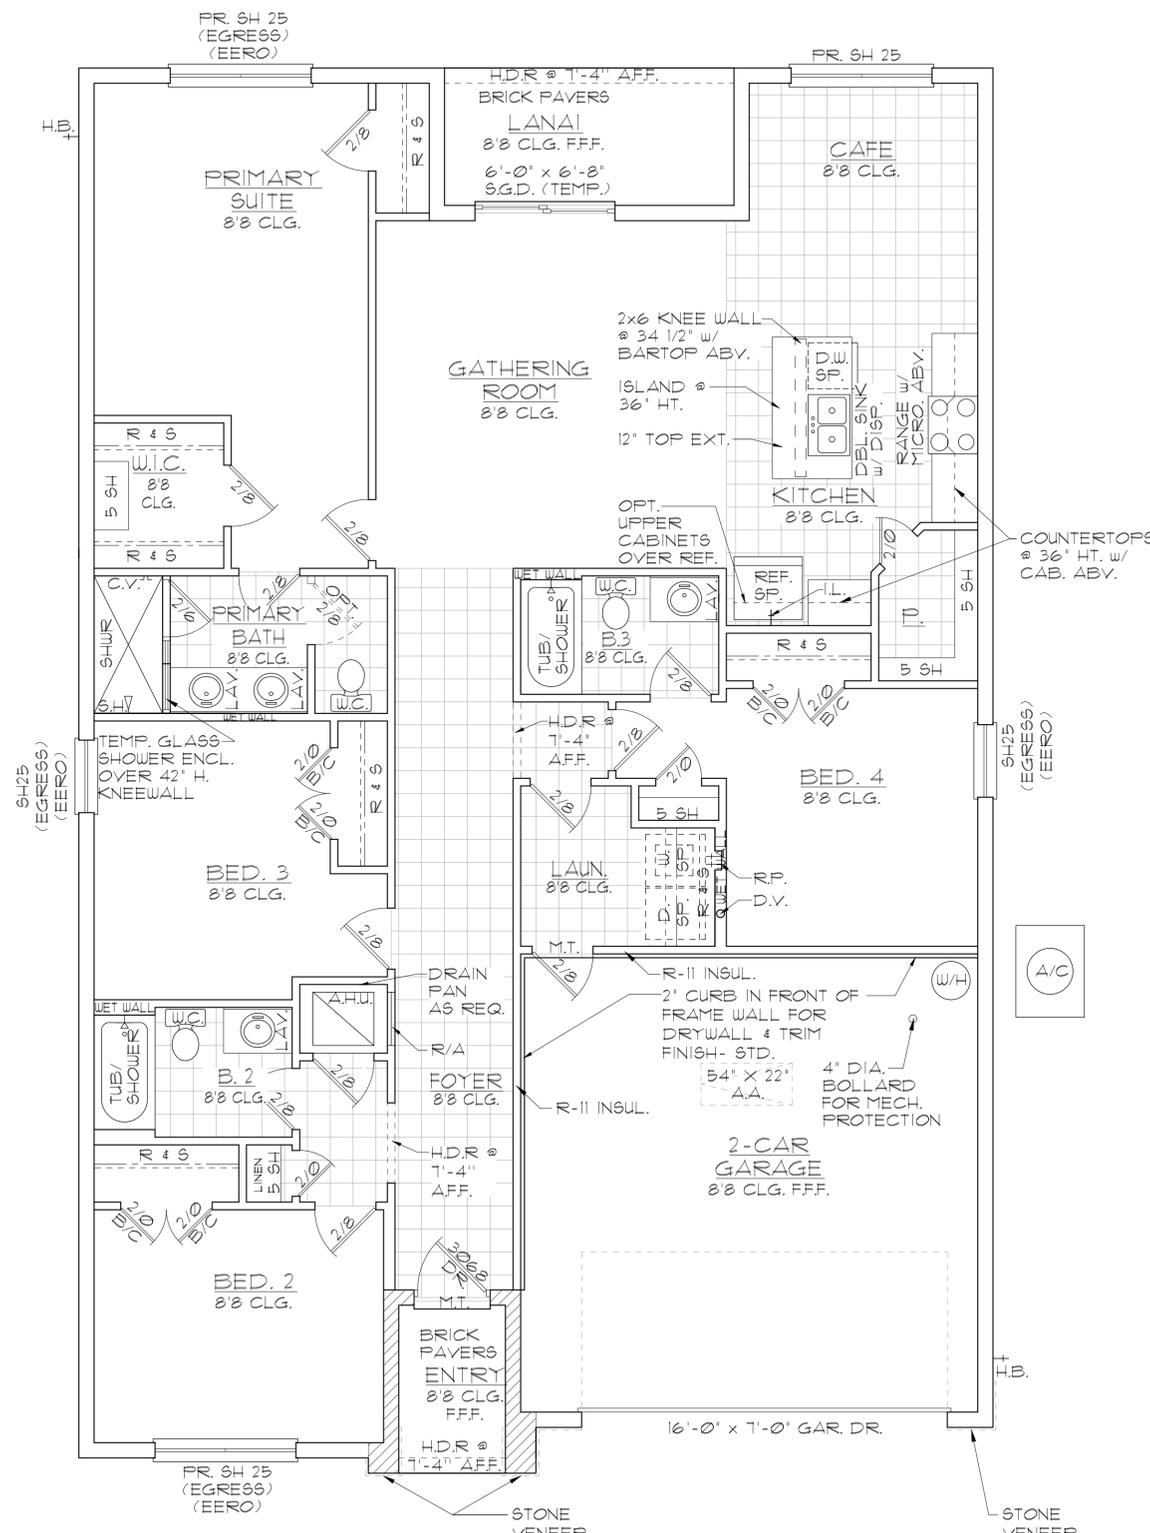

**GENERAL NOTES**

- CONTRACTOR TO VERIFY ALL DIMENSIONS ON JOB SITE.
- DO NOT SCALE PRINTS! CONSTRUCTION TO BE FROM CALCULATED DIMENSIONS ONLY. ANY DISCREPANCIES OR ERRORS TO BE REPORTED PROMPTLY TO SUPERVISOR FOR CLARIFICATION.
- ALL INTERIOR FRAME WALL DIMENSIONS TO BE 3-1/2" UNLESS NOTED OTHERWISE.
- ALL EXTERIOR BLOCK WALL DIMENSIONS TO BE 1-5/8" UNLESS NOTED OTHERWISE.
- DOOR FROM HOUSE TO GARAGE MUST BE SOLID WOOD DOOR NO LESS THAN 1 3/8" IN THICKNESS, SOLID OR HONEYCOMB CORE STEEL DOORS NOT LESS THAN 1 3/8" THICK, OR 20 MIN. FIRE RATED (AW R302.5).
- GARAGE SHALL BE SEPARATED FROM THE RESIDENCE & ITS ATTIC AREA BY NOT LESS THAN 1/2" GYP. BD. APPLIED TO THE GAR. SIDE. PROVIDE 5/8" TYPE 'X' GYP. BD. AT CEILING ONLY APPLIED PERPENDICULAR TO CEILING FRAME.
- PULL ALL DIMENSIONS FROM THE REAR OF THE PLAN.
- SEE GENERAL NOTES PAGE FOR ADDITIONAL INFO.

**WALL LEGEND**


- [Symbol] DENOTES CONC. BLOCK WALL HGT. @ 8'-0" AFF.
- [Symbol] DENOTES CONC. BLOCK WALL HGT. @ 10'-0" AFF.
- [Symbol] DENOTES 2x INSULATED FRAME WALL

NOTE: SEE COLOR SHEET FOR FLOORING & INTERIOR DOOR HEIGHT REQUIREMENTS

**AREA CALCULATIONS**

TOTAL LIVING	1,860 SF.
GARAGE	427 SF.
ENTRY	41 SF.
LANAI	76 SF.
<b>TOTAL UNDER ROOF</b>	<b>2,404 SF.</b>

**ELEVATION C STD**  
**FLOOR PLAN W/ NOTES**  
 1/8" = 1'-0" (11X17) 1/4" = 1'-0" (22X34)

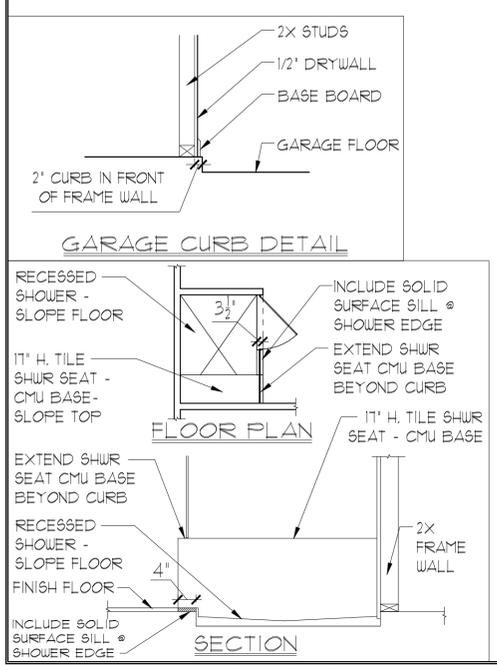

THIS STRUCTURE IS DESIGNED IN ACCORDANCE WITH THE 2018 EDITION, 2023 OF THE FLORIDA BUILDING CODE-RESIDENTIAL AND IS CERTIFIED AS SUCH

**LOT: 0000, COMMUNITY**

1860 SKY

**FLOOR PLAN W/ NOTES**

40' EXPLORATION SERIES

REVISIONS

DELTA #	DATE

DATE: 09-11-25

SCALE: AS NOTED

DRAWN: MR

SHEET: 02.0

**ITEC**  
 THOMPSON ENGINEERING GROUP, INC.  
 4401 Vineyard Road Suite #8 Orlando, FL 32811  
 Phone: (407) 241-1790  
 www.itec.com

**Park Square HOMES**  
 A DIVISION OF PARK SQUARE ENTERPRISES, INC.  
 5200 Vineyard Road, Suite 200  
 Orlando, Florida 32811  
 Phone: (407) 529 - 3000


DISCLAIMER: CONTRACTOR/SUB-CONTRACTOR IS RESPONSIBLE TO REVIEW ALL INFORMATION CONTAINED HEREIN PRIOR TO COMMENCEMENT OF CONSTRUCTION. PARK SQUARE HOMES IS NOT RESPONSIBLE FOR ANY MISINTERPRETATIONS, ERRORS, OMISSIONS OR CUSTOM CHANGES MISSED AND NOT REPORTED PRIOR TO CONSTRUCTION. NO EXCEPTIONS.






EXTERIOR FINISH NOTES

1. LATH TO BE ATTACHED IAW R103.1.1 OF THE 8TH EDITION, FBC-R, 2023 & ASTM C1063 OR C1187.
2. FLASTERING TO BE INSTALLED IAW R103.1 & R103.1.2 OF THE 8TH EDITION, FBC-R, 2023
3. WEEP SCREED TO BE INSTALLED IAW R103.1.2.1 OF THE 8TH EDITION, FBC-R, 2023 & ASTM C926.
4. WATER RESISTANT BARRIER TO BE INSTALLED IAW R103.2 & R103.1.3 OF THE 8TH EDITION, FBC-R, 2023.
5. FLASHING TO BE INSTALLED IAW R103.4 OF THE 8TH EDITION, FBC-R, 2023.
6. WIND RESISTANCE OF WALL COVERINGS & BACK MATERIALS SHALL BE IAW R103.1.2 OF THE 8TH EDITION, FBC-R, 2023.
7. ALL HORIZONTAL & VERTICAL CONTROL JOINTS SHALL BE INSTALLED IAW ASTM 1063.
8. ALL FIBER CEMENT SIDING SHALL BE IAW R103.1 OF THE 8TH EDITION, FBC-R, 2023.
9. "ZIP SYSTEMS" WALL SHEATHING MAY BE USED AS AN ALTERNATIVE FOR WALL SHEATHING AND VAPOR BARRIER, ON EXTERIOR FRAME WALLS.
10. SEE GENERAL NOTES PAGE FOR ADDITIONAL INFORMATION.

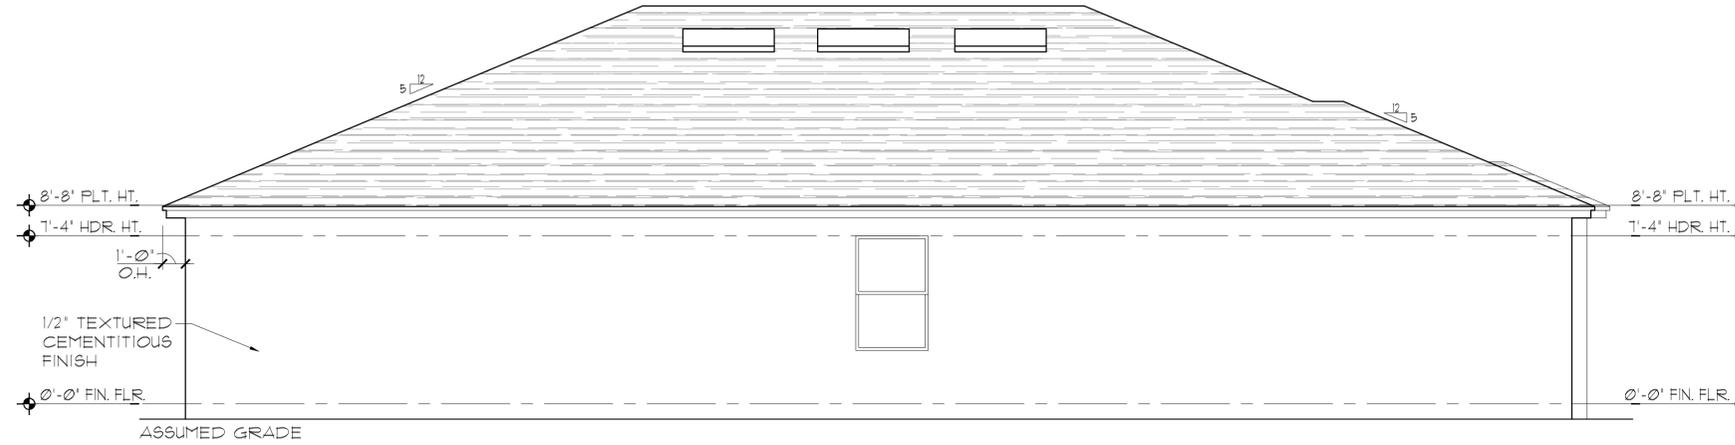

ELEVATION A STD  
LEFT ELEVATION  
1/8"=1'-0" (11X17) 1/4"=1'-0" (22X34)

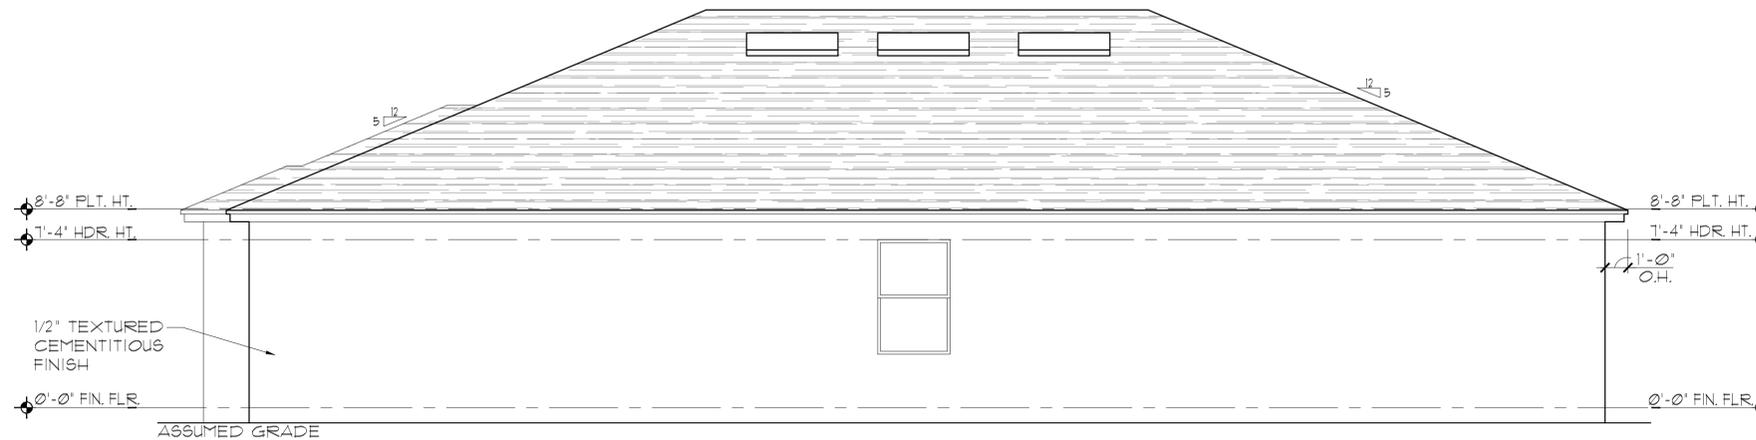

ELEVATION A STD  
RIGHT ELEVATION  
1/8"=1'-0" (11X17) 1/4"=1'-0" (22X34)

THIS STRUCTURE IS DESIGNED IN ACCORDANCE WITH THE 8th EDITION, 2023 OF THE FLORIDA BUILDING CODE-RESIDENTIAL AND IS CERTIFIED AS SUCH

LOT: 0000, COMMUNITY

1860 SKY  
40' EXPLORATION SERIES

REVISIONS	
DELTA #	DATE
DATE:	09-11-25
SCALE:	AS NOTED
DRAWN:	TR
SHEET:	

03.1A




A DIVISION OF PARK SQUARE ENTERPRISES, INC.  
5200 Vineland Road, Suite 200  
Orlando, Florida 32811  
Phone: (407) 529 - 3000




EXTERIOR ELEVATION  
LEFT AND RIGHT

EXTERIOR FINISH NOTES

1. LATH TO BE ATTACHED IAW R103.1.1 OF THE 8TH EDITION, FBC-R, 2023 & ASTM C1063 OR C1181.
2. PLASTERING TO BE INSTALLED IAW R103.1 & R103.1.2 OF THE 8TH EDITION, FBC-R, 2023.
3. WEEP SCREED TO BE INSTALLED IAW R103.1.2.1 OF THE 8TH EDITION, FBC-R, 2023 & ASTM C926.
4. WATER RESISTANT BARRIER TO BE INSTALLED IAW R103.2 & R103.1.3 OF THE 8TH EDITION, FBC-R, 2023.
5. FLASHING TO BE INSTALLED IAW R103.4 OF THE 8TH EDITION, FBC-R, 2023.
6. WIND RESISTANCE OF WALL COVERINGS & BACK MATERIALS SHALL BE IAW R103.1.2 OF THE 8TH EDITION, FBC-R, 2023.
7. ALL HORIZONTAL & VERTICAL CONTROL JOINTS SHALL BE INSTALLED IAW ASTM 1063.
8. ALL FIBER CEMENT SIDING SHALL BE IAW R103.1 OF THE 8TH EDITION, FBC-R, 2023.
9. "ZIP SYSTEMS" WALL SHEATHING MAY BE USED AS AN ALTERNATIVE FOR WALL SHEATHING AND VAPOR BARRIER, ON EXTERIOR FRAME WALLS.
10. SEE GENERAL NOTES PAGE FOR ADDITIONAL INFORMATION.

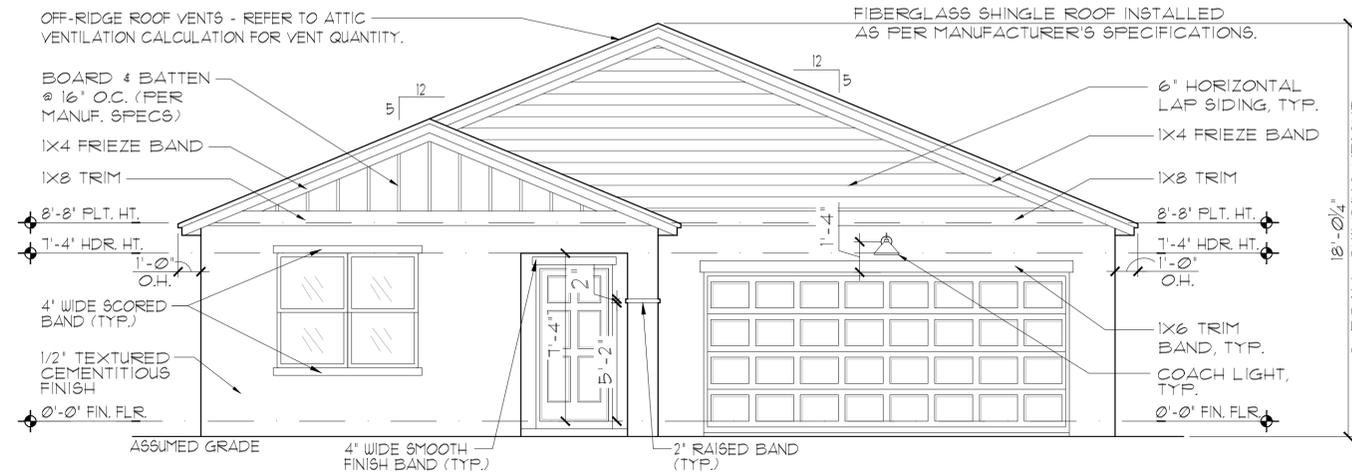

**ELEVATION B STD  
FRONT ELEVATION**  
1/8"=1'-0" (11X17) 1/4"=1'-0" (22X34)

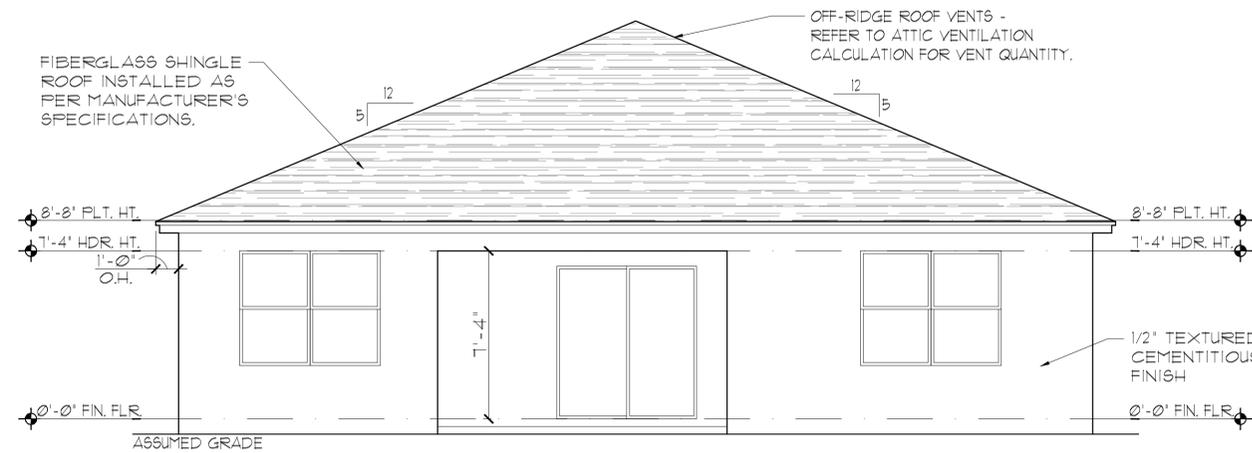

**ELEVATION B STD  
REAR ELEVATION**  
1/8"=1'-0" (11X17) 1/4"=1'-0" (22X34)

THIS STRUCTURE IS DESIGNED IN ACCORDANCE WITH THE 8th EDITION, 2023 OF THE FLORIDA BUILDING CODE-RESIDENTIAL AND IS CERTIFIED AS SUCH

LOT: 0000, COMMUNITY

REVISIONS	
DELTA #	DATE
DATE:	09-11-25
SCALE:	AS NOTED
DRAWN:	MR
SHEET:	03.B

1860 SKY

40' EXPLORATION SERIES

EXTERIOR ELEVATION  
FRONT AND REAR


**Park Square HOMES**  
 A DIVISION OF PARK SQUARE ENTERPRISES, INC.  
 5200 Vineyard Road, Suite 200  
 Orlando, Florida 32811  
 Phone: (407) 529 - 3000

**ITEC**  
 THOMPSON ENGINEERING GROUP, INC.  
 1407 Vineyard Road Suite A8 Orlando, FL 32811  
 Fax: (407) 724-1790  
 www.itec.com

PARK SQUARE HOMES RESERVES COPYRIGHT & OTHER RIGHTS RESTRICTING THESE DOCUMENTS TO THE ORIGINAL SITE OR PURPOSE FOR WHICH THEY WERE PREPARED. REPRODUCTIONS, CHANGES OR ASSIGNMENTS ARE PROHIBITED.


EXTERIOR FINISH NOTES

1. LATH TO BE ATTACHED IAW R103.1.1 OF THE 8TH EDITION, FBC-R, 2023 & ASTM C1063 OR C1187.
2. FLASTERING TO BE INSTALLED IAW R103.1 & R103.1.2 OF THE 8TH EDITION, FBC-R, 2023
3. WEEP SCREED TO BE INSTALLED IAW R103.1.2.1 OF THE 8TH EDITION, FBC-R, 2023 & ASTM C926.
4. WATER RESISTANT BARRIER TO BE INSTALLED IAW R103.2 & R103.1.3 OF THE 8TH EDITION, FBC-R, 2023.
5. FLASHING TO BE INSTALLED IAW R103.4 OF THE 8TH EDITION, FBC-R, 2023.
6. WIND RESISTANCE OF WALL COVERINGS & BACK MATERIALS SHALL BE IAW R103.1.2 OF THE 8TH EDITION, FBC-R, 2023.
7. ALL HORIZONTAL & VERTICAL CONTROL JOINTS SHALL BE INSTALLED IAW ASTM 1063.
8. ALL FIBER CEMENT SIDING SHALL BE IAW R103.1 OF THE 8TH EDITION, FBC-R, 2023.
9. "ZIP SYSTEMS" WALL SHEATHING MAY BE USED AS AN ALTERNATIVE FOR WALL SHEATHING AND VAPOR BARRIER, ON EXTERIOR FRAME WALLS.
10. SEE GENERAL NOTES PAGE FOR ADDITIONAL INFORMATION.

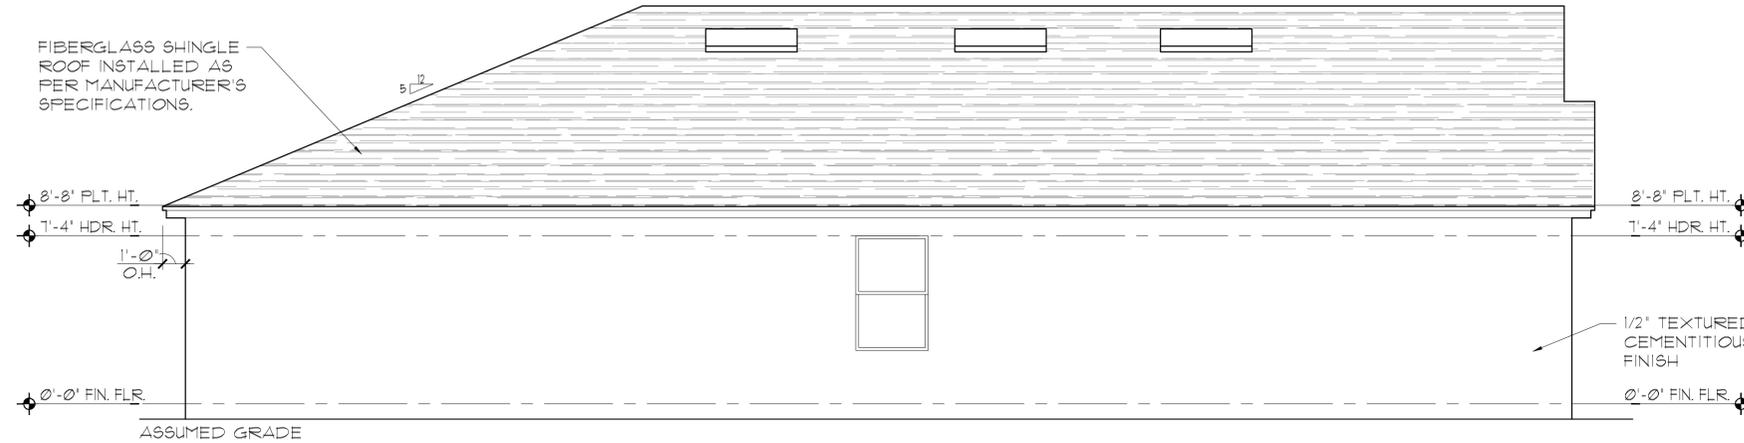

ELEVATION B STD  
LEFT ELEVATION

1/8"=1'-0" (11X17) 1/4"=1'-0" (22X34)

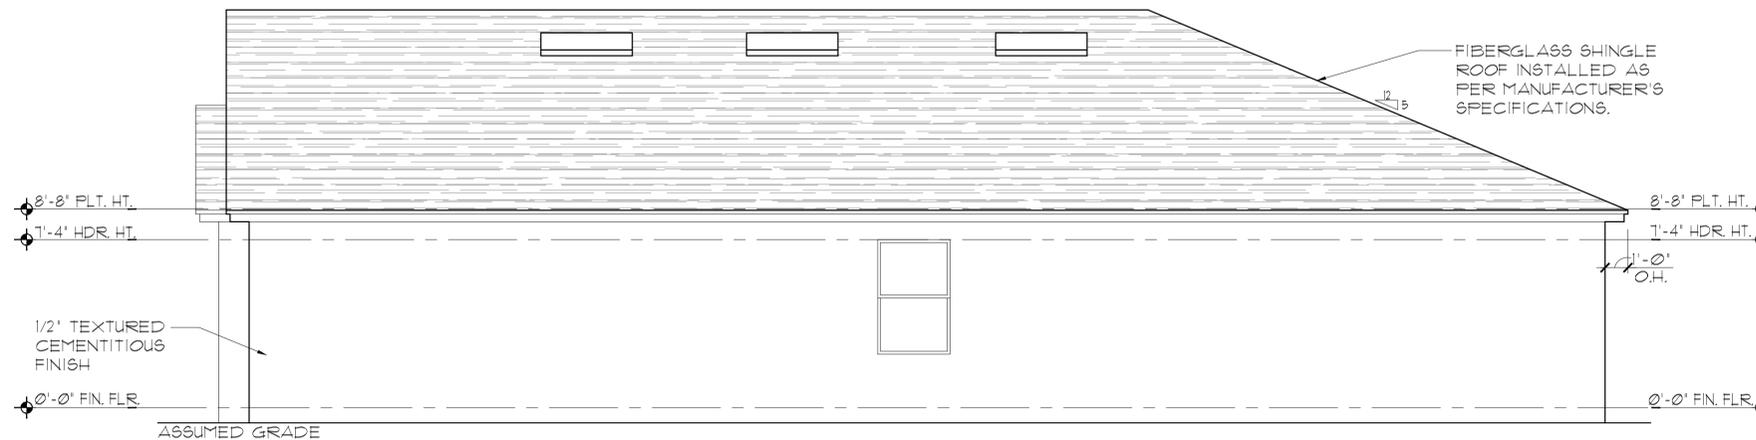

ELEVATION B STD  
RIGHT ELEVATION

1/8"=1'-0" (11X17) 1/4"=1'-0" (22X34)

THIS STRUCTURE IS DESIGNED IN ACCORDANCE WITH THE 8th EDITION, 2023 OF THE FLORIDA BUILDING CODE-RESIDENTIAL AND IS CERTIFIED AS SUCH

LOT: 0000, COMMUNITY

1860 SKY  
40' EXPLORATION SERIES

REVISIONS	
DELTA #	DATE
DATE:	09-11-25
SCALE:	AS NOTED
DRAWN:	TR
SHEET:	03.1B

**Park Square HOMES**  
 A DIVISION OF PARK SQUARE ENTERPRISES, INC.  
 5200 Vineland Road, Suite 200  
 Orlando, Florida 32811  
 Phone: (407) 529 - 3000


**TEG**  
 THOMPSON ENGINEERING GROUP, INC.  
 1441 Vineland Road, Suite 40 Orlando, FL 32811  
 Tel: (407) 724-1700  
 Fax: (407) 724-1700  
 www.tegfl.com

EXTERIOR FINISH NOTES

1. LATH TO BE ATTACHED IAW R103.1.1 OF THE 8TH EDITION, FBC-R, 2023 & ASTM C1063 OR C1187.
2. PLASTERING TO BE INSTALLED IAW R103.1 & R103.1.2 OF THE 8TH EDITION, FBC-R, 2023.
3. WEEP SCREED TO BE INSTALLED IAW R103.1.2.1 OF THE 8TH EDITION, FBC-R, 2023 & ASTM C926.
4. WATER RESISTANT BARRIER TO BE INSTALLED IAW R103.2 & R103.1.3 OF THE 8TH EDITION, FBC-R, 2023.
5. FLASHING TO BE INSTALLED IAW R103.4 OF THE 8TH EDITION, FBC-R, 2023.
6. WIND RESISTANCE OF WALL COVERINGS & BACK MATERIALS SHALL BE IAW R103.1.2 OF THE 8TH EDITION, FBC-R, 2023.
7. ALL HORIZONTAL & VERTICAL CONTROL JOINTS SHALL BE INSTALLED IAW ASTM 1063.
8. ALL FIBER CEMENT SIDING SHALL BE IAW R103.1 OF THE 8TH EDITION, FBC-R, 2023.
9. "ZIP SYSTEMS" WALL SHEATHING MAY BE USED AS AN ALTERNATIVE FOR WALL SHEATHING AND VAPOR BARRIER, ON EXTERIOR FRAME WALLS.
10. SEE GENERAL NOTES PAGE FOR ADDITIONAL INFORMATION.



ELEVATION C STD  
FRONT ELEVATION  
1/8" = 1'-0" (11X17) 1/4" = 1'-0" (22X34)

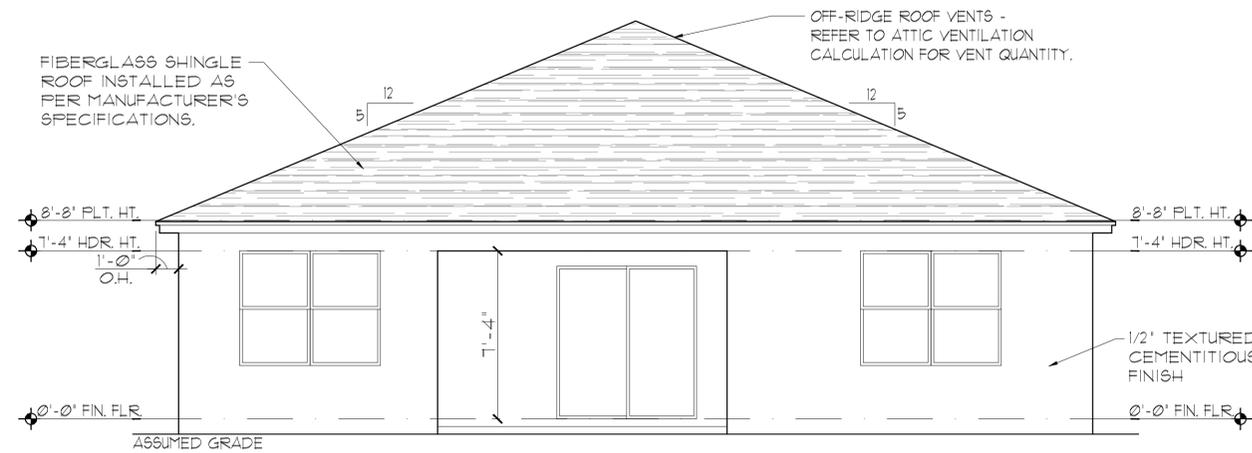

ELEVATION C STD  
REAR ELEVATION  
1/8" = 1'-0" (11X17) 1/4" = 1'-0" (22X34)

THIS STRUCTURE IS DESIGNED IN ACCORDANCE WITH THE 8th EDITION, 2023 OF THE FLORIDA BUILDING CODE-RESIDENTIAL AND IS CERTIFIED AS SUCH

LOT: 0000, COMMUNITY

1860 SKY

40' EXPLORATION SERIES

EXTERIOR ELEVATION  
FRONT AND REAR

**Park Square HOMES**  
A DIVISION OF PARK SQUARE ENTERPRISES, INC.  
5200 Vineyard Road, Suite 200  
Orlando, Florida 32811  
Phone: (407) 629 - 3000


**ITEG**  
THOMPSON ENGINEERING GROUP, INC.  
1407 Vineyard Road Suite A8 Orlando, FL 32811  
Tel: (407) 724-1790  
www.iteg.com

REVISIONS	
DELTA #	DATE


DATE: 09-11-25  
SCALE: AS NOTED  
DRAWN: MR  
SHEET: 03.C

EXTERIOR FINISH NOTES

1. LATH TO BE ATTACHED IAW R103.1.1 OF THE 8TH EDITION, FBC-R, 2023 & ASTM C1063 OR C1187.
2. FLASTERING TO BE INSTALLED IAW R103.1 & R103.1.2 OF THE 8TH EDITION, FBC-R, 2023
3. WEEP SCREED TO BE INSTALLED IAW R103.1.2.1 OF THE 8TH EDITION, FBC-R, 2023 & ASTM C926.
4. WATER RESISTANT BARRIER TO BE INSTALLED IAW R103.2 & R103.1.3 OF THE 8TH EDITION, FBC-R, 2023.
5. FLASHING TO BE INSTALLED IAW R103.4 OF THE 8TH EDITION, FBC-R, 2023.
6. WIND RESISTANCE OF WALL COVERINGS & BACK MATERIALS SHALL BE IAW R103.1.2 OF THE 8TH EDITION, FBC-R, 2023.
7. ALL HORIZONTAL & VERTICAL CONTROL JOINTS SHALL BE INSTALLED IAW ASTM 1063.
8. ALL FIBER CEMENT SIDING SHALL BE IAW R103.1 OF THE 8TH EDITION, FBC-R, 2023.
9. "ZIP SYSTEMS" WALL SHEATHING MAY BE USED AS AN ALTERNATIVE FOR WALL SHEATHING AND VAPOR BARRIER, ON EXTERIOR FRAME WALLS.
10. SEE GENERAL NOTES PAGE FOR ADDITIONAL INFORMATION.

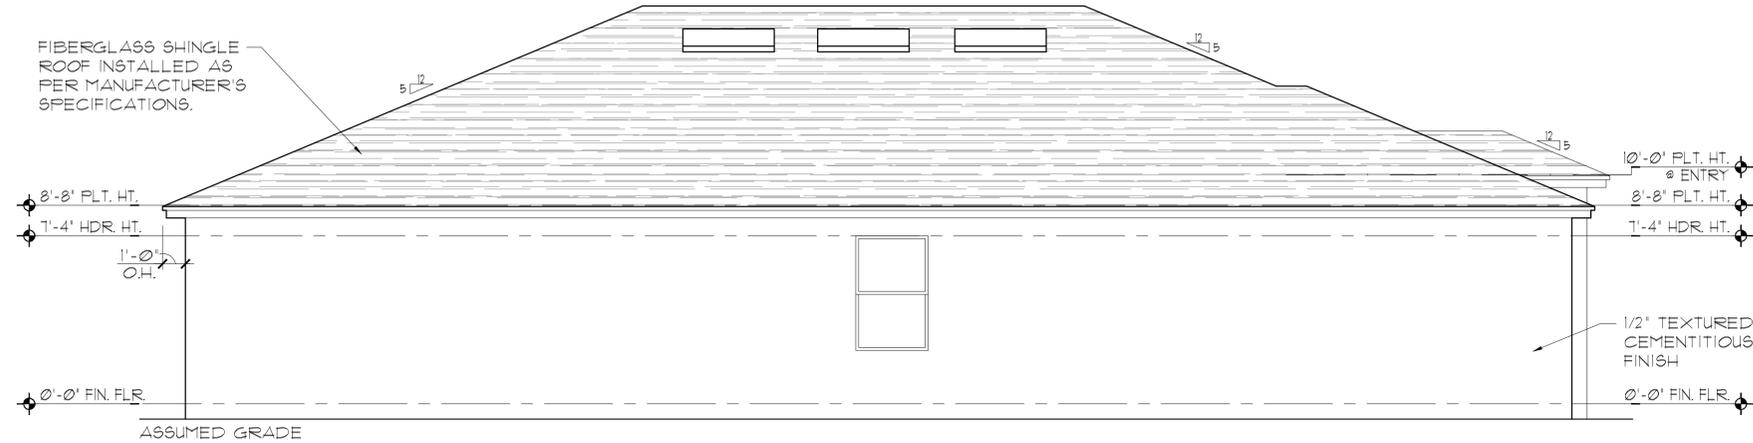

ELEVATION C STD  
LEFT ELEVATION  
1/8" = 1'-0" (11X17) 1/4" = 1'-0" (22X34)

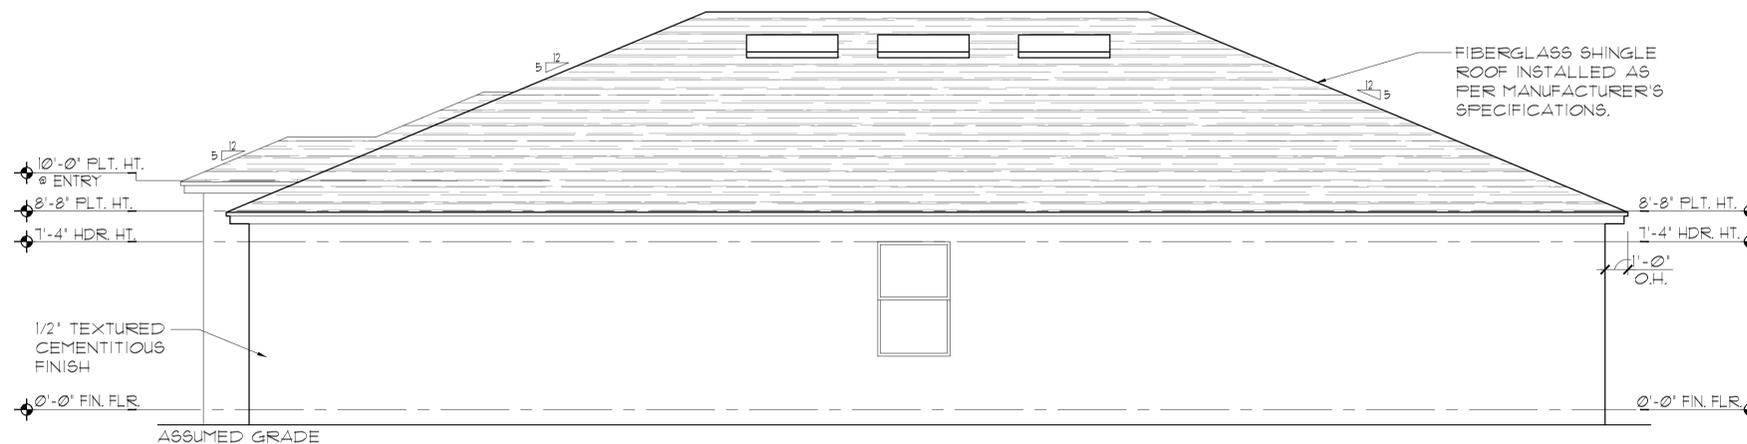

ELEVATION C STD  
RIGHT ELEVATION  
1/8" = 1'-0" (11X17) 1/4" = 1'-0" (22X34)

THIS STRUCTURE IS DESIGNED IN ACCORDANCE WITH THE 8th EDITION, 2023 OF THE FLORIDA BUILDING CODE-RESIDENTIAL AND IS CERTIFIED AS SUCH

LOT: 0000, COMMUNITY


1860 SKY	
40' EXPLORATION SERIES	
REVISIONS	
DELTA #	DATE
DATE:	09-11-25
SCALE:	AS NOTED
DRAWN:	TR
SHEET:	03.1C

EXTERIOR ELEVATION  
LEFT AND RIGHT

**Park Square HOMES**  
 A DIVISION OF PARK SQUARE ENTERPRISES, INC.  
 5200 Vineland Road, Suite 200  
 Orlando, Florida 32811  
 Phone: (407) 529 - 3000

**TEG**  
 THOMPSON ENGINEERING GROUP, INC.  
 1401 Vineland Road, Suite 40 Orlando, FL 32811  
 Tel: (407) 724-1700  
 Fax: (407) 724-1700  
 www.teg.com

REPRODUCTIONS, CHANGES OR ASSIGNMENTS ARE PROHIBITED.

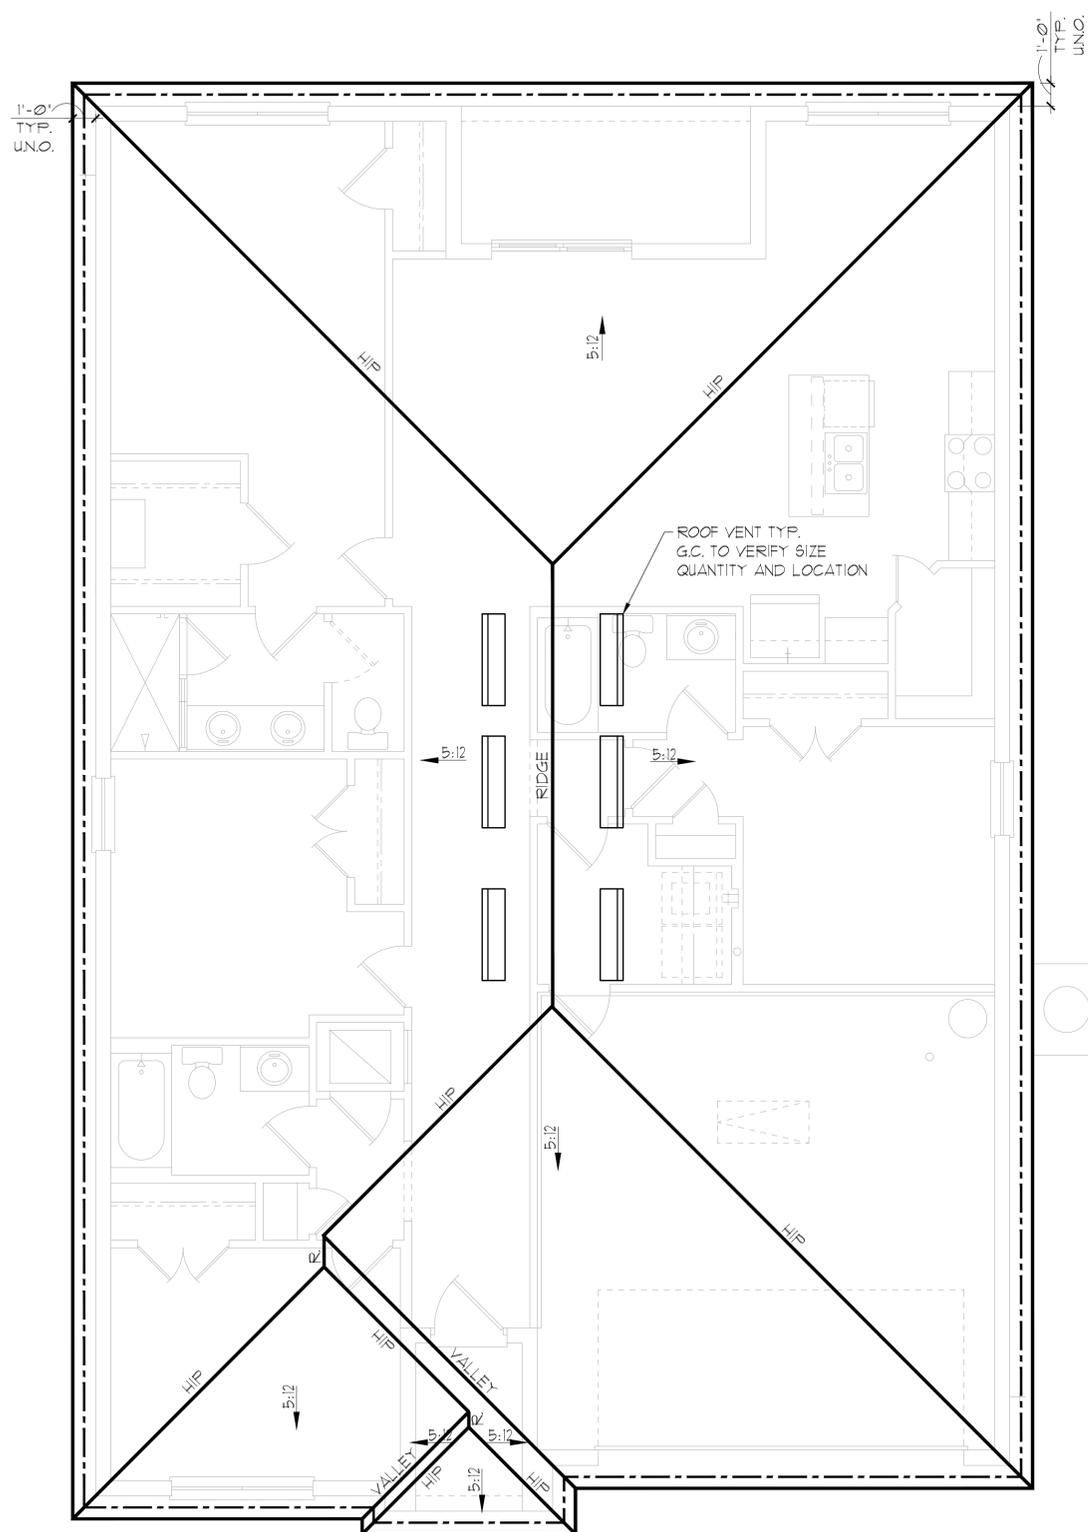

**GENERAL NOTES**

ENCLOSED ATTIC SPACES AND ENCLOSED RAFTER SPACES FORMED WHERE CEILING ARE APPLIED DIRECTLY TO THE UNDERSIDE OF ROOF RAFTERS SHALL HAVE CROSS VENTILATION FOR EACH SEPARATE SPACE BY VENTILATING OPENINGS PROTECTED AGAINST THE ENTRANCE OF RAIN OR SNOW. MINIMUM NET FREE VENTILATING AREA SHALL NOT BE LESS THAN 1/150 OF THE AREA OF THE VENTED SPACE, (EXCEPT THAT THE REDUCTION OF THE TOTAL AREA TO 1/300 IS PERMITTED, PROVIDED THAT AT LEAST 40% AND NOT MORE THAN 50% OF THE REQUIRED VENTILATING AREA IS PROVIDED BY VENTILATORS LOCATED IN THE UPPER PORTION OF THE SPACE TO BE VENTILATED AT NO MORE THAN 3 FEET BELOW THE RIDGE OR HIGHEST POINT OF SPACE, MEASURED VERTICALLY, WITH THE BALANCE OF THE REQUIRED VENTILATION PROVIDED BY EAVE OR CORNICE VENTS.)

1. PLAN SHOWS APPROXIMATE VENT LOCATIONS AND STILL REQUIRES REVIEW BY THE BUILDER/G.C. TO VERIFY ALL VENTING COMPONENTS ARE INSTALLED PER THE MIN. REQUIREMENTS AS STATED IN THE CURRENT EDITION OF THE FBC(R) SECTION R206 AND ALL SUBSEQUENT SUB-SECTIONS.
2. WHERE EAVE OR CORNICE VENTS ARE INSTALLED, PROVIDE Baffles TO MAINTAIN A MIN. 1' AIRSPACE BETWEEN INSULATION AND ROOF SHEATHING AND AT THE LOCATION OF THE VENT.
3. VENTILATION OPENINGS SHALL HAVE A LEAST DIMENSIONS OF 1/16" MIN. AND 1/4" MAX. VENTILATION OPENINGS HAVING A LEAST DIMENSION GREATER THAN 1/4" SHALL BE PROVIDED WITH AN APPROVED CORROSION PROTECTIVE COVER HAVING A LEAST DIMENSIONS OF 1/16" AND 1/4" MAXIMUM.
4. ALL VENTS SHALL BE INSTALLED PER THE MANUFACTURER'S WRITTEN SPECIFICATIONS (FREE FROM BLOCKAGES AND/OR OBSTRUCTIONS) PROVIDING ADEQUATE CROSS VENTILATION.
5. THE BUILDER/ROOFING CONTRACTOR SHALL BE RESPONSIBLE TO VERIFY ALL CALCULATIONS AND QUANTITIES OF REQUIRED VENTILATORS PRIOR TO INSTALLATION.
6. ROOF PLAN DEPICTED IS NOT INTENDED TO SERVE AS A TRUSS DESIGN
7. SEE BUILDING SECTIONS, WALL SECTIONS & ELEVATIONS FOR BEARING HEIGHTS

CALCULATIONS BELOW ARE BASED OFF OF THE FOLLOWING ASSUMPTIONS:

OFF RIDGE VENTS TO HAVE A NET FREE VENTILATION AREA OF:

- SHINGLE: MILLENNIUM METALS-MM1-2 = 80.5 SQ. INCHES PER VENT INSTALLED
- LOMANCO-T10D = 140 SQ. INCHES PER VENT INSTALLED

INDICATES POSSIBLE LOCATION OF OFF RIDGE VENTS

SOFFIT VENTILATION TO HAVE A NET FREE VENTILATION AREA OF 10 SQ. INCHES PER LINEAR FOOT

INDICATES POSSIBLE LOCATION OF SOFFIT VENTING

**ATTIC VENTILATION CALCULATIONS**


NET FREE VENTILATED AREA(S):  
 (OHAGIN- MODEL 'S')  
 $NFVA = 2,404 \text{ SQ. FT} \cdot 144 / 300 = 462\text{-}511 \text{ SQ. IN. REQUIRED (40\%-50\%)}$   
 (5) OFF RIDGE VENTS @ 91.5 SQ. IN. (OHAGIN- MODEL 'S') = 488 SQ. IN. PROVIDED  
 (MILLENNIUM METALS- MM1-2)  
 $NFVA = 2,404 \text{ SQ. FT} \cdot 144 / 300 = 462\text{-}511 \text{ SQ. IN. REQUIRED (40\%-50\%)}$   
 (6) OFF RIDGE VENTS @ 80.5 SQ. IN. (MILLENNIUM METALS- MM1-2) = 483 SQ. IN. PROVIDED  
 (LOMANCO-T10D)  
 $NFVA = 2,404 \text{ SQ. FT} \cdot 144 / 300 = 462\text{-}511 \text{ SQ. IN. REQUIRED (40\%-50\%)}$   
 (4) OFF RIDGE VENTS @ 140 SQ. IN. (LOMANCO-T10D) = 560 SQ. IN. PROVIDED  
 +/- 200 LINEAR FEET OF VENTED SOFFIT.

THIS STRUCTURE IS DESIGNED IN ACCORDANCE WITH THE 8th EDITION, 2023 OF THE FLORIDA BUILDING CODE-RESIDENTIAL AND IS CERTIFIED AS SUCH

LOT: 0000, COMMUNITY

ELEVATION A STD  
 ROOF PLAN  
 1/8"=1'-0" (11X17) 1/4"=1'-0" (22X34)

 THOMPSON ENGINEERING GROUP, INC. 4401 Vineland Road, Suite 40 Orlando, FL 32811 Tel: (407) 724-1700 Fax: (407) 724-1700 www.teg.com	
A DIVISION OF PARK SQUARE ENTERPRISES, INC. 5200 Vineland Road, Suite 200 Orlando, Florida 32811 Phone: (407) 529 - 3000	
ROOF PLAN	
1860 SKY	
40' EXPLORATION SERIES	
REVISIONS	
DELTA #	DATE
DATE:	09-11-25
SCALE:	AS NOTED
DRAWN:	TR
SHEET:	04.A

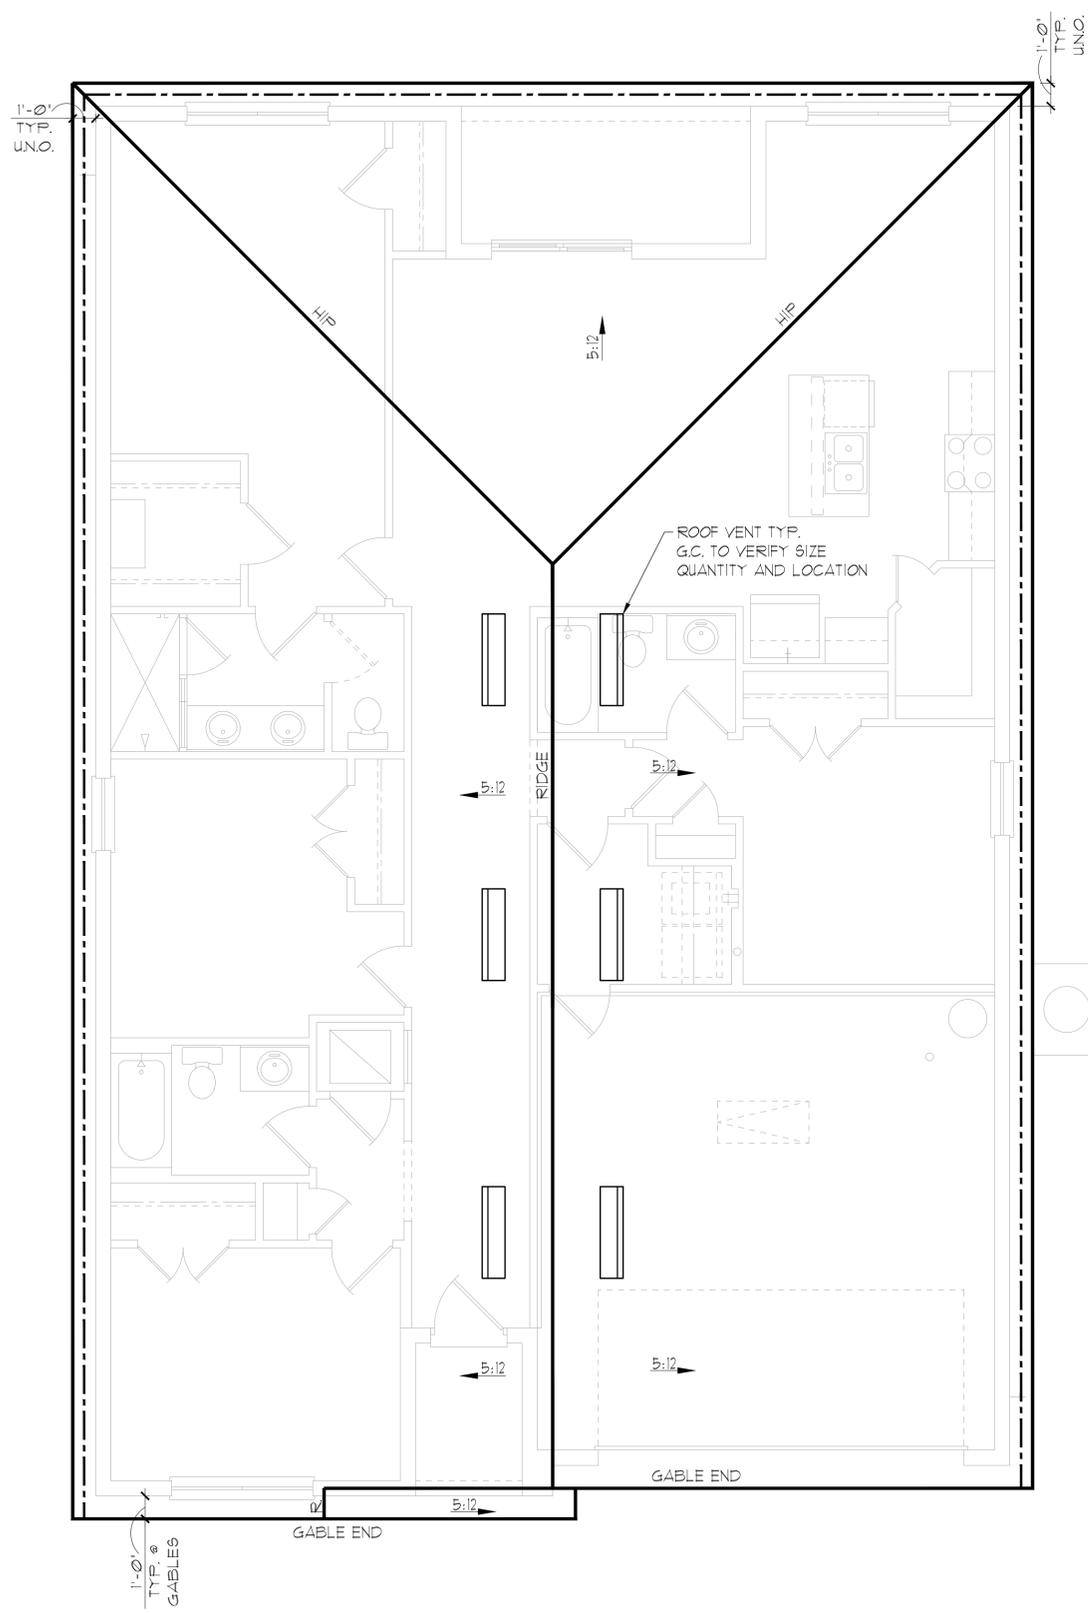

**GENERAL NOTES**

ENCLOSED ATTIC SPACES AND ENCLOSED RAFTER SPACES FORMED WHERE CEILING ARE APPLIED DIRECTLY TO THE UNDERSIDE OF ROOF RAFTERS SHALL HAVE CROSS VENTILATION FOR EACH SEPARATE SPACE BY VENTILATING OPENINGS PROTECTED AGAINST THE ENTRANCE OF RAIN OR SNOW. MINIMUM NET FREE VENTILATING AREA SHALL NOT BE LESS THAN 1/150 OF THE AREA OF THE VENTED SPACE, (EXCEPT THAT THE REDUCTION OF THE TOTAL AREA TO 1/300 IS PERMITTED, PROVIDED THAT AT LEAST 40% AND NOT MORE THAN 50% OF THE REQUIRED VENTILATING AREA IS PROVIDED BY VENTILATORS LOCATED IN THE UPPER PORTION OF THE SPACE TO BE VENTILATED AT NO MORE THAN 3 FEET BELOW THE RIDGE OR HIGHEST POINT OF SPACE, MEASURED VERTICALLY, WITH THE BALANCE OF THE REQUIRED VENTILATION PROVIDED BY EAVE OR CORNICE VENTS.)

1. PLAN SHOWS APPROXIMATE VENT LOCATIONS AND STILL REQUIRES REVIEW BY THE BUILDER/G.C. TO VERIFY ALL VENTING COMPONENTS ARE INSTALLED PER THE MIN. REQUIREMENTS AS STATED IN THE CURRENT EDITION OF THE FBC(R) SECTION R206 AND ALL SUBSEQUENT SUB-SECTIONS.
2. WHERE EAVE OR CORNICE VENTS ARE INSTALLED, PROVIDE Baffles TO MAINTAIN A MIN. 1' AIRSPACE BETWEEN INSULATION AND ROOF SHEATHING AND AT THE LOCATION OF THE VENT.
3. VENTILATION OPENINGS SHALL HAVE A LEAST DIMENSIONS OF 1/16" MIN. AND 1/4" MAX. VENTILATION OPENINGS HAVING A LEAST DIMENSION GREATER THAN 1/4" SHALL BE PROVIDED WITH AN APPROVED CORROSION PROTECTIVE COVER HAVING A LEAST DIMENSIONS OF 1/16" AND 1/4" MAXIMUM.
4. ALL VENTS SHALL BE INSTALLED PER THE MANUFACTURER'S WRITTEN SPECIFICATIONS (FREE FROM BLOCKAGES AND/OR OBSTRUCTIONS) PROVIDING ADEQUATE CROSS VENTILATION.
5. THE BUILDER/ROOFING CONTRACTOR SHALL BE RESPONSIBLE TO VERIFY ALL CALCULATIONS AND QUANTITIES OF REQUIRED VENTILATORS PRIOR TO INSTALLATION.
6. ROOF PLAN DEPICTED IS NOT INTENDED TO SERVE AS A TRUSS DESIGN
7. SEE BUILDING SECTIONS, WALL SECTIONS & ELEVATIONS FOR BEARING HEIGHTS

CALCULATIONS BELOW ARE BASED OFF OF THE FOLLOWING ASSUMPTIONS:

OFF RIDGE VENTS TO HAVE A NET FREE VENTILATION AREA OF:

- SHINGLE: MILLENNIUM METALS-MM1-2 = 80.5 SQ. INCHES PER VENT INSTALLED
- LOMANCO-T10D = 140 SQ. INCHES PER VENT INSTALLED

INDICATES POSSIBLE LOCATION OF OFF RIDGE VENTS

SOFFIT VENTILATION TO HAVE A NET FREE VENTILATION AREA OF 10 SQ. INCHES PER LINEAR FOOT

INDICATES POSSIBLE LOCATION OF SOFFIT VENTING

**ATTIC VENTILATION CALCULATIONS**


NET FREE VENTILATED AREA(S):  
 (OHAGIN- MODEL 'S')  
 $NFVA = 2,404 \text{ SQ. FT} \cdot 144 / 300 = 462\text{-}511 \text{ SQ. IN. REQUIRED (40\%-50\%)}$   
 (5) OFF RIDGE VENTS @ 91.5 SQ. IN. (OHAGIN- MODEL 'S') = 488 SQ. IN. PROVIDED  
 (MILLENNIUM METALS- MM1-2)  
 $NFVA = 2,404 \text{ SQ. FT} \cdot 144 / 300 = 462\text{-}511 \text{ SQ. IN. REQUIRED (40\%-50\%)}$   
 (6) OFF RIDGE VENTS @ 80.5 SQ. IN. (MILLENNIUM METALS- MM1-2) = 483 SQ. IN. PROVIDED  
 (LOMANCO-T10D)  
 $NFVA = 2,404 \text{ SQ. FT} \cdot 144 / 300 = 462\text{-}511 \text{ SQ. IN. REQUIRED (40\%-50\%)}$   
 (4) OFF RIDGE VENTS @ 140 SQ. IN. (LOMANCO-T10D) = 560 SQ. IN. PROVIDED  
 +/- 200 LINEAR FEET OF VENTED SOFFIT.

THIS STRUCTURE IS DESIGNED IN ACCORDANCE WITH THE 8th EDITION, 2023 OF THE FLORIDA BUILDING CODE-RESIDENTIAL AND IS CERTIFIED AS SUCH

LOT: 0000, COMMUNITY

ELEVATION B STD  
 ROOF PLAN  
 1/8"=1'-0" (11X17) 1/4"=1'-0" (22X34)

 THOMPSON ENGINEERING GROUP, INC. 4401 Vineland Road Suite #8 Orlando, FL 32811 Tel: (407) 724-1700 Fax: (407) 724-1700 www.teg.com	
A DIVISION OF PARK SQUARE ENTERPRISES, INC. 5200 Vineland Road, Suite 200 Orlando, Florida 32811 Phone: (407) 529 - 3000	
ROOF PLAN	
1860 SKY	
40' EXPLORATION SERIES	
REVISIONS	
DELTA #	DATE
DATE:	09-11-25
SCALE:	AS NOTED
DRAWN:	TR
SHEET:	04.B

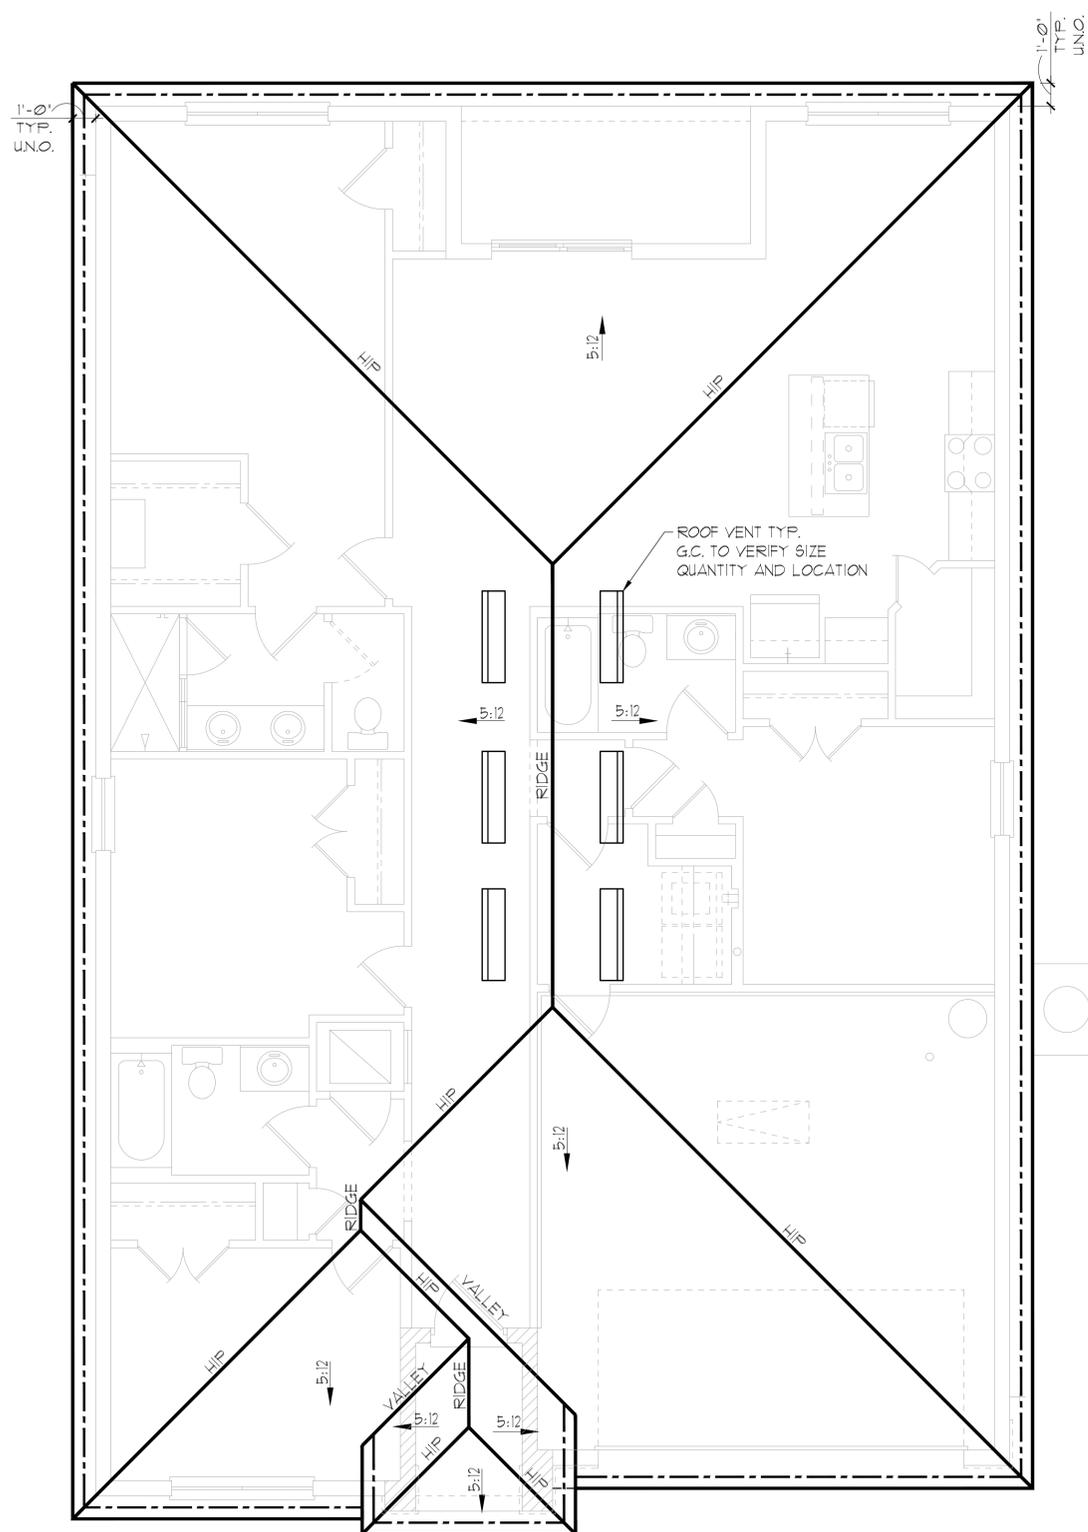

**GENERAL NOTES**

ENCLOSED ATTIC SPACES AND ENCLOSED RAFTER SPACES FORMED WHERE CEILING ARE APPLIED DIRECTLY TO THE UNDERSIDE OF ROOF RAFTERS SHALL HAVE CROSS VENTILATION FOR EACH SEPARATE SPACE BY VENTILATING OPENINGS PROTECTED AGAINST THE ENTRANCE OF RAIN OR SNOW. MINIMUM NET FREE VENTILATING AREA SHALL NOT BE LESS THAN 1/50 OF THE AREA OF THE VENTED SPACE, (EXCEPT THAT THE REDUCTION OF THE TOTAL AREA TO 1/300 IS PERMITTED, PROVIDED THAT AT LEAST 40% AND NOT MORE THAN 50% OF THE REQUIRED VENTILATING AREA IS PROVIDED BY VENTILATORS LOCATED IN THE UPPER PORTION OF THE SPACE TO BE VENTILATED AT NO MORE THAN 3 FEET BELOW THE RIDGE OR HIGHEST POINT OF SPACE, MEASURED VERTICALLY, WITH THE BALANCE OF THE REQUIRED VENTILATION PROVIDED BY EAVE OR CORNICE VENTS.)

1. PLAN SHOWS APPROXIMATE VENT LOCATIONS AND STILL REQUIRES REVIEW BY THE BUILDER/G.C. TO VERIFY ALL VENTING COMPONENTS ARE INSTALLED PER THE MIN. REQUIREMENTS AS STATED IN THE CURRENT EDITION OF THE FBC(R) SECTION R206 AND ALL SUBSEQUENT SUB-SECTIONS.
2. WHERE EAVE OR CORNICE VENTS ARE INSTALLED, PROVIDE Baffles TO MAINTAIN A MIN. 1' AIRSPACE BETWEEN INSULATION AND ROOF SHEATHING AND AT THE LOCATION OF THE VENT.
3. VENTILATION OPENINGS SHALL HAVE A LEAST DIMENSIONS OF 1/16" MIN. AND 1/4" MAX. VENTILATION OPENINGS HAVING A LEAST DIMENSION GREATER THAN 1/4" SHALL BE PROVIDED WITH AN APPROVED CORROSION PROTECTIVE COVER HAVING A LEAST DIMENSIONS OF 1/16" AND 1/4" MAXIMUM.
4. ALL VENTS SHALL BE INSTALLED PER THE MANUFACTURER'S WRITTEN SPECIFICATIONS (FREE FROM BLOCKAGES AND/OR OBSTRUCTIONS) PROVIDING ADEQUATE CROSS VENTILATION.
5. THE BUILDER/ROOFING CONTRACTOR SHALL BE RESPONSIBLE TO VERIFY ALL CALCULATIONS AND QUANTITIES OF REQUIRED VENTILATORS PRIOR TO INSTALLATION.
6. ROOF PLAN DEPICTED IS NOT INTENDED TO SERVE AS A TRUSS DESIGN
7. SEE BUILDING SECTIONS, WALL SECTIONS & ELEVATIONS FOR BEARING HEIGHTS

CALCULATIONS BELOW ARE BASED OFF OF THE FOLLOWING ASSUMPTIONS:

OFF RIDGE VENTS TO HAVE A NET FREE VENTILATION AREA OF:

- SHINGLE: MILLENNIUM METALS-MM1-2 = 80.5 SQ. INCHES PER VENT INSTALLED
- LOMANCO-T10D = 140 SQ. INCHES PER VENT INSTALLED

INDICATES POSSIBLE LOCATION OF OFF RIDGE VENTS

SOFFIT VENTILATION TO HAVE A NET FREE VENTILATION AREA OF 10 SQ. INCHES PER LINEAR FOOT

INDICATES POSSIBLE LOCATION OF SOFFIT VENTING

**ATTIC VENTILATION CALCULATIONS**

NET FREE VENTILATED AREA(S):  
(O'HAGIN- MODEL 'S')  
NFVA = 2,404 SQ. FT \* 144 / 300 = 462-511 SQ. IN. REQUIRED (40%-50%)  
(5) OFF RIDGE VENTS @ 91.5 SQ. IN. (O'HAGIN- MODEL 'S') = 488 SQ. IN. PROVIDED

(MILLENNIUM METALS- MM1-2)  
NFVA = 2,404 SQ. FT \* 144 / 300 = 462-511 SQ. IN. REQUIRED (40%-50%)  
(6) OFF RIDGE VENTS @ 80.5 SQ. IN. (MILLENNIUM METALS- MM1-2) = 483 SQ. IN. PROVIDED

(LOMANCO-T10D)  
NFVA = 2,404 SQ. FT \* 144 / 300 = 462-511 SQ. IN. REQUIRED (40%-50%)  
(4) OFF RIDGE VENTS @ 140 SQ. IN. (LOMANCO-T10D) = 560 SQ. IN. PROVIDED



+/- 200 LINEAR FEET OF VENTED SOFFIT.

ELEVATION C STD  
**ROOF PLAN**  
1/8"=1'-0" (11X17) 1/4"=1'-0" (22X34)

THIS STRUCTURE IS DESIGNED IN ACCORDANCE WITH THE 8th EDITION, 2023 OF THE FLORIDA BUILDING CODE-RESIDENTIAL AND IS CERTIFIED AS SUCH

LOT: 0000, COMMUNITY

 A DIVISION OF PARK SQUARE ENTERPRISES, INC. 5200 Vineland Road, Suite 200 Orlando, Florida 32811 Phone: (407) 529 - 3000		ROOF PLAN	
		1860 SKY	40' EXPLORATION SERIES
REVISIONS			
DELTA #	DATE		
DATE:	09-11-25		
SCALE:	AS NOTED		
DRAWN:	TR		
SHEET:	04.C		

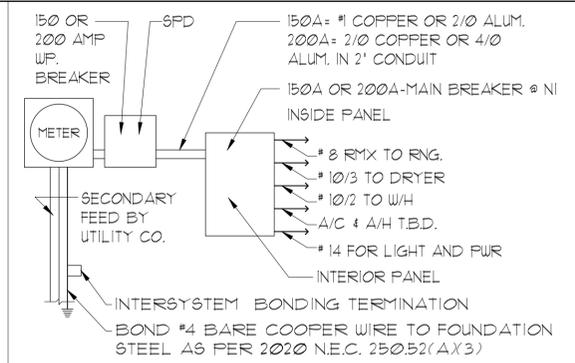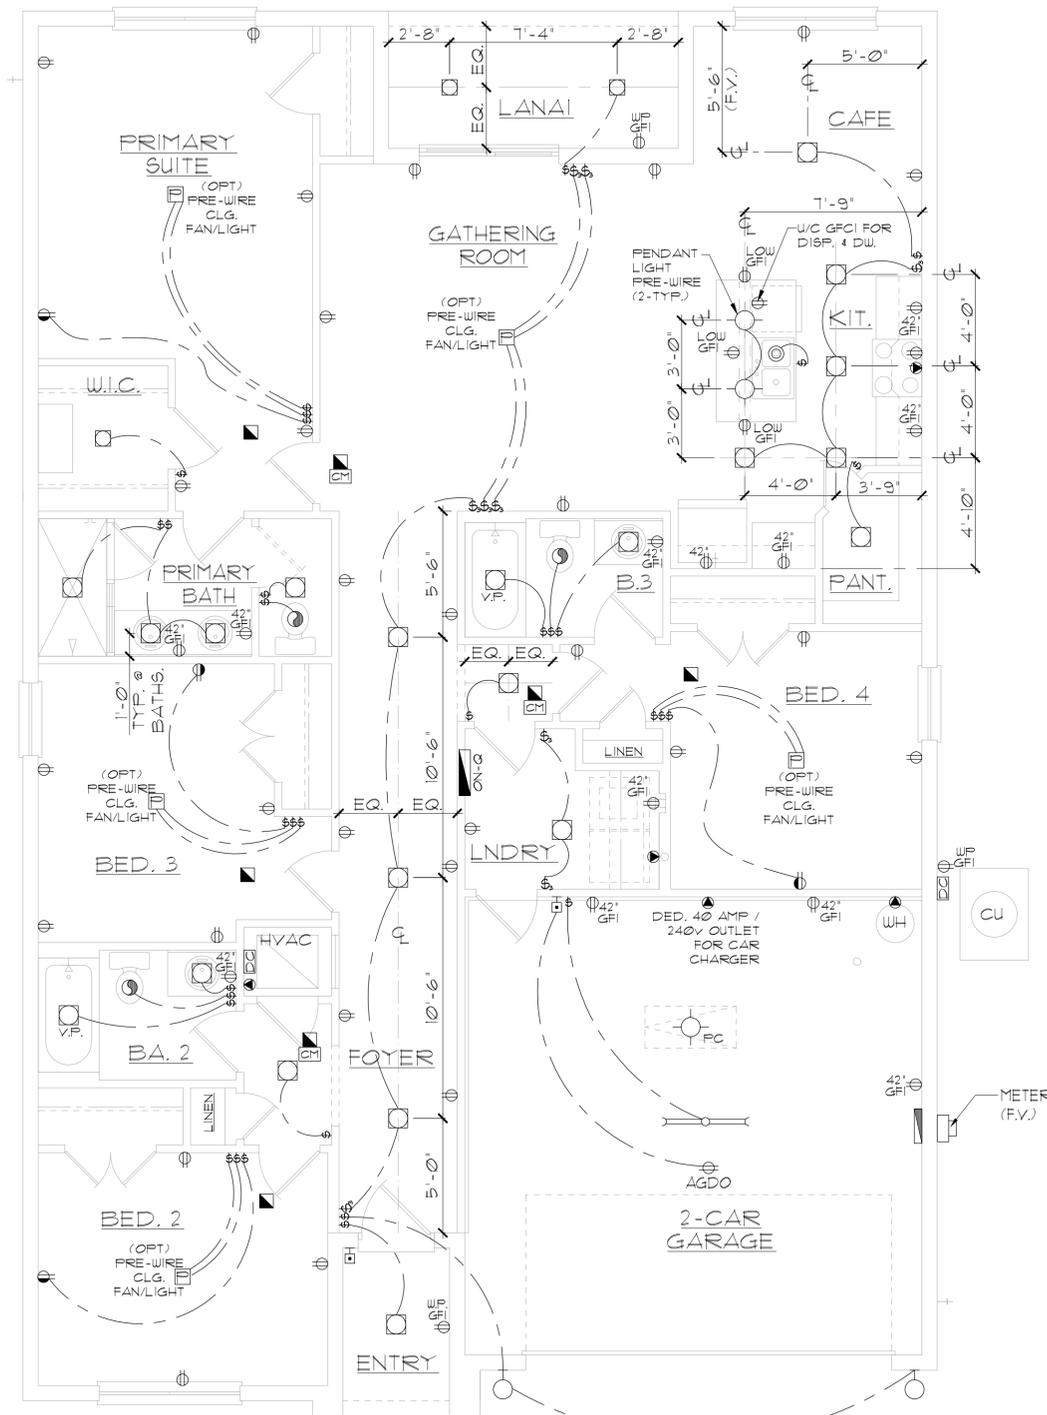

**ELECTRICAL RISER DIAGRAM**  
N.T.S.

NOTES:  
 1. ELECTRICAL MATERIALS AND INSTALLATIONS SHALL COMPLY W/ APPLICABLE PROVISIONS OF THE NATIONAL ELEC. CODE 250.52(A)1 TO (6), NFPA 70, LOCAL CODES, AND THE LOCAL POWER/UTILITY COMPANY.  
 2. ALL SERVICES SUPPLYING DWELLING UNITS SHALL BE PROVIDED WITH A SURGE-PROTECTION DEVICE (SPD) THE SPD SHALL BE A TYPE 1 OR TYPE 2 SPD.  
 3. SEE GENERAL NOTES PAGE FOR ADDITIONAL INFORMATION.

250.52(A)3 Concrete-Encased Electrode.  
 Concrete-encased electrodes can be horizontal or vertical and must be at least 20 ft. long. Concrete-encased electrodes can be horizontal or vertical and must be at least 20 ft. long. There are two types of concrete-encased electrodes: (1) steel reinforcing bars or rods which are not less than 1/2 inch in diameter and at least 20 ft. long, encased in 2 inches of concrete; (2) 20 ft. of bare copper conductor not smaller than No. 4 AWG encased in 2 inches of concrete. The steel reinforcing rods must be in a location that is in direct contact with the earth. The reinforcing rods can be connected with tie wires, and a single length of rod can be used as the concrete-encased electrode. The reinforcing rods cannot be coated with non-conductive material. Section 250.50 requires a concrete-encased electrode to be connected to the grounding electrode system if it is present. Several states have modified this requirement to say a concrete-encased electrode must be used as a grounding electrode only if it is available. In those jurisdictions, if the footings or foundations have been poured before the electrical contractor arrives at the site, and a reinforcing rod is not available for use as a grounding electrode, then a grounding connection to the reinforcing rod is not required.

**ELECTRICAL LEGEND**

⊙	SINGLE POLE SWITCH	◀	OUTLET, PHONE
⊙	THREE WAY SWITCH	◻	INTERCOM
⊙	OUTLET 110-115	⊞	CHIMES
⊙	OUTLET 110-115, SPLIT WIRED	⊞	SMOKE DETECTOR/SMOKE ALARM W/ INTEGRATED SOUNDER BASE
⊙	OUTLET 110-115, W/ USB	⊞	CARBON MONOXIDE
⊙	OUTLET 110-115, CEILING MOUNTED	⊞	PUSH BUTTON
⊙	OUTLET 110-115, FLOOR MOUNTED	⊞	EXHAUST FAN
⊙	SPECIAL PURPOSE 220-240	⊞	EX. FAN/LIGHT COMBO
⊙	LIGHT FIXTURE, CEILING MOUNTED	⊞	DISPOSAL
⊙	LIGHT FIXTURE, WALL MOUNTED	⊞	ON-O PANEL
⊙	LED LIGHT FIXTURE, RECESSED	⊞	ELECTRICAL PANEL
⊙	LIGHT FIXTURE, RECESSED ADJUST.	⊞	CEILING FAN, PREWIRE
⊙	LIGHT FIXTURE, FULL CHAIN	⊞	CEILING FAN, INSTALL
⊙	LED LIGHT FIXTURE, FLUORESCENT	⊞	ELEC. JUNCTION BOX
⊙	LIGHT FIXTURE, EXTERIOR FLOODS	⊞	THERMOSTAT
⊙	LIGHT FIXTURE, EMERGENCY EXIT	⊞	DISCONNECT SWITCH
⊙	LIGHT FIXTURE, EXIT/BACKUP	⊞	ELEC. POWER METER
⊙	OUTLET, TV/CABLE		

ELECTRICAL DEVICES	ABOVE FIN. FLR.
SWITCHES AND WALL OUTLETS OVER COUNTERS	48" TO CL.
REMAINING SWITCHES	48" TO CL.
WALL OUTLETS	12" TO CL.
TELEPHONE OUTLETS	12" TO CL.
TELEVISION OUTLETS	12" TO CL.
EXTERIOR GFI'S	12" TO CL.
GARAGE GFI'S (ABOVE GARAGE FLOOR)	48" TO CL.
THERMOSTAT	54" TO CL.
DOOR BELL CHIMES	84" TO CL.
DOOR BELL BUTTON	LEVEL W/ DOOR HANDLE
KITCHEN HOOD FAN "WHIP"	66" TO CL.
KITCHEN WALL HUNG MICROWAVE RECEPTACLE	16" TO CL.
KITCHEN DISHWASHER RECEPTACLE	UNDER SINK
KITCHEN RANGE	24" TO CL.
KITCHEN REFRIGERATOR	48" TO CL.
WASHER/DRYER OUTLET	36" TO CL.
HOLLYWOOD LIGHTS	84" TO CL.

CL. = CENTER LINE

NOTE: SEE FINAL COLOR SHEET FOR TV, FANS & PHONE LOCATIONS  
 NOTE: ELEC. CONTRACTOR TO VERIFY IF ON-O IS NEEDED PER COMMUNITY SPECS.

**ELEVATION A & C STD**  
**UTILITY PLAN**

1/8" = 1'-0" (11X17) 1/4" = 1'-0" (22X34)



LOT: 0000, COMMUNITY 1860 SKY 40' EXPLORATION SERIES

PARK SQUARE HOMES RESERVES COPYRIGHT & OTHER RIGHTS RESTRICTING THESE DOCUMENTS TO THE ORIGINAL SITE OR PURPOSE FOR WHICH THEY WERE PREPARED. REPRODUCTIONS, CHANGES OR ASSIGNMENTS ARE PROHIBITED.

**ITEG**  
 THOMPSON ENGINEERING GROUP, INC.  
 4401 Vineyard Road Suite A8 Orlando, FL 32811  
 Phone: (407) 244-1790  
 Fax: (407) 244-1790  
 www.iteg.com

**Park Square HOMES**  
 A DIVISION OF PARK SQUARE ENTERPRISES, INC.  
 5200 Vineyard Road, Suite 200  
 Orlando, Florida 32811  
 Phone: (407) 529 - 3000

**UTILITY PLAN**  
 REVISIONS  
 DELTA #    DATE  
 DATE: 09-11-25  
 SCALE: AS NOTED  
 DRAWN: MR  
 SHEET: 01

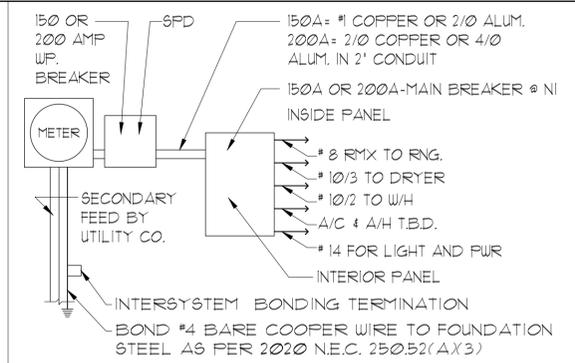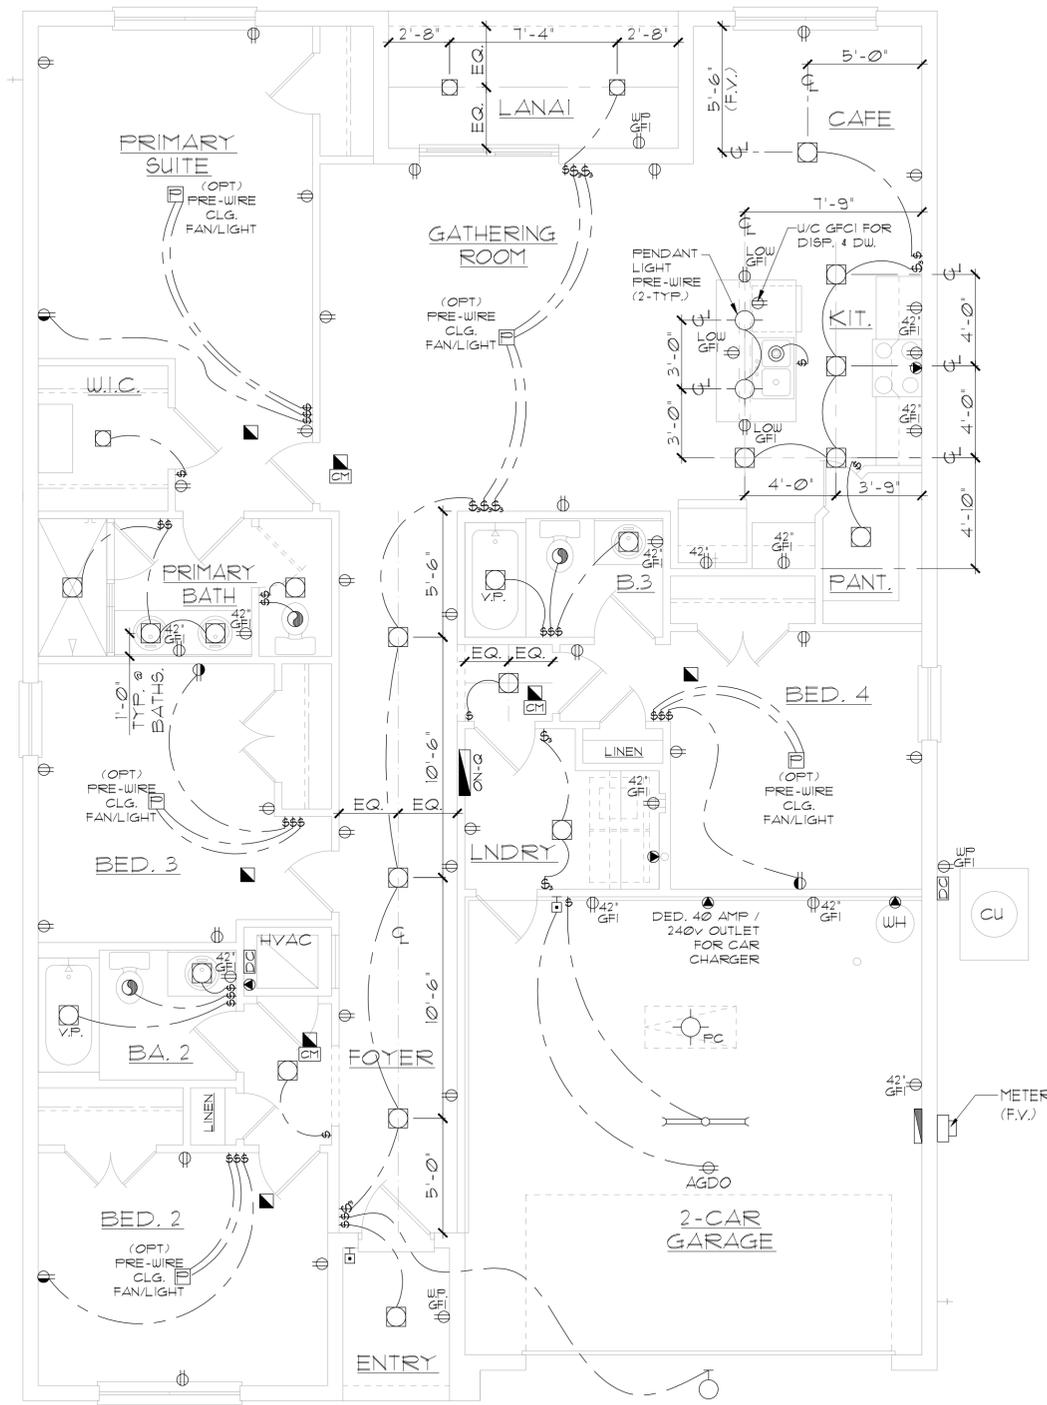

**ELECTRICAL RISER DIAGRAM**  
N.T.S.

**NOTES:**  
 1. ELECTRICAL MATERIALS AND INSTALLATIONS SHALL COMPLY W/ APPLICABLE PROVISIONS OF THE NATIONAL ELEC. CODE 250.52(A)1 TO (6), NFPA 70, LOCAL CODES, AND THE LOCAL POWER/UTILITY COMPANY.  
 2. ALL SERVICES SUPPLYING DWELLING UNITS SHALL BE PROVIDED WITH A SURGE-PROTECTION DEVICE (SPD) THE SPD SHALL BE A TYPE 1 OR TYPE 2 SPD.  
 3. SEE GENERAL NOTES PAGE FOR ADDITIONAL INFORMATION.

**250.52(A)3 Concrete-Encased Electrode.**  
 Concrete-encased electrodes can be horizontal or vertical and must be at least 20 ft. long. Concrete-encased electrodes can be horizontal or vertical and must be at least 20 ft. long. There are two types of concrete-encased electrodes: (1) steel reinforcing bars or rods which are not less than 1/2 inch in diameter and at least 20 ft. long, encased in 2 inches of concrete; (2) 20 ft. of bare copper conductor not smaller than No. 4 AWG encased in 2 inches of concrete. The steel reinforcing rods must be in a location that is in direct contact with the earth. The reinforcing rods can be connected with tie wires, and a single length of rod can be used as the concrete-encased electrode. The reinforcing rods cannot be coated with non-conductive material. Section 250.50 requires a concrete-encased electrode to be connected to the grounding electrode system if it is present. Several states have modified this requirement to say a concrete-encased electrode must be used as a grounding electrode only if it is available. In those jurisdictions, if the footings or foundations have been poured before the electrical contractor arrives at the site, and a reinforcing rod is not available for use as a grounding electrode, then a grounding connection to the reinforcing rod is not required.

**ELECTRICAL LEGEND**

⊕	SINGLE POLE SWITCH	◀	OUTLET, PHONE
⊕	THREE WAY SWITCH	◻	INTERCOM
⊕	OUTLET 110-115	⊕	CHIMES
⊕	OUTLET 110-115, SPLIT WIRED	⊕	SMOKE DETECTOR/SMOKE ALARM W/ INTEGRATED SOUNDER BASE
⊕	OUTLET 110-115, W/ USB	⊕	CARBON MONOXIDE
⊕	OUTLET 110-115, CEILING MOUNTED	⊕	PUSH BUTTON
⊕	OUTLET 110-115, FLOOR MOUNTED	⊕	EXHAUST FAN
⊕	SPECIAL PURPOSE 220-240	⊕	EX. FAN/LIGHT COMBO
⊕	LIGHT FIXTURE, CEILING MOUNTED	⊕	DISPOSAL
⊕	LIGHT FIXTURE, WALL MOUNTED	⊕	ON-Q PANEL
⊕	LED LIGHT FIXTURE, RECESSED	⊕	ELECTRICAL PANEL
⊕	LIGHT FIXTURE, RECESSED ADJUST.	⊕	CEILING FAN, PREWIRED
⊕	LIGHT FIXTURE, FULL CHAIN	⊕	CEILING FAN, INSTALL
⊕	LED LIGHT FIXTURE, FLUORESCENT	⊕	ELEC. JUNCTION BOX
⊕	LIGHT FIXTURE, EXTERIOR FLOODS	⊕	THERMOSTAT
⊕	LIGHT FIXTURE, EMERGENCY EXIT	⊕	DISCONNECT SWITCH
⊕	LIGHT FIXTURE, EXIT/BACKUP	⊕	ELEC. POWER METER
⊕	OUTLET, TV/CABLE		

ELECTRICAL DEVICES	ABOVE FIN. FLR.
SWITCHES AND WALL OUTLETS OVER COUNTERS	48" TO CL.
REMAINING SWITCHES	48" TO CL.
WALL OUTLETS	12" TO CL.
TELEPHONE OUTLETS	12" TO CL.
TELEVISION OUTLETS	12" TO CL.
EXTERIOR GFI'S	48" TO CL.
GARAGE GFI'S (ABOVE GARAGE FLOOR)	54" TO CL.
THERMOSTAT	84" TO CL.
DOOR BELL CHIMES	LEVEL W/ DOOR HANDLE
DOOR BELL BUTTON	66" TO CL.
KITCHEN HOOD FAN "WHIP"	16" TO CL.
KITCHEN WALL HUNG MICROWAVE RECEPTACLE	UNDER SINK
KITCHEN DISHWASHER RECEPTACLE	24" TO CL.
KITCHEN RANGE	48" TO CL.
KITCHEN REFRIGERATOR	36" TO CL.
WASHER/DRYER OUTLET	84" TO CL.
HOLLYWOOD LIGHTS	



CL. = CENTER LINE

NOTE: SEE FINAL COLOR SHEET FOR TV, FANS & PHONE LOCATIONS  
 NOTE: ELEC. CONTRACTOR TO VERIFY IF ON-Q IS NEEDED PER COMMUNITY SPECS.

**ELEVATION B STD**  
**UTILITY PLAN**  
1/8" = 1'-0" (11X17) 1/4" = 1'-0" (22X34)

LOT: 0000, COMMUNITY 1860 SKY  
 PARK SQUARE HOMES RESERVES COPYRIGHT & OTHER RIGHTS RESTRICTING THESE DOCUMENTS TO THE ORIGINAL SITE OR PURPOSE FOR WHICH THEY WERE PREPARED. REPRODUCTIONS, CHANGES OR ASSIGNMENTS ARE PROHIBITED.  
 THIS STRUCTURE IS DESIGNED IN ACCORDANCE WITH THE 2018 EDITION, 2023 OF THE FLORIDA BUILDING CODE-RESIDENTIAL AND IS CERTIFIED AS SUCH  
 A DIVISION OF PARK SQUARE ENTERPRISES, INC.  
 5200 Vineyard Road, Suite 200  
 Orlando, Florida 32811  
 Phone: (407) 529 - 3000  
 THOMPSON ENGINEERING GROUP, INC.  
 4401 Vineyard Road Suite 40 Orlando, FL 32811  
 Tel: (407) 724-1790 Fax: (407) 724-1790 www.teng.com

**UTILITY PLAN**  
**40' EXPLORATION SERIES**  
 REVISIONS  
 DELTA #      DATE  
 DATE: 09-11-25  
 SCALE: AS NOTED  
 DRAWN: MR  
 SHEET: 11

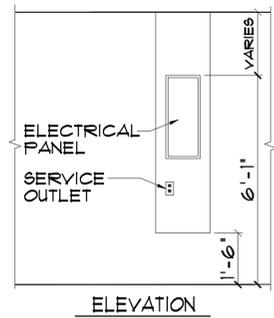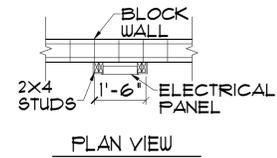

ELEC. PANEL DETAIL  
N.T.S.

EXT. FINISH ROOF MATERIAL SEE EXT. ELEV.  
INSULATION AS REQUIRED PER ENERGY CALCS  
PRE-ENG. TRUSSES @ 24" O.C. MAX. UNO.



ALL UNDERLAYMENT ARE REQUIRED TO MEET ASTM D226 TYPE II, ASTM D4869 TYPE III OR IV, ASTM D6151, OR SYNTHETIC UNDERLAYMENT MEETING THE PERFORMANCE REQUIREMENTS SPECIFIED OVER 19/32" EXT. GRADE ROOF SHEATHING w/ 1/4" CLIPS SECURED PER FRAMING NOTES

P.T. 2x4 RAFTER @ EA. TRUSSES SECURED w/ A23 @ BOTH ENDS  
CONT. 1x2 NAILING STRIP (UNSUPPORTED SPAN LIMITED PER FBC 104.2.1)

METAL DRIP EDGE  
2x6 SUB FASCIA  
VENTED ALUMINUM SOFFIT PANELS SHALL BE INSTALLED PER R104.2 OF FBC 8TH (2023)


SOFFIT OVERHANG DETAIL - NOMINAL HEEL COND.  
N.T.S.

NOTE:  
ROOF UNDERLAYMENT SHALL COMPLY WITH MANUFACTURER'S INSTALLATION INSTRUCTIONS IN ACCORDANCE WITH R303.33 - FBC 2023 8TH EDITION

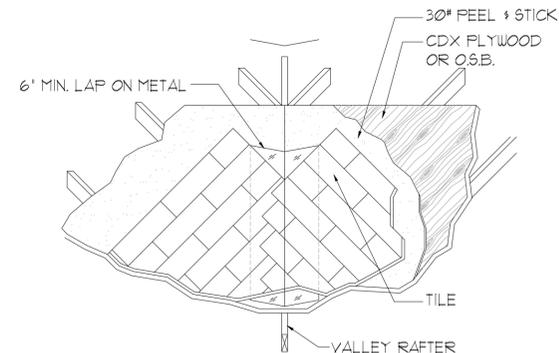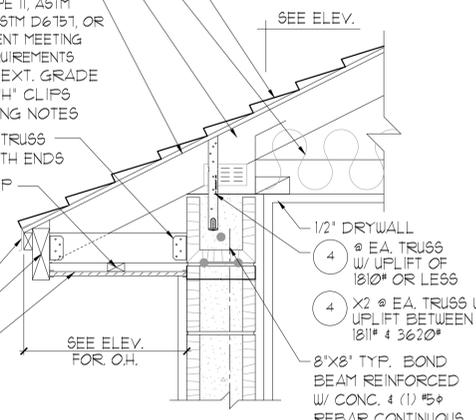


VALLEY FLASHING DETAIL

R303.2 Locations. N.T.S.  
Flashings shall be installed at wall and roof intersections, wherever there is a change in roof slope or direction and around roof openings. Where flashing is of metal, the metal shall be corrosion resistant with a thickness of not less than provided in Table R303.2.1. OR IN COMPLIANCE WITH RA6 III.

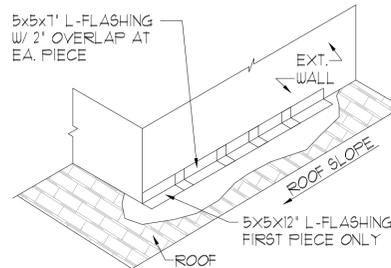


FLASHING DETAIL TO COMPLY WITH R303.2 OF THE FBC 2023 - 8TH ED.


STEP WALL FLASHING  
N.T.S.

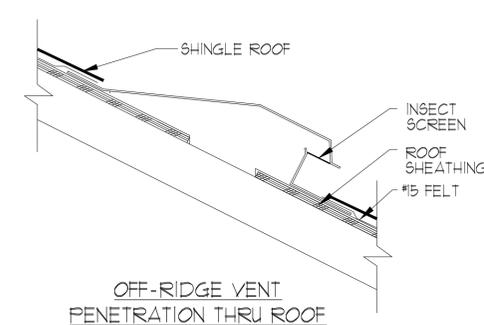


OFF-RIDGE VENT PENETRATION THRU ROOF

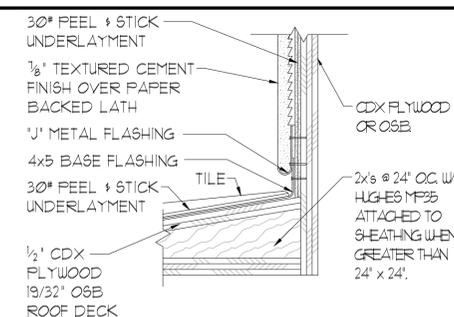

ROOF TO WALL FLASHING DETAIL  
N.T.S.

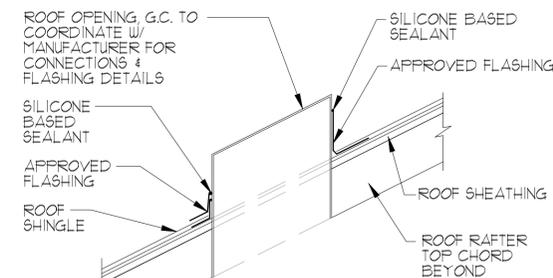

OPENING PENETRATION THRU ROOF

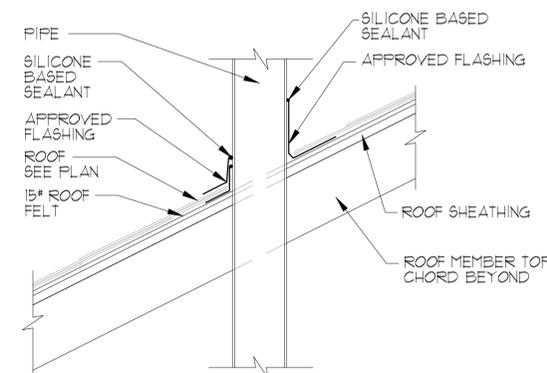

PIPE PENETRATION THRU ROOF

ROOF PENETRATION DETAIL SCALE: N.T.S.



A DIVISION OF PARK SQUARE ENTERPRISES, INC.  
5200 Vineland Road, Suite 200  
Orlando, Florida 32811  
Phone: (407) 529 - 3000



DETAILS

DETAILS

REVISIONS

DELTA # DATE

DATE: XX-XX-24

SCALE: AS NOTED

DRAWN: MR

SHEET:

AD1


THIS STRUCTURE IS DESIGNED IN ACCORDANCE WITH THE 8th EDITION, 2023 OF THE FLORIDA BUILDING CODE-RESIDENTIAL, AND IS CERTIFIED AS SUCH.

LOT: 000, COMMUNITY

PARK SQUARE HOMES RESERVES COPYRIGHT & OTHER RIGHTS RESTRICTING THESE DOCUMENTS TO THE ORIGINAL SITE OR PURPOSE FOR WHICH THEY WERE PREPARED. REPRODUCTIONS, CHANGES OR ASSIGNMENTS ARE PROHIBITED.





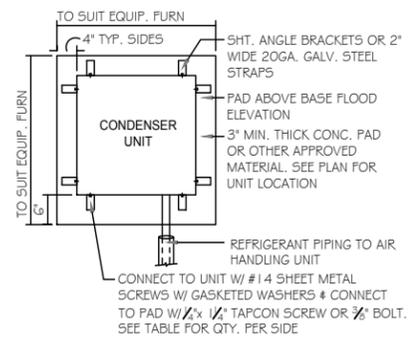

ANCHOR SPACING TABLE	
LENGTH/SIDE	No. OF ANCHORS/SIDES
LESS THAN 12"	ONE / SIDE
12" - 24"	TWO / SIDE
36" UP & 5 TONS & UP	FOUR / SIDE

**1 COND. ANCHOR DETAIL**  
N.T.S.

**FIELD REPAIR NOTES**


- MISSED FOOTING DOWELS MAY BE SUBSTITUTED W/ A STRAIGHT #5 REBAR SET IN A 3/4" DIA. x 6" DEEP HOLE FILLED W/ UNITEK PROPOXY 300 OR SIMPSON SET OR E/F ADHESIVES.
- BLOCK WALL OVERHANGING SLAB CONDITION: UP TO 7/8" - NO REPAIR NECESSARY 7/8" TO 1 1/4" - ADD FILLED CELL (NO VERTICAL STEEL) MIDPOINT OF WALL BETWEEN EXISTING FILLED CELLS (WITH STEEL) IN AREAS AFFECTED. 1 1/4" + - REQUIRE SPECIAL ENGINEERING LETTER.
- PENETRATION OF PLUMBING PIPES/DRYER VENTS THRU PLATES OF A LOAD BEARING WALL MAY OCCUR PROVIDED DBL. STUDS ARE ADDED ON EITHER SIDE OF PENETRATION WITHIN 3" AND TRUSS/FLOOR TRUSS IS NO CLOSER THAN 3" FROM PENETRATION. ADD (1) MTS12 @ TOP AND BOTTOM PLATE.

**VERIFICATION OF FIELD CONDITIONS:**

CONTRACTOR SHALL VERIFY ALL FIELD CONDITIONS AND DIMENSIONS RELATIVE TO SAME. WHERE THERE ARE CONFLICTS BETWEEN ACTUAL FIELD CONDITIONS AND DATA PRESENTED IN THE DRAWINGS, SUCH CONDITIONS SHALL BE CALLED TO THE ARCHITECT'S AND OR TO THE ENGINEER OF RECORD'S (EOR) ATTENTION AND NECESSARY ADJUSTMENTS MADE PER THEIR INSTRUCTIONS.

**FOUNDATION NOTES**

- CONTRACTOR VERIFY ALL DIMENSIONS ON JOB SITE.
- ⊙ DENOTES FILL CELL REINF. W/ CONC. W/ 1- #5 REBAR. GRADE 60. ⊙ DENOTES FILL CELL RE NE\_ W/ CONC. W/ 2-#5 REBAR. GRADE 60.
- ⊙ DENOTES FLOOR SLAB OF PLANT MIX CONCRETE 2,500 P.S.I. 4" THICK WITH 6x6 10/10 GAUGE REINFORCING MAT. W/ MIN. 0.006mm (6mil) POLYETHYLENE VAPOR BARRIER OVER COMPACTED CLEAN FILL. WWF SHALL BE PLACE IN MIDDLE TO UPPER THIRD OF SLAB AND SUPPORTED ON APPROVED SLAB BOLSTERS. \*FIBER MESH REINFORCEMENT MAY USED AS ALTERNATIVE TO WIRE.
- DO NOT SCALE PRINTS! CONSTRUCTION TO BE FROM CALCULATED DIMENSIONS ONLY. ANY DISCREPANCIES OR ERRORS TO BE REPORTED PROMPTLY TO SUPER-VISOR FOR CLARIFICATION.
- WATER HEATER T&P RELIEF VALVE SHALL E FULL SIZE TO EXTERIOR. WATER HEATER AT OR ABOVE FLOOR LEVEL 61-FALL E IN A FAN WITH DRAIN TO EXTERIOR. WATER HEATER SHALL HAVE APPROVED THERMAL EXPANSION DEVICE
- PAVERS MAY BE USED ILO CONCRETE SLABS IN PATIO, PORCH, DRIVE AND WALKWAY AREAS. DELETE SLAB IN AREAS PAVERS ARE USED.
- MECHANICAL EQUIP. LOCATIONS WILL BE DETERMINED BY COMMUNITY AND COUNTY CODES.
- IN LIEU OF TREATING THE SOIL, AN ALTERNATIVE TO TERMITES TREATED SOIL CA BE PREMISE 75 WP TERMITIDE.
- BORA -CARE TO BE APPLIED ON INTERIOR WALLS W/ MANUFACTURER'S INSTRUCTIONS AND SPECIFICATIONS, PURSUANT FLORIDA BUILDING CODE LATEST EDITION.

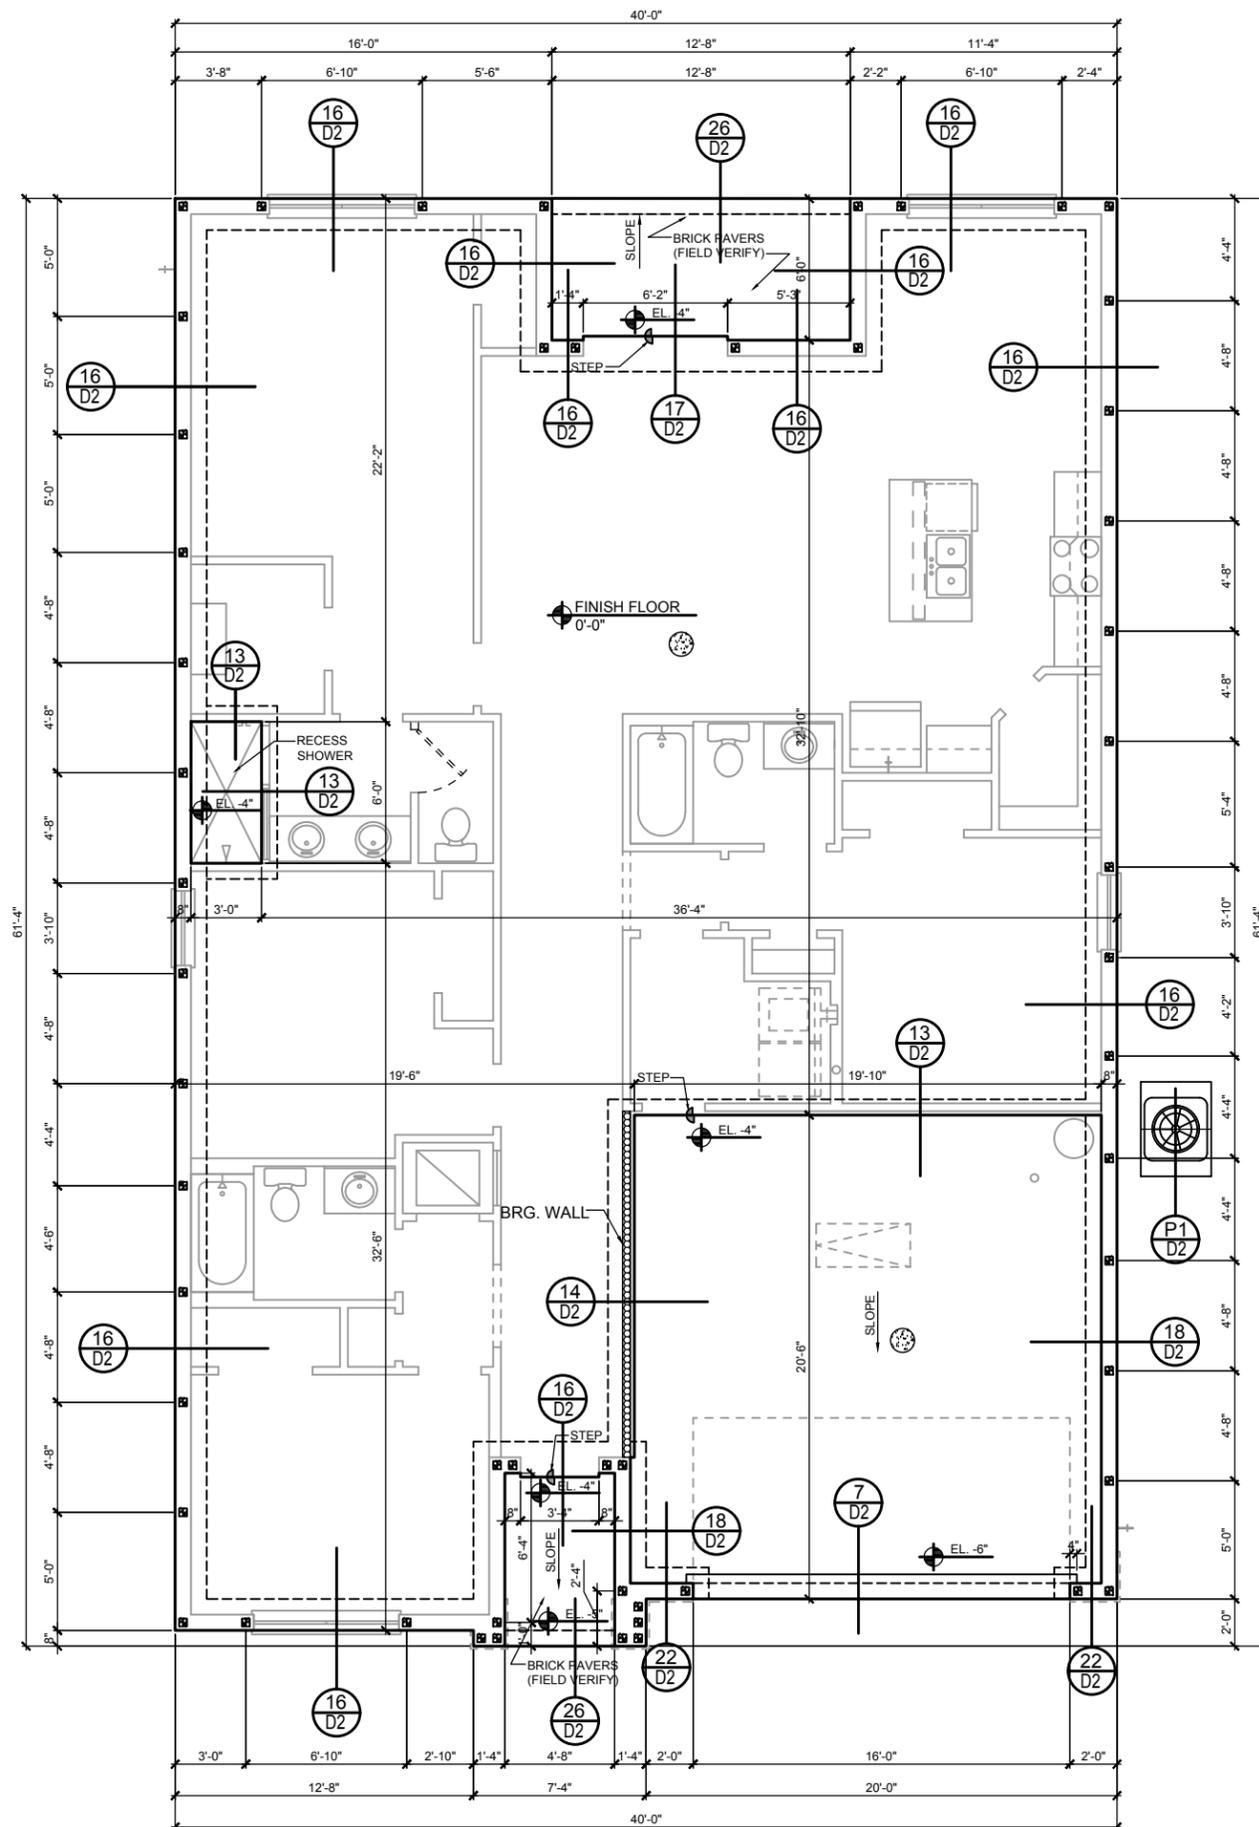

**FOUNDATION PLAN C (STANDARD)**  
1/8"=1'-0" (11x17) 1/4"=1'-0" (22x37)

THIS STRUCTURE IS DESIGNED IN ACCORDANCE WITH THE 8th EDITION, 2003 OF THE FLORIDA BUILDING CODE-RESIDENTIAL AND IS CERTIFIED AS SUCH.  
**LOT: 0000, COMMUNITY**  
 1860 SKY  
**FOUNDATION PLAN**  
 40' EXPLORATION SERIES  
**REVISIONS**  
 DELTA # DATE  
 DATE: 09-11-25  
 SCALE: AS NOTED  
 DRAWN: MR  
 SHEET: S1



**ITEG**  
 THOMPSON ENGINEERING GROUP, INC.  
 A DIVISION OF PARK SQUARE ENTERPRISES, INC.  
 5200 Vineyard Road, Suite 200  
 Orlando, Florida 32811  
 Phone: (407) 529-3000

# SAFE LOAD TABLES FOR GRAVITY, UPLIFT & LATERAL LOADS

8" PRECAST & PRESTRESSED U-LINTELS									
GRAVITY									
LENGTH	TYPE	8U8	8F8-0B	8F12-0B	8F16-0B	8F20-0B	8F24-0B	8F28-0B	8F32-0B
2'-10" (34")	PRECAST	2302	3166	4473	6039	7526	9004	10472	11936
3'-6" (42")	PRECAST	2302	3166	4473	6039	7526	9004	10472	11936
4'-0" (48")	PRECAST	2029	2646	4473	6039	7526	9004	10472	11936
4'-6" (54")	PRECAST	1651	1787	1913	2657	3403	4149	4896	5644
5'-4" (64")	PRECAST	1184	1223	1301	1809	2317	2825	3333	3841
5'-10" (70")	PRECAST	972	1000	1059	1474	1889	2304	2721	3137
6'-6" (78")	PRECAST	937	1255	2101	3263	4425	5587	6749	7911
7'-6" (90")	PRECAST	767	1029	1675	2385	3095	3805	4515	5225
8'-0" (96")	PRECAST	670	830	1362	1927	2492	3102	3712	4322
8'-8" (104")	PRECAST	618	767	1257	1779	2299	2919	3539	4159
9'-4" (112")	PRECAST	573	632	1049	1469	1889	2509	3129	3749
10'-6" (126")	PRECAST	456	482	802	1125	1448	1871	2294	2717
11'-4" (136")	PRECAST	445	458	735	1058	1381	1804	2227	2650
12'-0" (144")	PRECAST	414	427	726	1028	1351	1774	2197	2620
13'-4" (160")	PRECAST	362	381	648	919	1190	1462	1885	2308
14'-0" (168")	PRECAST	338	355	600	840	1080	1320	1740	2160
14'-8" (176")	PRESTRESSED	N.R.	NR	NR	NR	NR	NR	NR	NR
15'-4" (184")	PRESTRESSED	N.R.	NR	NR	NR	NR	NR	NR	NR
17'-4" (208")	PRESTRESSED	N.R.	NR	NR	NR	NR	NR	NR	NR
19'-4" (232")	PRESTRESSED	N.R.	NR	NR	NR	NR	NR	NR	NR
21'-4" (256")	PRESTRESSED	N.R.	NR	NR	NR	NR	NR	NR	NR
22'-0" (264")	PRESTRESSED	N.R.	NR	NR	NR	NR	NR	NR	NR
24'-0" (288")	PRESTRESSED	N.R.	NR	NR	NR	NR	NR	NR	NR

8" PRECAST W/ 2" RECESS DOOR U-LINTELS									
GRAVITY									
LENGTH	TYPE	8RUB	8RF6-0B	8RF10-0B	8RF14-0B	8RF18-0B	8RF22-0B	8RF26-0B	8RF30-0B
4'-4" (52")	PRECAST	1489	1591	3053	4515	5977	7439	8901	10363
4'-6" (54")	PRECAST	1357	1449	2782	4143	5571	7000	8428	9857
5'-8" (68")	PRECAST	785	832	1602	2400	3198	4000	4798	5596
5'-10" (70")	PRECAST	735	779	1500	2248	3000	3750	4500	5250
6'-8" (80")	PRECAST	622	666	1332	2000	2668	3336	4004	4672
7'-6" (90")	PRECAST	665	709	1414	2100	2768	3436	4104	4772
8'-8" (116")	PRECAST	371	420	834	1253	1672	2091	2510	2929

8" PRECAST & PRESTRESSED U-LINTELS										
UPLIFT										
LENGTH	TYPE	8F8-1T	8F12-1T	8F16-1T	8F20-1T	8F24-1T	8F28-1T	8F32-1T	8U8	8F8
2'-10" (34")	PRECAST	2727	2878	4101	5332	6563	7794	9025	2021	2021
3'-6" (42")	PRECAST	2165	2289	3260	4237	5214	6204	7192	1257	1257
4'-0" (48")	PRECAST	1878	1989	2832	3680	4528	5376	6224	938	938
4'-6" (54")	PRECAST	1660	1762	2507	3257	4010	4767	5525	727	727
5'-4" (64")	PRECAST	1393	1437	2050	2670	3293	3920	4549	505	505
5'-10" (70")	PRECAST	1141	1200	1733	2250	2769	3290	3812	418	418
6'-6" (78")	PRECAST	1141	1182	1684	2192	2703	3216	3732	707	887
7'-6" (90")	PRECAST	990	1029	1468	1907	2351	2797	3245	591	657
9'-4" (112")	PRECAST	801	765	1192	1550	1910	2271	2634	454	630
10'-6" (126")	PRECAST	666	631	1039	1389	1711	2034	2358	396	493
11'-4" (136")	PRECAST	607	573	882	1164	1446	1728	2010	363	556
14'-0" (168")	PRECAST	548	514	729	922	1156	1390	1624	286	360
14'-8" (176")	PRESTRESSED	243	295	459	591	724	857	990	N.R.	357
15'-4" (184")	PRESTRESSED	228	278	430	553	677	801	925	N.R.	325
17'-4" (208")	PRESTRESSED	188	236	361	464	567	670	774	N.R.	257
19'-4" (232")	PRESTRESSED	165	207	313	401	490	578	667	N.R.	204
21'-4" (256")	PRESTRESSED	145	186	278	358	433	512	590	N.R.	172
22'-0" (264")	PRESTRESSED	140	180	268	343	418	493	568	N.R.	161
24'-0" (288")	PRESTRESSED	124	166	240	312	380	447	515	N.R.	135

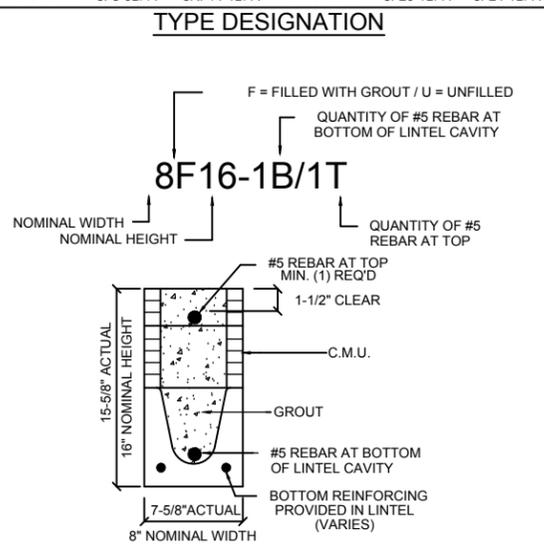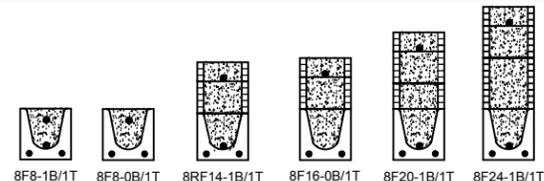


- MATERIALS**
1. P/c precast lintels = 3500 psi.
  2. P/c prestressed lintels = 6000 psi.
  3. P/c grout = 3000 psi w/ maximum 3/8" aggregate.
  4. Concrete masonry units (CMU) per ASTM C90 w/ minimum net area compressive strength = 1900 psi.
  5. Rebar provided in precast lintel per ASTM A615 GR60. Field rebar per ASTM A615 GR40 or GR60.
  6. Prestressing strand per ASTM A416 grade 270 low relaxation.
  7. 7/32" wire per ASTM A510.
  8. Mortar per ASTM C270 type M or S.

- GENERAL NOTES**
1. Provide full mortar head and bed joints.
  2. Shore filled lintels as required.
  3. Installation of lintel must comply with the architectural and/or structural drawings.
  4. Lintels are manufactured with 5-1/2" long notches at the ends to accommodate vertical cell reinforcing and grouting.
  5. All lintels meet or exceed L/360 vertical deflection, except lintels 17'-4" and longer with a nominal height of 8" meet or exceed L/180.
  6. Bottom field added rebar to be located at the bottom of the lintel cavity.
  7. 7/32" diameter wire stirrups are welded to the bottom steel for mechanical anchorage.
  8. Cast-in-place concrete may be provided in composite lintel in lieu of concrete masonry units.
  9. Safe load ratings based on rational design analysis per ACI 318 and ACI 530.

- SAFE LOAD TABLE NOTES**
1. All values based on minimum 4" bearing. Exception: Safe loads for unfilled lintels must be reduced by 20% if bearing length is less than 6-1/2". Safe loads for all recessed lintels based on 8" nominal bearing.
  2. N.R. = Not Rated.
  3. Safe loads are total superimposed allowable load on the section specified.
  4. Safe loads based on grade 40 or grade 60 field rebar.
  5. Additional lateral load capacity can be obtained by the designer by providing additional reinforced masonry above the precast lintel.
  6. One #7 rebar may be substituted for two #5 rebars in 8" lintels only.
  7. The designer may evaluate concentrated loads from the safe load tables by calculating the maximum resisting moment and shear at d-away from the face of support.
  8. For composite lintel heights not shown, use safe load from next lower height.
  9. All safe loads in units of pounds per linear foot.

8" PRECAST W/ 2" RECESS DOOR U-LINTELS										
UPLIFT										
LENGTH	TYPE	8RF6-1T	8RF10-1T	8RF14-1T	8RF18-1T	8RF22-1T	8RF26-1T	8RF30-1T	8RUB	8RF6
4'-4" (52")	PRECAST	1244	1573	2413	3260	4112	4967	5825	932	932
4'-6" (54")	PRECAST	1192	1507	2311	3121	3937	4756	5577	853	853
5'-8" (68")	PRECAST	924	1132	1741	2357	2978	3603	4230	501	501
5'-10" (70")	PRECAST	896	1138	1742	2352	2965	3581	4198	469	469
6'-8" (80")	PRECAST	778	956	1455	1987	2509	3035	3563	830	1100
7'-6" (90")	PRECAST	688	868	1325	1810	2280	2753	3227	710	941
9'-8" (116")	PRECAST	533	627	1008	1369	1728	2088	2450	516	614

CAST CRETE / LOTT'S / WEKIWA / FLORIDA ROCK - PRECAST LINTEL SCHEDULE				
LINTEL NO.	LENGTH	TYPE	COMMENTS	
L-1	17'-4"	8F28-1B/1T	GARAGE	
L-2	7'-6"	8F16-1B/1T	FR SH25	
L-3	7'-6"	8F24-1B/1T	6/10X6/8 SGD	
L-4	14'-0"	8F16-1B/1T	LANAI	
L-5	4'-6"	8F16-1B/1T	SH25	
L-6	7'-6"	8F16-1B/1T	ENTRY	
L-7	4'-6"	8RF22-1B/1T	3068 DR	

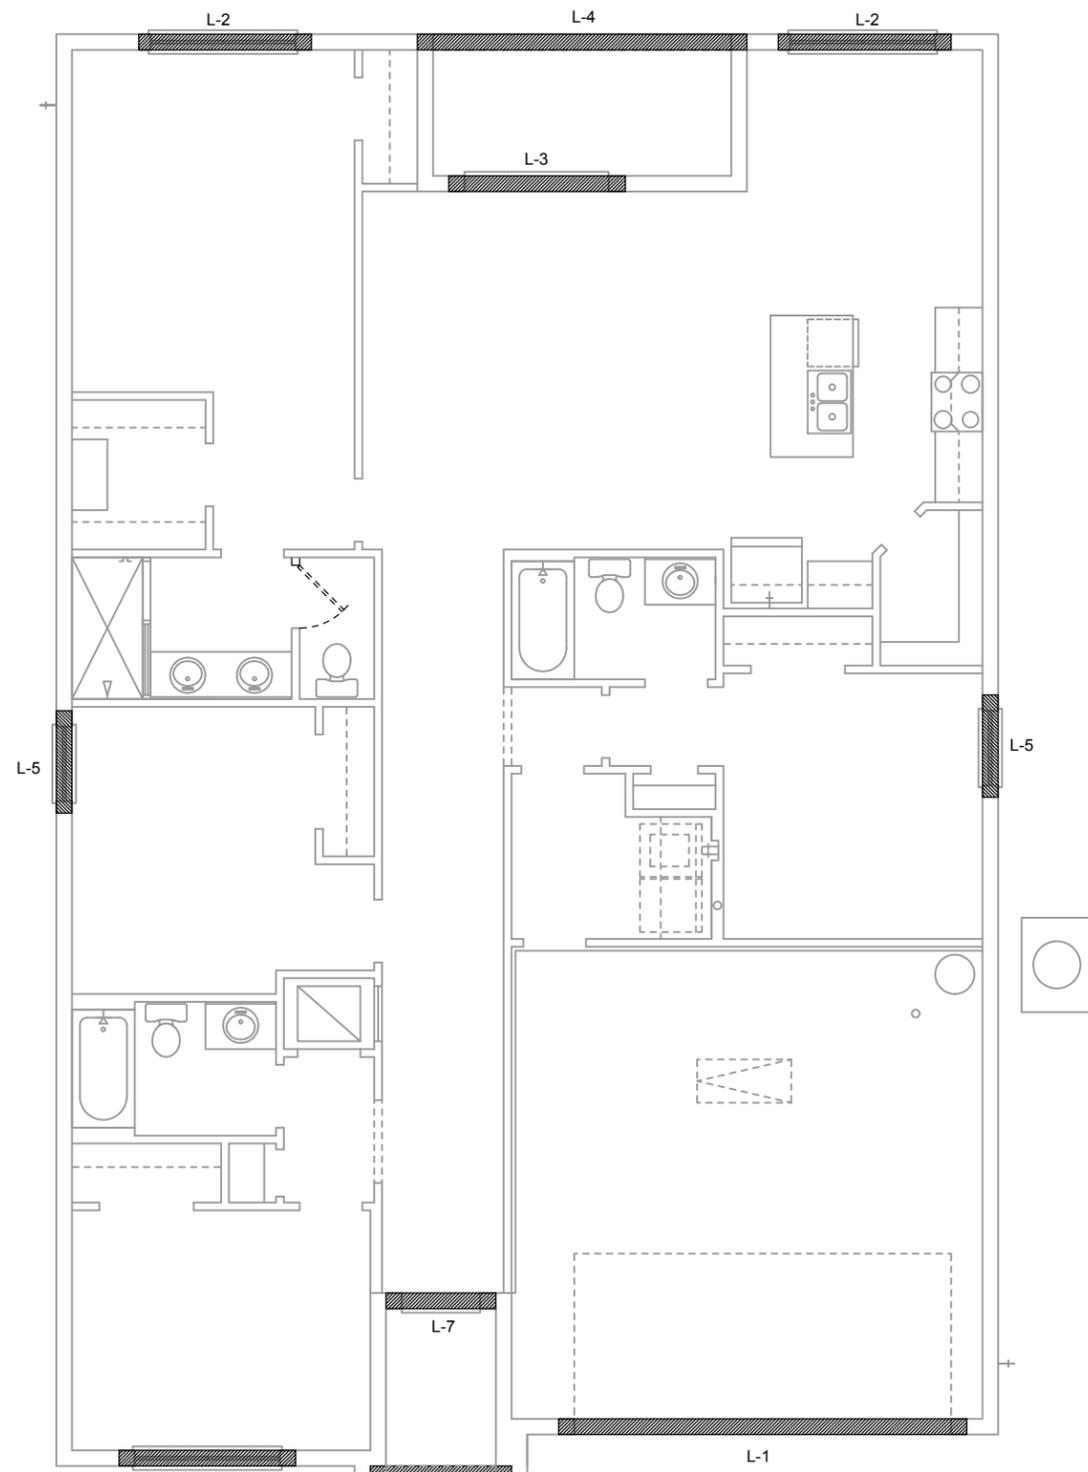

**PRECAST LINTEL PLAN**  
A (STANDARD)  
1/8"=1'-0" (11x7) 1/4"=1'-0" (22x34)

LOT: 0000, COMMUNITY

1860 SKY

40' EXPLORATION SERIES

PRECAST LINTEL PLAN

REVISIONS

DELTA #	DATE
	09-11-25

SCALE: AS NOTED

DRAWN: MR

SHEET: S2

1860 SKY

40' EXPLORATION SERIES

PRECAST LINTEL PLAN

A DIVISION OF PARK SQUARE ENTERPRISES, INC.  
5200 Vineyard Road, Suite 200  
Orlando, Florida 32818  
Phone: (407) 529-3000



HITEC  
HOLMISTON ENGINEERING GROUP, INC.  
11000 US Highway 19, Suite 200  
Orlando, FL 32817  
Tel: (407) 734-8600  
Fax: (407) 734-1790  
www.hitec.com

# SAFE LOAD TABLES FOR GRAVITY, UPLIFT & LATERAL LOADS

8" PRECAST & PRESTRESSED U-LINTELS									
GRAVITY									
LENGTH	TYPE	8U8	8F8-0B	8F12-0B	8F16-0B	8F20-0B	8F24-0B	8F28-0B	8F32-0B
2'-10" (34")	PRECAST	2302	3166	4473	6039	7526	9004	10472	11936
3'-6" (42")	PRECAST	2302	3166	4473	6039	7526	9004	10472	11936
4'-0" (48")	PRECAST	2029	2646	4473	6039	7526	9004	10472	11936
4'-6" (54")	PRECAST	1651	1787	1913	2657	3403	4149	4896	5644
5'-4" (64")	PRECAST	1184	1223	1301	1809	2317	2825	3333	3841
5'-10" (70")	PRECAST	972	1000	1059	1474	1889	2304	2721	3137
6'-6" (78")	PRECAST	937	1255	2101	3263	2746	3358	3971	4585
7'-6" (90")	PRECAST	767	1029	1675	2385	1994	2439	2886	3333
8'-0" (96")	PRECAST	670	830	1362	1927	1602	1961	2320	2680
8'-8" (104")	PRECAST	618	767	1257	1779	1479	1810	2142	2474
9'-4" (112")	PRECAST	573	632	1049	1469	1210	1482	1754	2027
10'-6" (126")	PRECAST	456	482	802	1125	915	1122	1328	1535
11'-4" (136")	PRECAST	445	458	748	1076	854	1035	1216	1397
12'-0" (144")	PRECAST	414	427	726	1028	813	994	1175	1356
13'-4" (160")	PRECAST	362	381	648	919	704	885	1066	1247
14'-0" (168")	PRECAST	338	355	600	840	654	815	976	1137
14'-8" (176")	PRESTRESSED	N.R.	NR	NR	NR	NR	NR	NR	NR
15'-4" (184")	PRESTRESSED	N.R.	NR	NR	NR	NR	NR	NR	NR
17'-4" (208")	PRESTRESSED	N.R.	NR	NR	NR	NR	NR	NR	NR
19'-4" (232")	PRESTRESSED	N.R.	NR	NR	NR	NR	NR	NR	NR
21'-4" (256")	PRESTRESSED	N.R.	NR	NR	NR	NR	NR	NR	NR
22'-0" (264")	PRESTRESSED	N.R.	NR	NR	NR	NR	NR	NR	NR
24'-0" (288")	PRESTRESSED	N.R.	NR	NR	NR	NR	NR	NR	NR

8" PRECAST W/ 2" RECESS DOOR U-LINTELS									
GRAVITY									
LENGTH	TYPE	8RU6	8RF6-0B	8RF10-0B	8RF14-0B	8RF18-0B	8RF22-0B	8RF26-0B	8RF30-0B
4'-4" (52")	PRECAST	1489	1591	3053	2982	3954	4929	5904	6880
4'-6" (54")	PRECAST	1357	1449	2782	2714	3600	4487	5375	6264
5'-8" (68")	PRECAST	785	832	1602	1550	2058	2566	3075	3585
5'-10" (70")	PRECAST	735	779	1500	1449	1924	2400	2876	3352
6'-8" (80")	PRECAST	622	666	1377	1325	1758	2184	2610	3036
7'-6" (90")	PRECAST	665	709	1377	1325	1758	2184	2610	3036
9'-8" (116")	PRECAST	371	420	834	1253	1071	1342	1614	1886

8" PRECAST & PRESTRESSED U-LINTELS										
UPLIFT										
LENGTH	TYPE	8F8-1T	8F12-1T	8F16-1T	8F20-1T	8F24-1T	8F28-1T	8F32-1T	8U8	8F8
2'-10" (34")	PRECAST	2727	2878	4101	5332	6569	7811	9055	2021	2021
3'-6" (42")	PRECAST	2165	2289	3260	4237	5219	6204	7192	1257	1257
4'-0" (48")	PRECAST	1878	1989	2832	3680	4532	5387	6245	938	938
4'-6" (54")	PRECAST	1660	1762	2507	3257	4010	4767	5525	727	727
5'-4" (64")	PRECAST	1393	1437	2050	2670	3293	3920	4549	505	505
5'-10" (70")	PRECAST	1272	1357	1930	2505	3084	3665	4247	418	418
6'-6" (78")	PRECAST	1141	1200	1733	2250	2769	3290	3812	707	887
7'-6" (90")	PRECAST	990	1029	1468	1907	2351	2797	3245	591	657
9'-4" (112")	PRECAST	801	765	1192	1550	1910	2271	2634	454	630
10'-6" (126")	PRECAST	716	611	1039	1389	1711	2034	2358	396	493
11'-4" (136")	PRECAST	666	535	905	1295	1595	1896	2198	363	556
14'-0" (168")	PRECAST	458	316	493	635	778	922	1065	286	360
14'-8" (176")	PRESTRESSED	243	295	459	591	724	857	990	N.R.	357
15'-4" (184")	PRESTRESSED	228	278	430	553	677	801	925	N.R.	325
17'-4" (208")	PRESTRESSED	188	236	361	464	567	670	774	N.R.	257
19'-4" (232")	PRESTRESSED	165	207	313	401	490	578	667	N.R.	204
21'-4" (256")	PRESTRESSED	145	186	278	358	433	512	590	N.R.	172
22'-0" (264")	PRESTRESSED	140	180	268	343	418	493	568	N.R.	161
24'-0" (288")	PRESTRESSED	124	166	230	300	370	440	510	N.R.	135

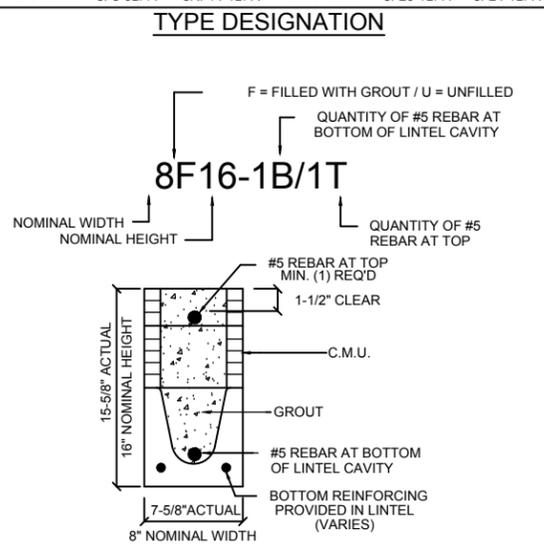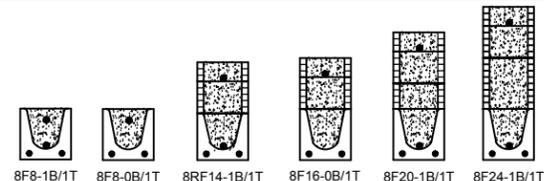


- MATERIALS**
1. P/c precast lintels = 3500 psi.
  2. P/c prestressed lintels = 6000 psi.
  3. P/c grout = 3000 psi w/ maximum 3/8" aggregate.
  4. Concrete masonry units (CMU) per ASTM C90 w/ minimum net area compressive strength = 1900 psi.
  5. Rebar provided in precast lintel per ASTM A615 GR60. Field rebar per ASTM A615 GR40 or GR60.
  6. Prestressing strand per ASTM A416 grade 270 low relaxation.
  7. 7/32" wire per ASTM A510.
  8. Mortar per ASTM C270 type M or S.

- GENERAL NOTES**
1. Provide full mortar head and bed joints.
  2. Shore filled lintels as required.
  3. Installation of lintel must comply with the architectural and/or structural drawings.
  4. Lintels are manufactured with 5-1/2" long notches at the ends to accommodate vertical cell reinforcing and grouting.
  5. All lintels meet or exceed L/360 vertical deflection, except lintels 17'-4" and longer with a nominal height of 8" meet or exceed L/180.
  6. Bottom field added rebar to be located at the bottom of the lintel cavity.
  7. 7/32" diameter wire stirrups are welded to the bottom steel for mechanical anchorage.
  8. Cast-in-place concrete may be provided in composite lintel in lieu of concrete masonry units.
  9. Safe load ratings based on rational design analysis per ACI 318 and ACI 530.

- SAFE LOAD TABLE NOTES**
1. All values based on minimum 4" bearing. Exception: Safe loads for unfilled lintels must be reduced by 20% if bearing length is less than 6-1/2". Safe loads for all recessed lintels based on 8" nominal bearing.
  2. N.R. = Not Rated.
  3. Safe loads are total superimposed allowable load on the section specified.
  4. Safe loads based on grade 40 or grade 60 field rebar.
  5. Additional lateral load capacity can be obtained by the designer by providing additional reinforced masonry above the precast lintel.
  6. One #7 rebar may be substituted for two #5 rebars in 8" lintels only.
  7. The designer may evaluate concentrated loads from the safe load tables by calculating the maximum resisting moment and shear at d-away from the face of support.
  8. For composite lintel heights not shown, use safe load from next lower height.
  9. All safe loads in units of pounds per linear foot.

8" PRECAST W/ 2" RECESS DOOR U-LINTELS										
UPLIFT										
LENGTH	TYPE	8RF6-1T	8RF10-1T	8RF14-1T	8RF18-1T	8RF22-1T	8RF26-1T	8RF30-1T	8RU6	8RF6
4'-4" (52")	PRECAST	1244	1573	2413	3260	4112	4967	5825	932	932
4'-6" (54")	PRECAST	1192	1507	2311	3121	3937	4756	5577	853	853
5'-8" (68")	PRECAST	924	1132	1741	2357	2978	3603	4230	501	501
5'-10" (70")	PRECAST	896	1138	1742	2352	2965	3581	4198	469	469
6'-8" (80")	PRECAST	778	956	1513	2042	2573	3107	3642	830	1100
7'-6" (90")	PRECAST	688	849	1302	1762	2225	2690	3157	710	941
9'-8" (116")	PRECAST	533	433	808	1123	1413	1704	1995	516	614

CAST CRETE / LOTT'S / WEKIWA / FLORIDA ROCK - PRECAST LINTEL SCHEDULE			
LINTEL NO.	LENGTH	TYPE	COMMENTS
L-1	17'-4"	8F28-1B/1T	GARAGE
L-2	7'-6"	8F16-1B/1T	FR SH25
L-3	7'-6"	8F24-1B/1T	6/10X6/8 SGD
L-4	14'-0"	8F16-1B/1T	LANAI
L-5	4'-6"	8F16-1B/1T	SH25
L-6	7'-6"	8F16-1B/1T	ENTRY
L-7	4'-6"	8RF22-1B/1T	3068 DR

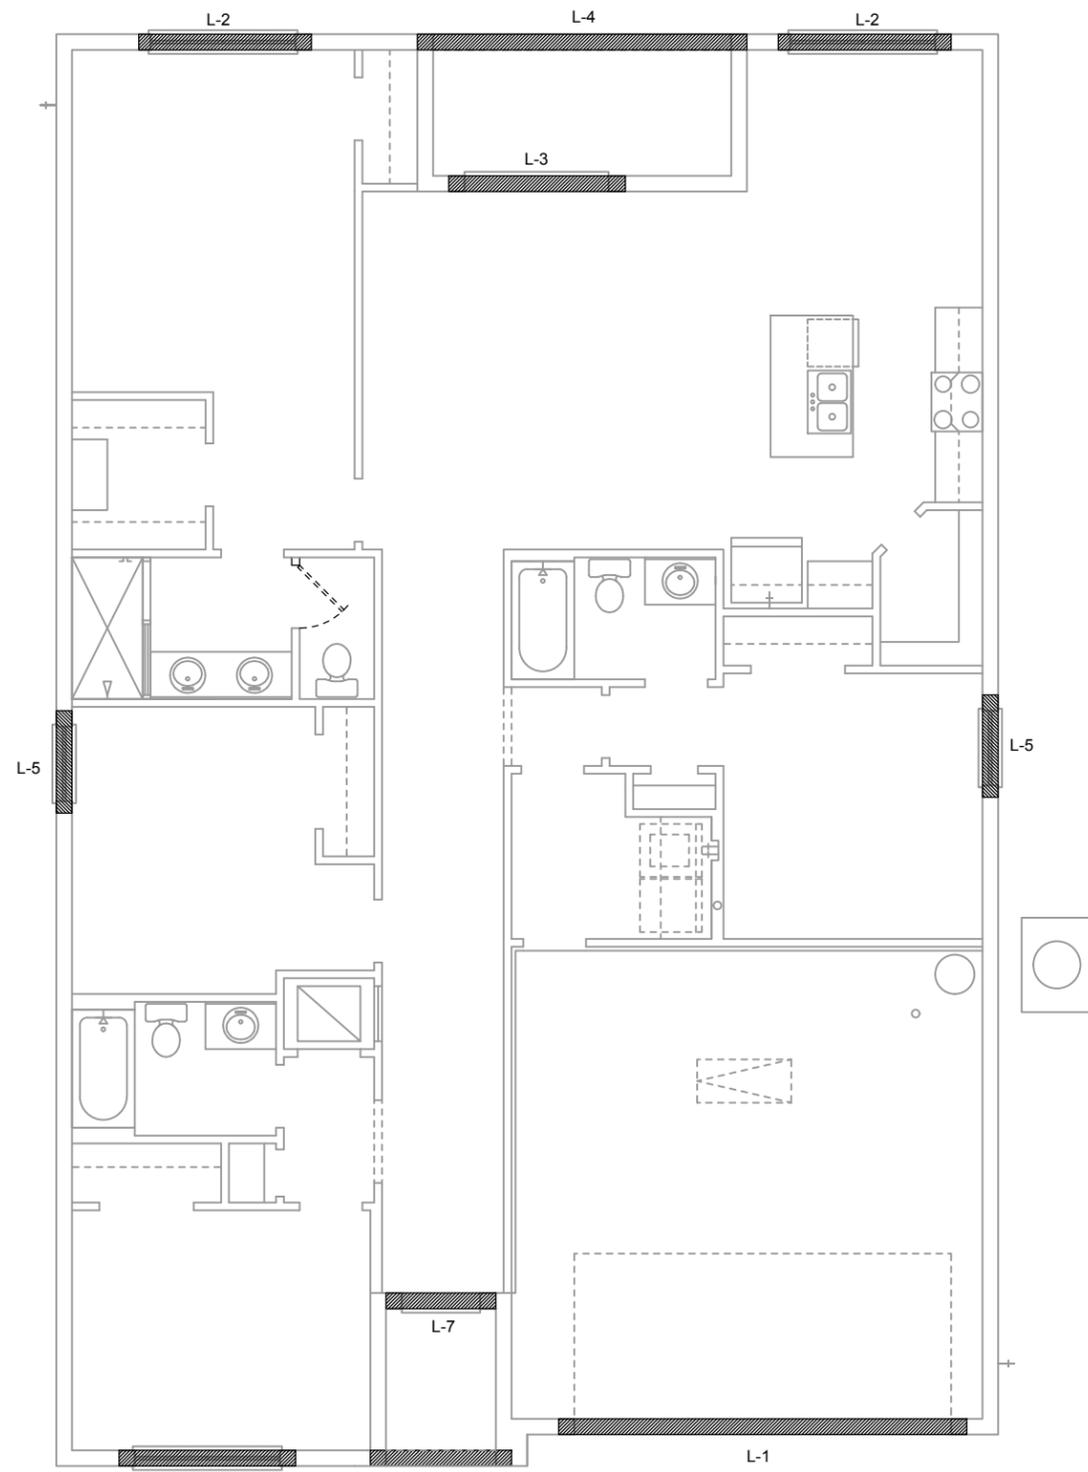

## PRECAST LINTEL PLAN B (STANDARD) 1/8"=1'-0" (11x7) 1/4"=1'-0" (22x34)

LOT: 0000, COMMUNITY  
 1860 SKY  
 40' EXPLORATION SERIES  
 PRECAST LINTEL PLAN  
 A DIVISION OF PARK SQUARE ENTERPRISES, INC.  
 5200 Vineyard Road, Suite 200  
 Orlando, Florida 32811  
 Phone: (407) 529-3000  
 HITEG  
 HILTON ENGINEERING GROUP, INC.  
 1407 734-660  
 1407 734-1790  
 www.hiteg.com

REVISIONS	
DELTA #	DATE



DATE: 09-11-25  
 SCALE: AS NOTED  
 DRAWN: MR  
 SHEET: S2

# SAFE LOAD TABLES FOR GRAVITY, UPLIFT & LATERAL LOADS

8" PRECAST & PRESTRESSED U-LINTELS									
GRAVITY									
LENGTH	TYPE	8U8	8F8-0B	8F12-0B	8F16-0B	8F20-0B	8F24-0B	8F28-0B	8F32-0B
2'-10" (34")	PRECAST	2302	3166	4473	6039	7526	9004	10472	11936
3'-6" (42")	PRECAST	2302	3166	4473	6039	7526	9004	10472	11936
4'-0" (48")	PRECAST	2029	2646	4473	6039	7526	9004	10472	11936
4'-6" (54")	PRECAST	1651	1787	1913	2657	3403	4149	4896	5644
5'-4" (64")	PRECAST	1184	1223	1301	1809	2317	2825	3333	3841
5'-10" (70")	PRECAST	972	1000	1059	1474	1889	2304	2721	3137
6'-6" (78")	PRECAST	937	1255	2101	3263	4425	5587	6749	7911
7'-6" (90")	PRECAST	767	1029	1675	2385	3095	3805	4515	5225
8'-0" (96")	PRECAST	670	830	1362	1927	2492	3057	3622	4187
8'-8" (104")	PRECAST	618	767	1257	1779	2299	2819	3339	3859
9'-4" (112")	PRECAST	573	632	1049	1469	1889	2309	2729	3149
10'-6" (126")	PRECAST	456	482	802	1125	1448	1771	2094	2417
11'-4" (136")	PRECAST	445	458	735	1058	1381	1704	2027	2350
12'-0" (144")	PRECAST	414	427	726	1028	1351	1674	1997	2320
13'-4" (160")	PRECAST	362	381	648	919	1190	1462	1734	2006
14'-0" (168")	PRECAST	338	355	600	831	1062	1293	1524	1755
14'-8" (176")	PRESTRESSED	N.R.	NR	NR	NR	NR	NR	NR	NR
15'-4" (184")	PRESTRESSED	N.R.	NR	NR	NR	NR	NR	NR	NR
17'-4" (208")	PRESTRESSED	N.R.	NR	NR	NR	NR	NR	NR	NR
19'-4" (232")	PRESTRESSED	N.R.	NR	NR	NR	NR	NR	NR	NR
21'-4" (256")	PRESTRESSED	N.R.	NR	NR	NR	NR	NR	NR	NR
22'-0" (264")	PRESTRESSED	N.R.	NR	NR	NR	NR	NR	NR	NR
24'-0" (288")	PRESTRESSED	N.R.	NR	NR	NR	NR	NR	NR	NR

8" PRECAST W/ 2" RECESS DOOR U-LINTELS									
GRAVITY									
LENGTH	TYPE	8RU6	8RF6-0B	8RF10-0B	8RF14-0B	8RF18-0B	8RF22-0B	8RF26-0B	8RF30-0B
4'-4" (52")	PRECAST	1489	1591	3053	4515	5977	7439	8901	10363
4'-6" (54")	PRECAST	1357	1449	2782	4143	5471	6800	8128	9457
5'-8" (68")	PRECAST	785	832	1602	2350	3098	3846	4594	5342
5'-10" (70")	PRECAST	735	779	1500	2149	2798	3447	4096	4745
6'-8" (80")	PRECAST	622	666	1377	1926	2475	3024	3573	4122
7'-6" (90")	PRECAST	665	709	1475	2024	2573	3122	3671	4220
9'-8" (116")	PRECAST	371	420	834	1253	1672	2091	2510	2929

8" PRECAST & PRESTRESSED U-LINTELS										
UPLIFT										
LENGTH	TYPE	8F8-1T	8F12-1T	8F16-1T	8F20-1T	8F24-1T	8F28-1T	8F32-1T	8U8	8F8
2'-10" (34")	PRECAST	2727	2878	4101	5324	6547	7770	8993	2021	2021
3'-6" (42")	PRECAST	2165	2289	3260	4231	5202	6173	7144	1257	1257
4'-0" (48")	PRECAST	1878	1989	2832	3680	4528	5376	6224	938	938
4'-6" (54")	PRECAST	1660	1762	2507	3257	4007	4757	5507	727	727
5'-4" (64")	PRECAST	1393	1437	2050	2670	3290	3910	4530	505	505
5'-10" (70")	PRECAST	1141	1200	1733	2250	2769	3288	3807	418	418
6'-6" (78")	PRECAST	1141	1182	1684	2192	2700	3208	3716	707	887
7'-6" (90")	PRECAST	990	1029	1468	1907	2346	2785	3224	591	657
9'-4" (112")	PRECAST	801	850	1192	1550	1908	2266	2624	454	630
10'-6" (126")	PRECAST	716	765	1039	1389	1739	2089	2439	396	493
11'-4" (136")	PRECAST	666	715	982	1282	1582	1882	2182	363	556
14'-0" (168")	PRECAST	548	597	810	1060	1310	1560	1810	286	360
14'-8" (176")	PRESTRESSED	243	295	459	591	724	857	990	N.R.	357
15'-4" (184")	PRESTRESSED	228	278	430	553	677	801	925	N.R.	325
17'-4" (208")	PRESTRESSED	188	236	361	484	607	730	853	N.R.	257
19'-4" (232")	PRESTRESSED	165	207	313	401	490	578	667	N.R.	204
21'-4" (256")	PRESTRESSED	145	186	278	356	433	512	590	N.R.	172
22'-0" (264")	PRESTRESSED	140	180	268	343	418	493	568	N.R.	161
24'-0" (288")	PRESTRESSED	124	166	240	308	376	444	512	N.R.	135

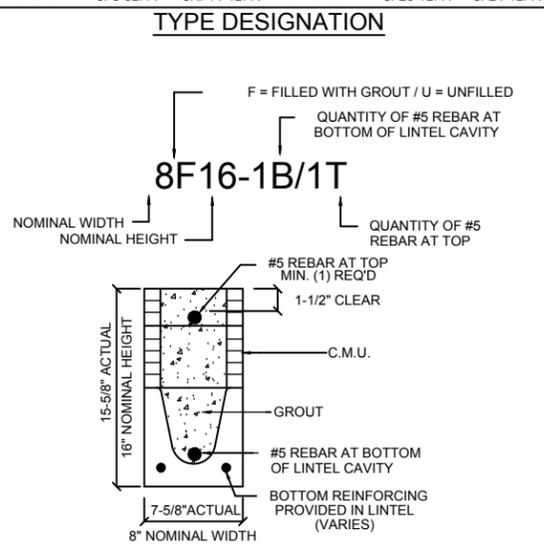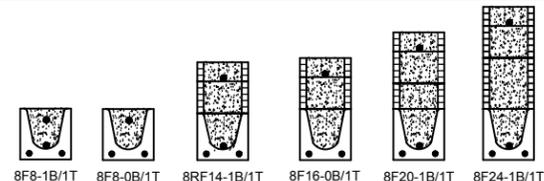


- ### MATERIALS
1. P/c precast lintels = 3500 psi.
  2. P/c prestressed lintels = 6000 psi.
  3. P/c grout = 3000 psi w/ maximum 3/8" aggregate.
  4. Concrete masonry units (CMU) per ASTM C90 w/ minimum net area compressive strength = 1900 psi.
  5. Rebar provided in precast lintel per ASTM A615 GR60. Field rebar per ASTM A615 GR40 or GR60.
  6. Prestressing strand per ASTM A416 grade 270 low relaxation.
  7. 7/32" wire per ASTM A510.
  8. Mortar per ASTM C270 type M or S.

- ### GENERAL NOTES
1. Provide full mortar head and bed joints.
  2. Shore filled lintels as required.
  3. Installation of lintel must comply with the architectural and/or structural drawings.
  4. Lintels are manufactured with 5-1/2" long notches at the ends to accommodate vertical cell reinforcing and grouting.
  5. All lintels meet or exceed L/360 vertical deflection, except lintels 17'-4" and longer with a nominal height of 8" meet or exceed L/180.
  6. Bottom field added rebar to be located at the bottom of the lintel cavity.
  7. 7/32" diameter wire stirrups are welded to the bottom steel for mechanical anchorage.
  8. Cast-in-place concrete may be provided in composite lintel in lieu of concrete masonry units.
  9. Safe load ratings based on rational design analysis per ACI 318 and ACI 530.

- ### SAFE LOAD TABLE NOTES
1. All values based on minimum 4" bearing. Exception: Safe loads for unfilled lintels must be reduced by 20% if bearing length is less than 6-1/2". Safe loads for all recessed lintels based on 8" nominal bearing.
  2. N.R. = Not Rated.
  3. Safe loads are total superimposed allowable load on the section specified.
  4. Safe loads based on grade 40 or grade 60 field rebar.
  5. Additional lateral load capacity can be obtained by the designer by providing additional reinforced masonry above the precast lintel.
  6. One #7 rebar may be substituted for two #5 rebars in 8" lintels only.
  7. The designer may evaluate concentrated loads from the safe load tables by calculating the maximum resisting moment and shear at d-away from the face of support.
  8. For composite lintel heights not shown, use safe load from next lower height.
  9. All safe loads in units of pounds per linear foot.

8" PRECAST W/ 2" RECESS DOOR U-LINTELS										
UPLIFT										
LENGTH	TYPE	8RF6-1T	8RF10-1T	8RF14-1T	8RF18-1T	8RF22-1T	8RF26-1T	8RF30-1T	8RU6	8RF6
4'-4" (52")	PRECAST	1244	1573	2413	3260	4112	4967	5825	932	932
4'-6" (54")	PRECAST	1192	1507	2311	3121	3937	4756	5577	853	853
5'-8" (68")	PRECAST	924	1132	1741	2357	2978	3603	4230	501	501
5'-10" (70")	PRECAST	896	1138	1742	2352	2965	3581	4198	469	469
6'-8" (80")	PRECAST	778	956	1455	1987	2520	3053	3586	830	1100
7'-6" (90")	PRECAST	688	868	1325	1810	2280	2753	3227	710	941
9'-8" (116")	PRECAST	533	688	1028	1389	1748	2108	2468	516	614

CAST CRETE / LOTTS / WEKIWA / FLORIDA ROCK - PRECAST LINTEL SCHEDULE			
LINTEL NO.	LENGTH	TYPE	COMMENTS
L-1	17'-4"	8F28-1B/1T	GARAGE
L-2	7'-6"	8F16-1B/1T	FR SH25
L-3	7'-6"	8F24-1B/1T	6/10X6/8 SGD
L-4	14'-0"	8F16-1B/1T	LANAI
L-5	4'-6"	8F16-1B/1T	SH25
L-6	7'-6"	8F32-1B/1T	ENTRY
L-7	4'-6"	8RF38-1B/1T	3068 DR

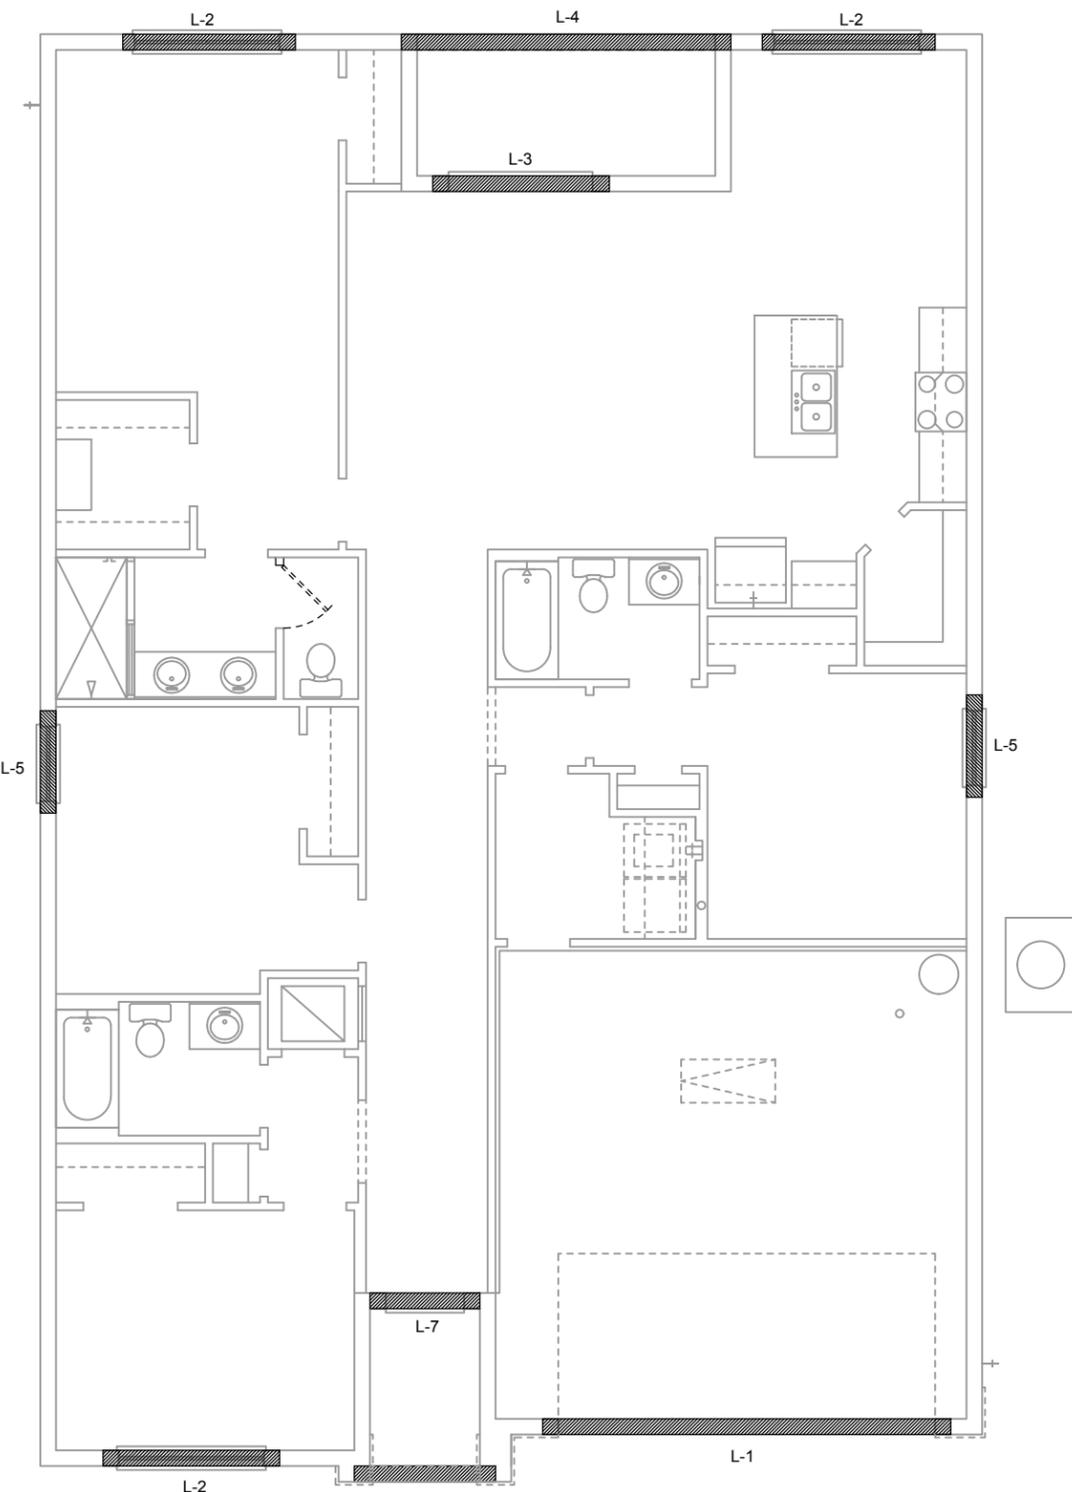

## PRECAST LINTEL PLAN C (STANDARD) 1/8"=1'-0" (11x7) 1/4"=1'-0" (22x4)



LOT: 0000, COMMUNITY  
 1860 SKY  
 40' EXPLORATION SERIES  
 PRECAST LINTEL PLAN  
 A DIVISION OF PARK SQUARE ENTERPRISES, INC.  
 5200 Vineyard Road, Suite 200  
 Orlando, Florida 32818  
 Phone: (407) 529-3000  
 HITEG  
 HILMIPSON ENGINEERING GROUP, INC.  
 1100 S. Orange Ave., Suite 200  
 Orlando, Florida 32801  
 Phone: (407) 734-8600  
 Fax: (407) 734-1790  
 www.hiteg.com

REVISIONS	
DELTA #	DATE

DATE: 09-11-25  
 SCALE: AS NOTED  
 DRAWN: MR  
 SHEET: S2

# CONNECTOR SCHEDULE

CONNECT. TYPE	SIMPSON		MAX. UPLIFT	LAT. LDS. F1 / F2
	DESCRIPTION	FASTENERS PER CONNECTOR		
4	HETA16	9-10d x 1 1/2"	1,810	65 / 960
5	DETAL20	18-10d x 1 1/2"	2,480	2000 / 1370
20	H3	RFT: 4-8d / PLT: 4-8d	400	210 / 170
21	H1	RFT: 6-8dx1 1/2" / PLT: 4-8d	480	510 / 165
22	H10S	RFT: 8-8d x 1 1/2"	1010	660 / 550
23	LUS26	HDR: 4-10d / JST: 4-10d	935	N/A
24	H7	RFT / TRS: 4-8d	985	400 / N/A
26	H2.5	PLT / STD: 10-8d	415	150 / 150
34	A34	RFT: 5-8d / PLT: 5-8d	415	150 / 150
35	A35F	H: 4-8dx1 1/2" / P: 4-8dx1 1/2"	365	280 / 303
37	HTS16	H: 4-8dx1 1/2" / P: 4-8dx1 1/2"	440	440 / N/A
38	MTS16	14-10d	1,310	N/A
39	MTS30	14-10d	990	N/A
43	LSTA12	14-10d	990	N/A
45	ST18	10-10d	905	N/A
47	LSTA24	14-16d	1,200	N/A
71	MSTA36	18-10d	1,295	N/A
72	MSTC66	26-10d	2,135	N/A
79	SP1	64-16d SINKERS	5,495	N/A
80	SP2	STD: 6-10d / PLT: 4-10d	535	560 / 260
81	SPH4,6,8	STD: 6-10d / PLT: 6-10d	605	560 / 260
90	ABU66	12-10d x 1 1/2"	885	N/A
92	CB66	12-16d	2,240	N/A
93	AC6 (MAX)	(2) 7/8" BOLTS	2,300	985
94	AC4 (MAX)	12-16d	2,200	N/A
95	HTS20	28-16d	1,815	1,070
96	HD8A	28-16d	1,815	1,070
97	MTSM16	20-10d	1,450	N/A
98	HTT4	SILL: 7/8" BOLT STUD: (3) 7/8"x5 1/2" BOLTS	7,910	N/A
99	A35	BLOCK: 4-1/2"x2 1/4" TC JOIST: 7-10d	860	N/A
102	HTT5	SILL: 5/8" BOLT STRAP: 18-16d	4,235	N/A
103	VGTR/L	H: 4-8dx1 1/2" / P: 4-8dx1 1/2"	440	440 / N/A
104	HU8-SDS2.5	5/8" BOLT / 26-10d	4,275	N/A
110	HCP1.81	32-SDS 1/2"x3" / (2) 7/8" BLT	3,990	N/A
167	HHUS46	7/8" BLT / 20-SDS 1/4"x2 1/2"	5,020	N/A
168	U46	(6) 0.148 x 1 1/2"	590	255 / N/A
181	HUS26	H: 14-16d / J: 6-16d	1,550	N/A
184	HUC28-2	H: 8-10d / J: 4-10d	710	N/A
214	HUC212-3TF	H: 14-16d / J: 4-10d	1,085	N/A
215	HGUS210-2	HD: 16-3/16"x1 1/2" TAPCON BM: 6-16d	1,135	N/A
216	HUS412	HDR: 46-16d / JST: 10-16d	2,720	N/A
217	HUS212-2	BLOCK: 10-1/2"x1 1/2" TC JOIST: 10-16d	3,240	N/A
219	MBHA412	BLOCK: 10-1/2"x1 1/2" TC JOIST: 10-16d	2,630	N/A
220	N/A	H: 1-ATR3/4X8 TOP&FACE JOIST: 18-10d	3,145	N/A
226	MBHA4.75/12	N/A	1,620	N/A
231	MBHA3.56/16	HDR: (2) 3/4" φ x 8" JOIST: 18-10d	2,160	N/A
232	MBHA5.50/16	HDR: (2) 3/4" φ x 8" JOIST: 18-10d	3,450	N/A
240	H16	R: 2-10dx1 1/2" / P: 10-10dx1 1/2"	1,470	480 / N/A
241	LGT2	30-16d-sinker	2,000	1015 / 440
301	MGT	(1) 5/8" BLTS. / GIR: 22-10d	3,965	N/A
302	HGT-2 or 3	LTL: 3/4" BLTS. / GIR: 8-10d	6,485	N/A
303	HGT-4	LTL: 3/4" BLTS. / GIR: 16-10d	9,250	N/A
401	SUR/L414	FACE: 18-16d / JST: 8-16d	1,700	N/A
T	CONNECTORS TO BE SPECIFIED & PROVIDED BY TRUSS MANUFACTURERS			

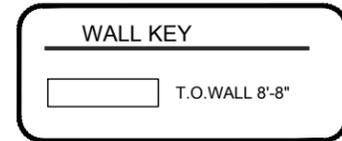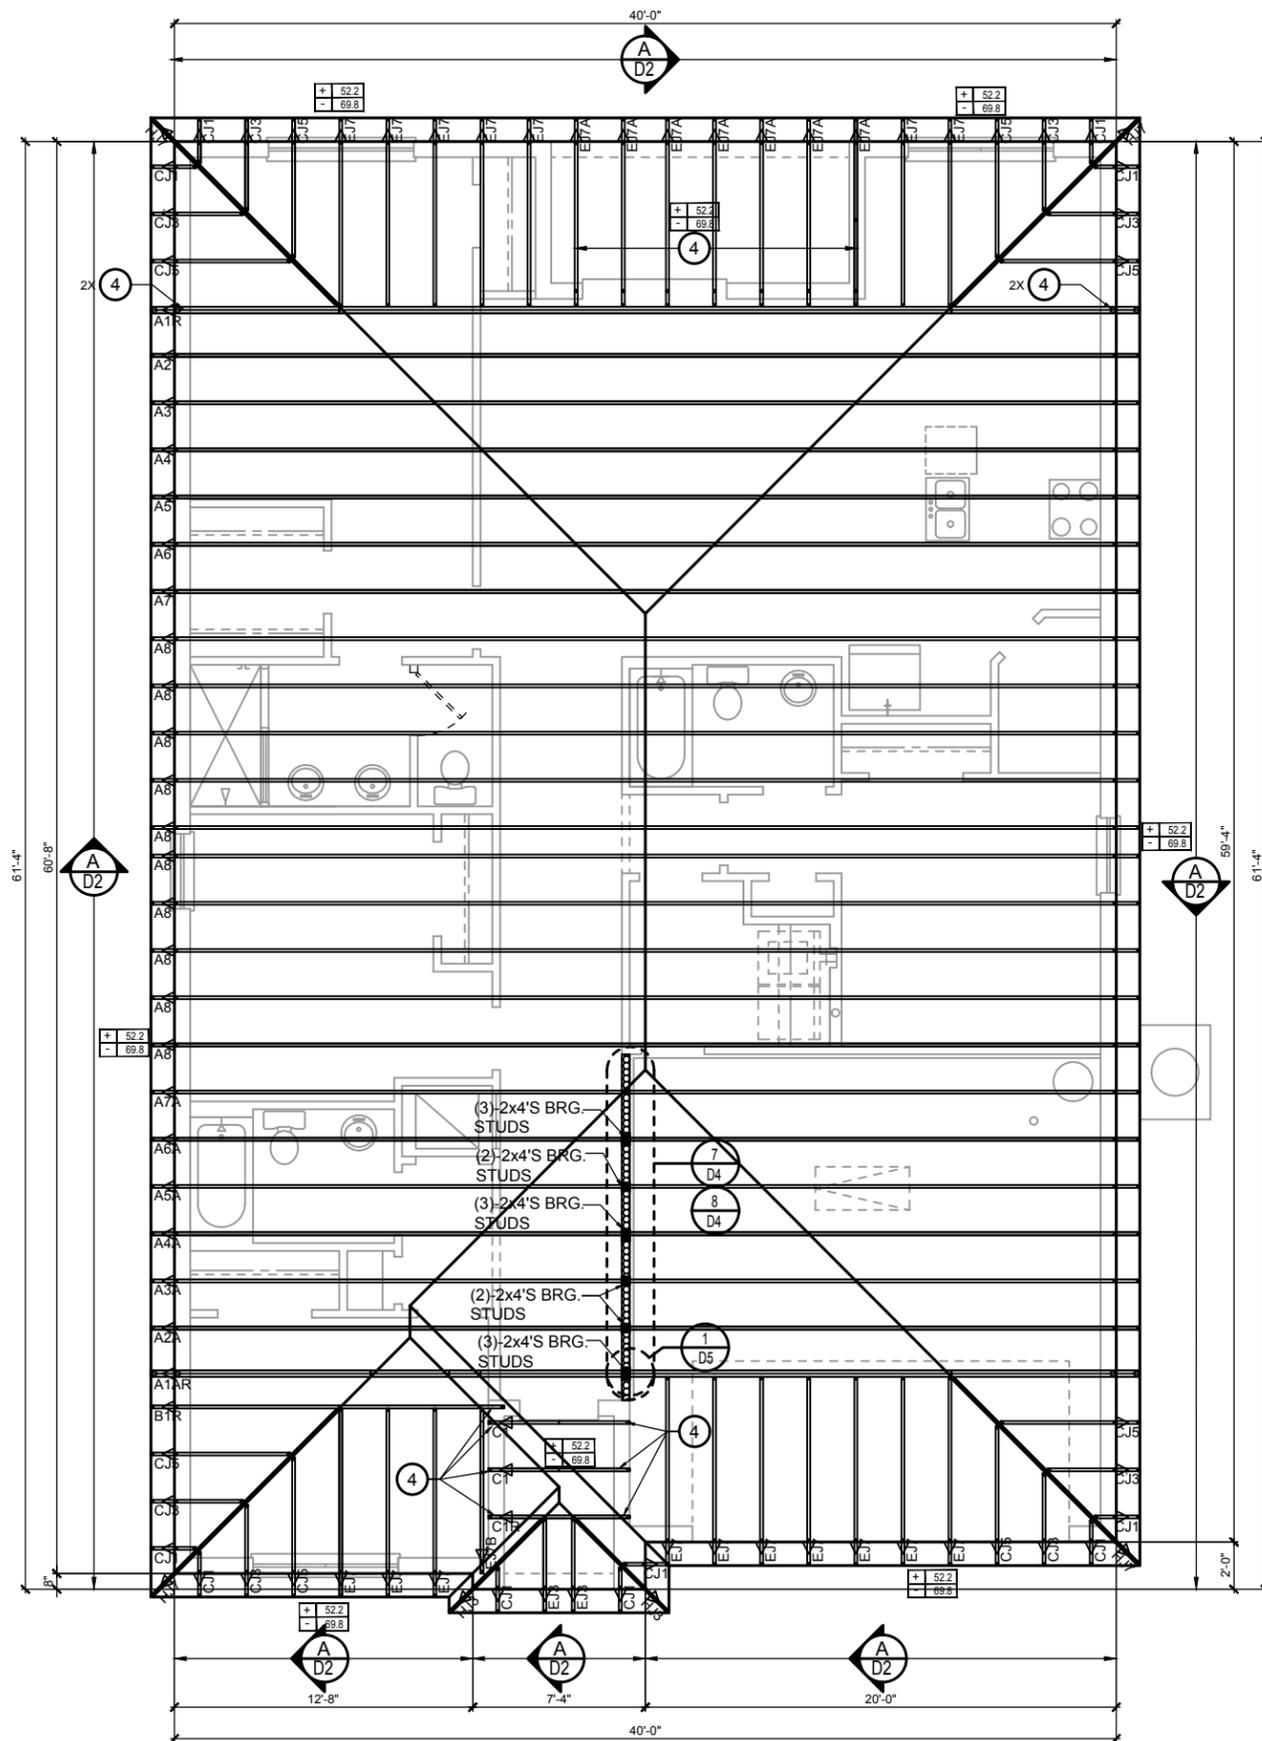

**COMPONENT & CLADDING DESIGN WIND PRESSURES**

SEE PLAN DESIGN WIND PRESSURE

+	XXX	ULTIMATE DESIGNED POSITIVE PRESSURE
-	XXX	ULTIMATE DESIGNED NEGATIVE PRESSURE

NOTE: DESIGN PRESSURES BASED ULTIMATE WIND SPEED TO OBTAIN NOMINAL "AS" WIND PRESSURES MULTIPLY VALUES SHOWN BY A FACTOR OF 0.6

**FIELD REPAIR NOTES**

- MISSED FOOTING DOWELS MAY BE SUBSTITUTED W/ A STRAIGHT #5 REBAR SET IN A 3/4" DIA. x 6" DEEP HOLE FILLED W/ UNITEX PROPOXY 300 OR SIMPSON SET OR ETF ADHESIVES.
- BLOCK WALL OVERHANGING SLAB CONDITION: UP TO 7/8" - NO REPAIR NECESSARY 7/8" TO 1 1/2" - ADD FILLED CELL (NO VERTICAL STEEL) MIDPOINT OF WALL BETWEEN EXISTING FILLED CELLS (WITH STEEL) IN AREAS AFFECTED. 1 1/2" - REQUIRE SPECIAL ENGINEERING LETTER.
- PENETRATION OF PLUMBING PIPES/DRYER VENTS THRU PLATES OF A LOAD BEARING WALL MAY OCCUR PROVIDED DBL. STUDS ARE ADDED ON EITHER SIDE OF PENETRATION WITHIN 3" AND TRUSS/FLOOR TRUSS IS NO CLOSER THAN 3" FROM PENETRATION. ADD (1) MTS12 @ TOP AND BOTTOM PLATE.

**NOTES**

- TYPICAL ROOF GABLE OVERHANG TO BE 12" UNLESS OTHERWISE NOTED.
- TYPICAL ROOF EAVES OVERHANG TO BE 16" UNLESS OTHERWISE NOTED.
- PROVIDE AND INSTALL FLASHING AND ROOFING AS PER NATIONAL ROOFING AND SHEET METAL ASSOC. STANDARDS AND/OR ACCEPTABLE INDUSTRY PRACTICE AND IN ACCORDANCE WITH 8TH EDITION (2023) FLORIDA RESIDENTIAL CODE.
- ALL ROOF TRUSSES, GIRDERS, BEAMS, HEADERS, ETC. TO BE SIZE BY TRUSS MANUFACTURER OR FL. REG. ENG.
- TRUSSES SHALL BE BRACED TO PREVENT ROTATION & PROVIDE LATERAL STABILITY IN ACCORDANCE WITH THE REQUIREMENTS SPECIFIED IN THE CONSTRUCTION DOCUMENTS FOR BUILDING & ON THE INDIVIDUAL TRUSS DESIGN DRAWINGS IN THE ABSENCE OF SPECIFIC BRACING REQUIREMENTS, TRUSSES SHALL BE BRACED IN ACCORDANCE WITH TPI/WTCA BCS1.1.
- REFER TO TRUSS MANUFACTURERS DRAWINGS FOR TRUSS PLACEMENT & TRUSS TO TRUSS CONNECTIONS.
- ROOF UNDERLAYMENT TO BE USED IS 30 LBS. SYNTHETIC FELT.
- SHINGLE ROOF: UNDERLAYMENT TO BE INSTALLED IAW FBCR 2023, 8TH EDITION R905.1.1.1 UNDERLAYMENT MATERIALS REQUIRED TO COMPLY WITH ASTM D226, D1970, D4869 AND D6757 SHALL BEAR A LABEL INDICATING COMPLIANCE TO THE STANDARD DESIGNATION AND, IF APPLICABLE, TYPE CLASSIFICATION INDICATED IN TABLE R905.1.1.1 UNDERLAYMENT SHALL BE APPLIED AND ATTACHED IN ACCORDANCE WITH TABLE R905.1.1.1
- OFF RIDGE VENTS MAXIMUM OPENING SIZES: REFER TO MANUFACTURE SPECIFICATIONS.

**ROOF FRAMING PLAN**  
A (STANDARD)  
1/8"=1'-0" (11x17) 1/4"=1'-0" (22x37)

THIS STRUCTURE IS DESIGNED IN ACCORDANCE WITH THE 8th EDITION, 2023 OF THE FLORIDA BUILDING CODE-RESIDENTIAL AND IS CERTIFIED AS SUCH  
**LOT: 0000, COMMUNITY**  
**1860 SKY**  
**40' EXPLORATION SERIES**  
**S3**

**REVISIONS**  
 DELTA #      DATE  
 DATE: 09-11-25  
 SCALE: AS NOTED  
 DRAWN: MR  
 SHEET:



**ITEG**  
 THOMPSON ENGINEERING GROUP, INC.  
 A DIVISION OF PARK SQUARE ENTERPRISES, INC.  
 5200 Vineyard Road, Suite 200  
 Orlando, Florida 32811  
 Phone: (407) 734-1790  
 Fax: (407) 734-1792  
 www.iteg.com

**Park Square HOMES**  
 ROOF FRAMING PLAN

DISCLAIMER: CONTRACTOR/SUB-CONTRACTOR IS RESPONSIBLE TO REVIEW ALL INFORMATION CONTAINED HEREIN PRIOR TO COMMENCEMENT OF CONSTRUCTION. PARK SQUARE HOMES IS NOT RESPONSIBLE FOR ANY MISINTERPRETATIONS, ERRORS, OMISSIONS OR CUSTOM CHANGES MISSED AND NOT REPORTED PRIOR TO CONSTRUCTION. NO EXCEPTIONS.

# CONNECTOR SCHEDULE

CONNECT. TYPE	SIMPSON		MAX. UPLIFT	LAT. LDS. F1 / F2
	DESCRIPTION	FASTENERS PER CONNECTOR		
4	HETA16	9-10d x 1 1/2"	1,810	65 / 960
5	DETA20	18-10d x 1 1/2"	2,480	2000 / 1370
20	H3	RFT: 4-8d / PLT: 4-8d	400	210 / 170
21	H1	RFT: 6-8dx1 1/2" / PLT: 4-8d	480	510 / 165
22	H10S	RFT: 8-8d x 1 1/2" PLT: 8-8d x 1 1/2"	1010	660 / 550
23	LUS26	HDR: 4-10d / JST: 4-10d	935	N/A
24	H7	RFT / TRS: 4-8d PLT / STD: 10-8d	985	400 / N/A
26	H2.5	RFT: 5-8d / PLT: 5-8d	415	150 / 150
34	A34	H: 4-8dx1 1/2" / P: 4-8dx1 1/2"	365	280 / 303
35	A35F	H: 4-8dx1 1/2" / P: 4-8dx1 1/2"	440	440 / N/A
37	HTS16	14-10d	1,310	N/A
38	MTS16	14-10d	990	N/A
39	MTS30	14-10d	990	N/A
43	LSTA12	10-10d	905	N/A
45	ST18	14-16d	1,200	N/A
47	LSTA24	18-10d	1,295	N/A
71	MSTA36	26-10d	2,135	N/A
72	MSTC66	64-16d SINKERS	5,495	N/A
79	SP1	STD: 6-10d / PLT: 4-10d	535	560 / 260
80	SP2	STD: 6-10d / PLT: 6-10d	605	560 / 260
81	SPH4,6,8	12-10d x 1 1/2"	885	N/A
90	ABU66	12-16d	2,240	N/A
89	CB66	(2) 7/8" BOLTS	2,300	985
92	ABU44	12-16d	2,200	N/A
93	AC6 (MAX)	28-16d	1,815	1,070
94	AC4 (MAX)	28-16d	1,815	1,070
95	HTS20	20-10d	1,450	N/A
96	HD8A	SILL: 7/8" BOLT STUD: (3) 7/8"x5 1/2" BOLTS	7,910	N/A
97	MTSM16	BLOCK: 4-1/2"x2 1/4" TC JOIST: 7-10d	860	N/A
98	HTT4	SILL: 5/8" BOLT STRAP: 18-16d	4,235	N/A
99	A35	H: 4-8dx1 1/2" / P: 4-8dx1 1/2"	440	440 / N/A
102	HTT5	5/8" BOLT / 26-10d	4,275	N/A
103	VGTR/L	32-SDS 1/2"x3" / (2) 7/8" BLT	3,990	N/A
104	HU8-SDS2.5	7/8" BLT / 20-SDS 1/4"x2 1/2"	5,020	N/A
110	HCP1.81	(6) 0.148 x 1 1/2"	590	255 / N/A
167	HHUS46	H: 14-16d / J: 6-16d	1,550	N/A
168	U46	H: 8-10d / J: 4-10d	710	N/A
181	HUS26	20-16d	1,550	N/A
184	HUC28-2	H: 14-16d / J: 4-10d	1,085	N/A
214	HUC212-3TF	HD: 16-3/16"x1 1/2" TAPCON BM: 6-16d	1,135	N/A
215	HGUS210-2	HDR: 46-16d / JST: 10-16d	2,720	N/A
216	HUS412	BLOCK: 10-1/2"x1 1/2" TC JOIST: 10-16d	3,240	N/A
217	HUS212-2	BLOCK: 10-1/2"x1 1/2" TC JOIST: 10-16d	2,630	N/A
219	MBHA412	H: 1-ATR3/4X8 TOP&FACE JOIST: 18-10d	3,145	N/A
220	N/A	N/A	1,620	N/A
226	MBHA4.75/12	HDR: (2) 3/4" φ x 8" JOIST: 18-10d	2,160	N/A
231	MBHA3.56/16	HDR: (2) 3/4" φ x 8" JOIST: 18-10d	3,450	N/A
232	MBHA5.50/16	HDR: (2) 3/4" φ x 8" JOIST: 18-10d	3,450	N/A
240	H16	R: 2-10dx1 1/2" / P: 10-10dx1 1/2"	1,470	480 / N/A
241	LGT2	30-16d-sinker	2000	1015 / 440
301	MGT	(1) 5/8" BLTS. / GIR: 22-10d	3,965	N/A
302	HGT-2 or 3	LTL: 3/4" BLTS. / GIR: 8-10d	6485	N/A
303	HGT-4	LTL: 3/4" BLTS. / GIR: 16-10d	9,250	N/A
401	SUR/L414	FACE: 18-16d / JST: 8-16d	1,700	N/A
T	CONNECTORS TO BE SPECIFIED & PROVIDED BY TRUSS MANUFACTURERS			

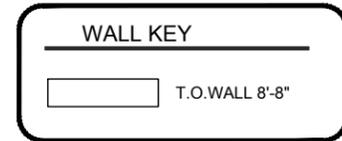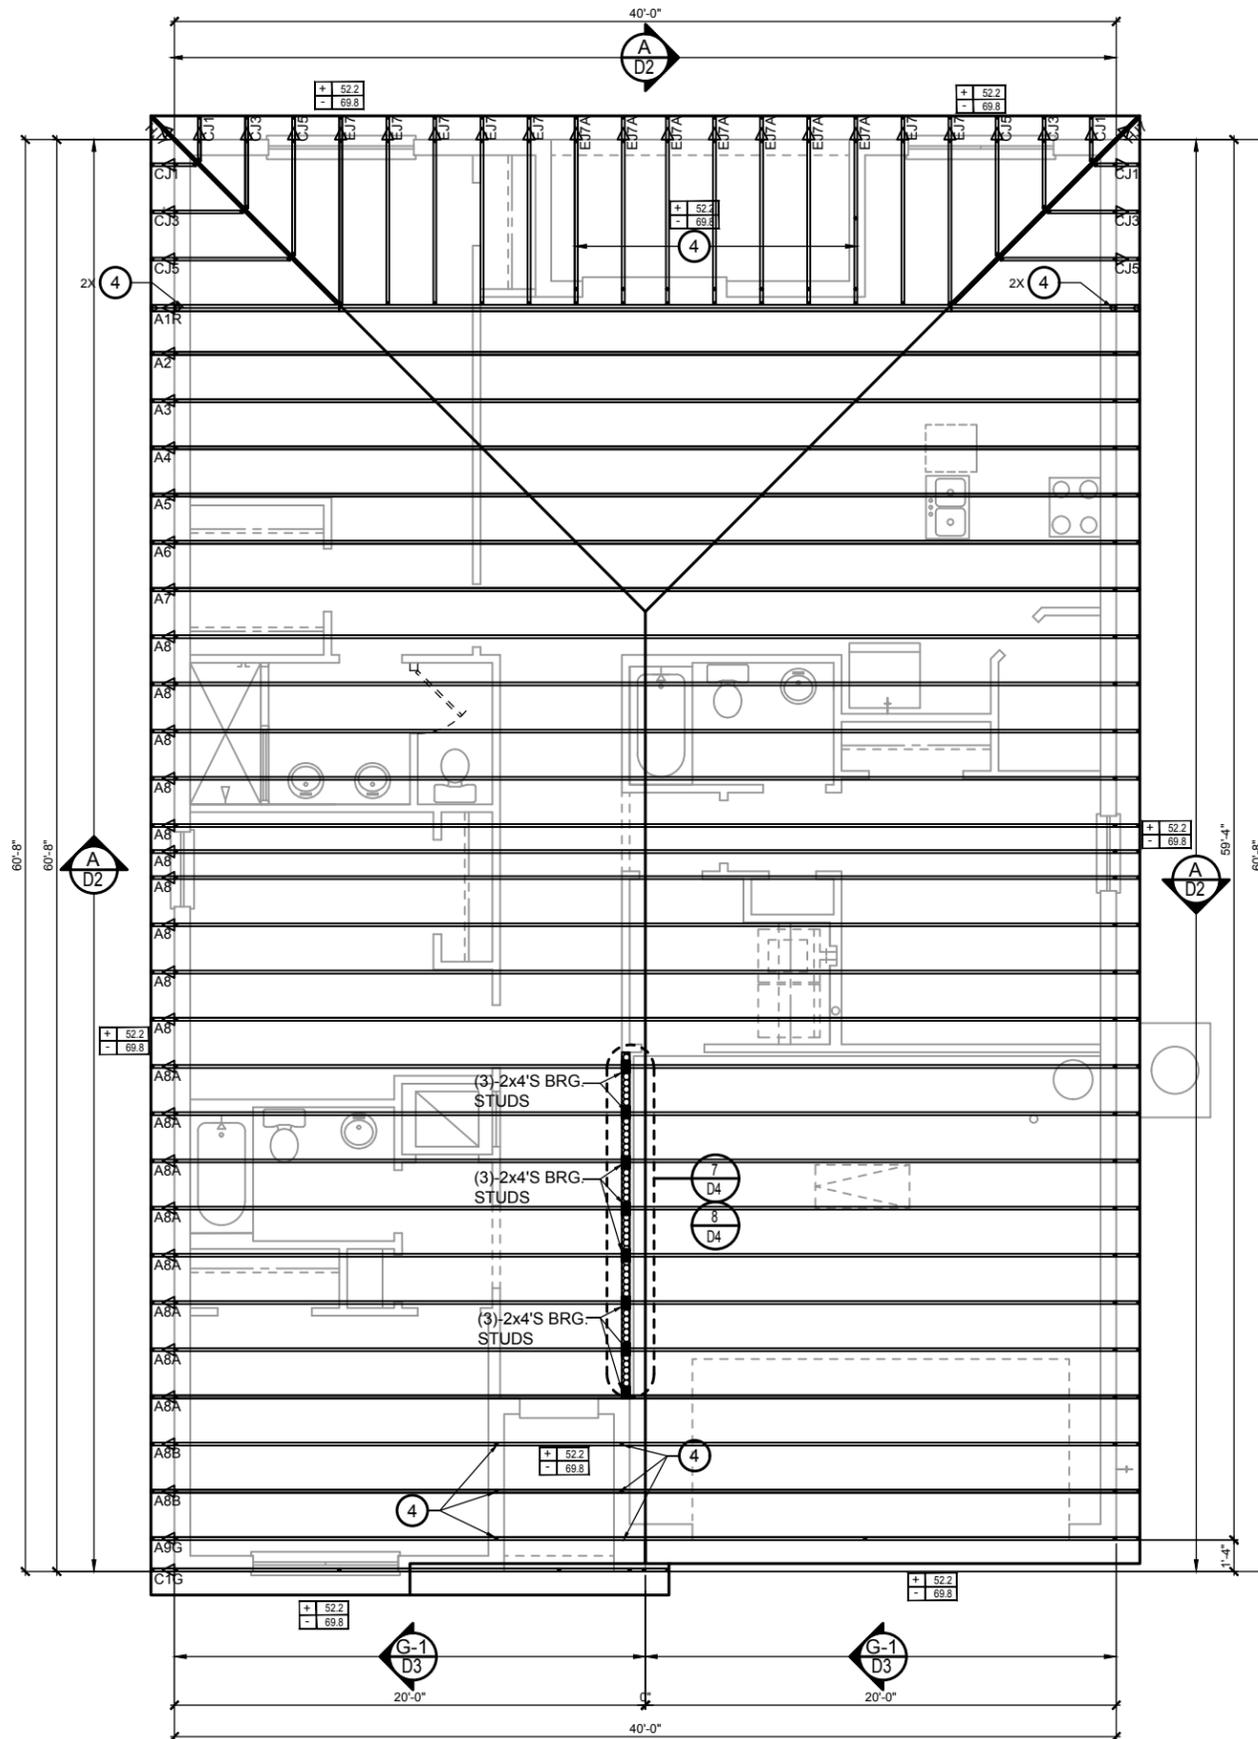

**COMPONENT & CLADDING DESIGN WIND PRESSURES**

SEE PLAN DESIGN WIND PRESSURE

+ .XXX	ULTIMATE DESIGNED POSITIVE PRESSURE
- .XXX	ULTIMATE DESIGNED NEGATIVE PRESSURE

NOTE: DESIGN PRESSURES BASED ULTIMATE WIND SPEED TO OBTAIN NOMINAL "AS" WIND PRESSURES MULTIPLY VALUES SHOWN BY A FACTOR OF 0.6

**FIELD REPAIR NOTES**

- MISSED FOOTING DOWELS MAY BE SUBSTITUTED W/ A STRAIGHT #5 REBAR SET IN A 3/4" DIA. x 6" DEEP HOLE FILLED W/ UNITEX PROPOXY 300 OR SIMPSON SET OR ETF ADHESIVES.
- BLOCK WALL OVERHANGING SLAB CONDITION: UP TO 7/8" - NO REPAIR NECESSARY 7/8" TO 1 1/2" - ADD FILLED CELL (NO VERTICAL STEEL) MIDPOINT OF WALL BETWEEN EXISTING FILLED CELLS (WITH STEEL) IN AREAS AFFECTED. 1 1/2" - REQUIRE SPECIAL ENGINEERING LETTER.
- PENETRATION OF PLUMBING PIPES/DRYER VENTS THRU PLATES OF A LOAD BEARING WALL MAY OCCUR PROVIDED DBL. STUDS ARE ADDED ON EITHER SIDE OF PENETRATION WITHIN 3" AND TRUSS/FLOOR TRUSS IS NO CLOSER THAN 3" FROM PENETRATION. ADD (1) MTS12 @ TOP AND BOTTOM PLATE.

**NOTES**

- TYPICAL ROOF GABLE OVERHANG TO BE 12" UNLESS OTHERWISE NOTED.
- TYPICAL ROOF EAVES OVERHANG TO BE 16" UNLESS OTHERWISE NOTED.
- PROVIDE AND INSTALL FLASHING AND ROOFING AS PER NATIONAL ROOFING AND SHEET METAL ASSOC. STANDARDS AND/OR ACCEPTABLE INDUSTRY PRACTICE AND IN ACCORDANCE WITH 8TH EDITION (2023) FLORIDA RESIDENTIAL CODE.
- ALL ROOF TRUSSES, GIRDERS, BEAMS, HEADERS, ETC. TO BE SIZE BY TRUSS MANUFACTURER OR FL. REG. ENG.
- TRUSSES SHALL BE BRACED TO PREVENT ROTATION & PROVIDE LATERAL STABILITY IN ACCORDANCE WITH THE REQUIREMENTS SPECIFIED IN THE CONSTRUCTION DOCUMENTS FOR BUILDING & ON THE INDIVIDUAL TRUSS DESIGN DRAWINGS IN THE ABSENCE OF SPECIFIC BRACING REQUIREMENTS, TRUSSES SHALL BE BRACED IN ACCORDANCE WITH TPI/WTCA BCS1.
- REFER TO TRUSS MANUFACTURERS DRAWINGS FOR TRUSS PLACEMENT & TRUSS TO TRUSS CONNECTIONS.
- ROOF UNDERLAYMENT TO BE USED IS 30 LBS. SYNTHETIC FELT.
- SHINGLE ROOF: UNDERLAYMENT TO BE INSTALLED IAW FBCR 2023, 8TH EDITION R905.1.1.1 UNDERLAYMENT MATERIALS REQUIRED TO COMPLY WITH ASTM D226, D1970, D4869 AND D6757 SHALL BEAR A LABEL INDICATING COMPLIANCE TO THE STANDARD DESIGNATION AND, IF APPLICABLE, TYPE CLASSIFICATION INDICATED IN TABLE R905.1.1.1 UNDERLAYMENT SHALL BE APPLIED AND ATTACHED IN ACCORDANCE WITH TABLE R905.1.1.1
- OFF RIDGE VENTS MAXIMUM OPENING SIZES: REFER TO MANUFACTURE SPECIFICATIONS.

**ROOF FRAMING PLAN**  
B (STANDARD)  
1/8"=1'-0" (11x17) 1/4"=1'-0" (22x37)

THIS STRUCTURE IS DESIGNED IN ACCORDANCE WITH THE 8th EDITION, 2023 OF THE FLORIDA BUILDING CODE-RESIDENTIAL AND IS CERTIFIED AS SUCH.  
**LOT: 0000, COMMUNITY**  
**1860 SKY**  
**40' EXPLORATION SERIES**  
**S3**

**REVISIONS**  
 DELTA #      DATE  
 DATE: 09-11-25  
 SCALE: AS NOTED  
 DRAWN: MR  
 SHEET:



**ITEG**  
 THOMPSON ENGINEERING GROUP, INC.  
 A DIVISION OF PARK SQUARE ENTERPRISES, INC.  
 5200 Vineyard Road, Suite 200  
 Orlando, Florida 32811  
 Phone: (407) 734-1790  
 Fax: (407) 734-1792  
 www.iteg.com

**Park Square HOMES**  
 ROOF FRAMING PLAN

DISCLAIMER: CONTRACTOR/SUB-CONTRACTOR IS RESPONSIBLE TO REVIEW ALL INFORMATION CONTAINED HEREIN PRIOR TO COMMENCEMENT OF CONSTRUCTION. PARK SQUARE HOMES IS NOT RESPONSIBLE FOR ANY MISINTERPRETATIONS, ERRORS, OMISSIONS OR CUSTOM CHANGES MISSED AND NOT REPORTED PRIOR TO CONSTRUCTION. NO EXCEPTIONS.

# CONNECTOR SCHEDULE

CONNECT. TYPE	SIMPSON		MAX. UPLIFT	LAT. LDS. F1 / F2
	DESCRIPTION	FASTENERS PER CONNECTOR		
4	HETA16	9-10d x 1 1/2"	1,810	65 / 960
5	DETA120	18-10d x 1 1/2"	2,480	2000 / 1370
20	H3	RFT: 4-8d / PLT: 4-8d	400	210 / 170
21	H1	RFT: 6-8dx1 1/2" / PLT: 4-8d	480	510 / 165
22	H10S	RFT: 8-8d x 1 1/2"	1010	660 / 550
23	LUS26	HDR: 4-10d / JST: 4-10d	935	N/A
24	H7	RFT / TRS: 4-8d PLT / STD: 10-8d	985	400 / N/A
26	H2.5	RFT: 5-8d / PLT: 5-8d	415	150 / 150
34	A34	H: 4-8dx1 1/2" / P: 4-8dx1 1/2"	365	280 / 303
35	A35F	H: 4-8dx1 1/2" / P: 4-8dx1 1/2"	440	440 / N/A
37	HTS16	14-10d	1,310	N/A
38	MTS16	14-10d	990	N/A
39	MTS30	14-10d	990	N/A
43	LSTA12	10-10d	905	N/A
45	ST18	14-16d	1,200	N/A
47	LSTA24	18-10d	1,295	N/A
71	MSTA36	26-10d	2,135	N/A
72	MSTC66	64-16d SINKERS	5,495	N/A
79	SP1	STD: 6-10d / PLT: 4-10d	535	560 / 260
80	SP2	STD: 6-10d / PLT: 6-10d	605	560 / 260
81	SPH4,6,8	12-10d x 1 1/2"	885	N/A
90	ABU66	12-16d	2,240	N/A
89	CB66	(2) 7/8" BOLTS	2,300	985
92	ABU44	12-16d	2,200	N/A
93	AC6 (MAX)	28-16d	1,815	1,070
94	AC4 (MAX)	28-16d	1,815	1,070
95	HTS20	20-10d	1,450	N/A
96	HD8A	SILL: 7/8" BOLT STUD: (3) 7/8"x5 1/2" BOLTS	7,910	N/A
97	MTSM16	BLOCK: 4-1/2"x2 1/4" TC JOIST: 7-10d	860	N/A
98	HTT4	SILL: 5/8" BOLT STRAP: 18-16d	4,235	N/A
99	A35	H: 4-8dx1 1/2" / P: 4-8dx1 1/2"	440	440 / N/A
102	HTT5	5/8" BOLT / 26-10d	4,275	N/A
103	VGTR/L	32-SDS 1/2"x3" / (2) 7/8" BLT	3,990	N/A
104	HU8-SDS2.5	7/8" BLT / 20-SDS 1/4"x2 1/2"	5,020	N/A
110	HCP1.81	(6) 0.148 x 1 1/2"	590	255 / N/A
167	HHUS46	H: 14-16d / J: 6-16d	1,550	N/A
168	U46	H: 8-10d / J: 4-10d	710	N/A
181	HUS26	20-16d	1,550	N/A
184	HUC28-2	H: 14-16d / J: 4-10d	1,085	N/A
214	HUC212-3TF	HD: 16-3/16"x1 1/2" TAPCON BM: 6-16d	1,135	N/A
215	HGUS210-2	HDR: 46-16d / JST: 10-16d	2,720	N/A
216	HUS412	BLOCK: 10-1/2"x1 1/2" TC JOIST: 10-16d	3,240	N/A
217	HUS212-2	BLOCK: 10-1/2"x1 1/2" TC JOIST: 10-16d	2,630	N/A
219	MBHA412	H: 1-ATR3/4X8 TOP&FACE JOIST: 18-10d	3,145	N/A
220	N/A	N/A	1,620	N/A
226	MBHA4.75/12	HDR: (2) 3/4" φ x 8" JOIST: 18-10d	2,160	N/A
231	MBHA3.56/16	HDR: (2) 3/4" φ x 8" JOIST: 18-10d	3,450	N/A
232	MBHA5.50/16	HDR: (2) 3/4" φ x 8" JOIST: 18-10d	3,450	N/A
240	H16	R: 2-10dx1 1/2" / P: 10-10dx1 1/2"	1,470	480 / N/A
241	LGT2	30-16d-sinker	2,000	1015 / 440
301	MGT	(1) 5/8" BLTS. / GIR: 22-10d	3,965	N/A
302	HGT-2 or 3	LTL: 3/4" BLTS. / GIR: 8-10d	6,485	N/A
303	HGT-4	LTL: 3/4" BLTS. / GIR: 16-10d	9,250	N/A
401	SUR/L414	FACE: 18-16d / JST: 8-16d	1,700	N/A
T	CONNECTORS TO BE SPECIFIED & PROVIDED BY TRUSS MANUFACTURERS			

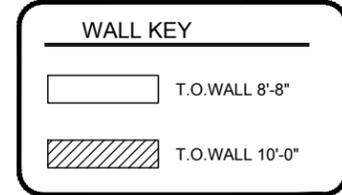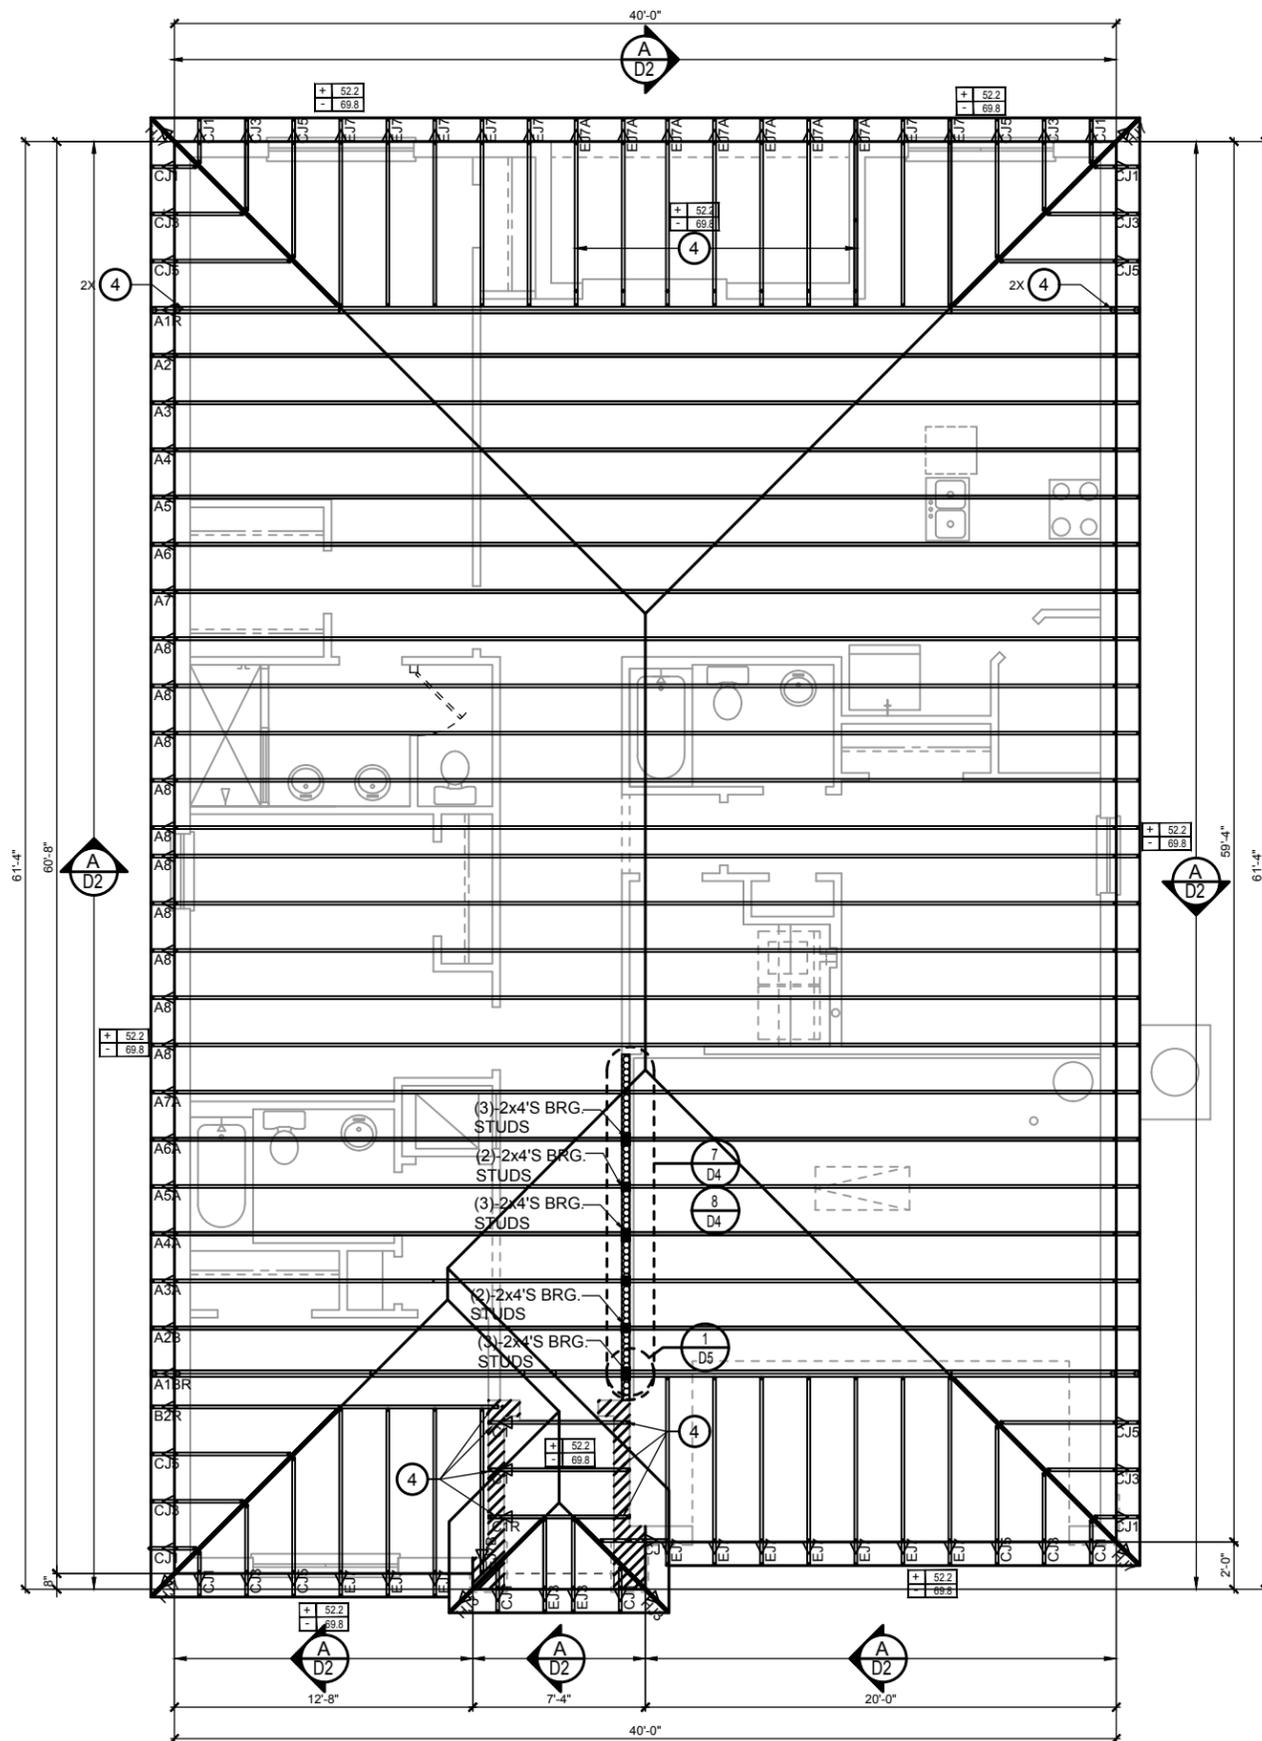

### COMPONENT & CLADDING DESIGN WIND PRESSURES

SEE PLAN DESIGN WIND PRESSURE

ULTIMATE DESIGNED POSITIVE PRESSURE  
 ULTIMATE DESIGNED NEGATIVE PRESSURE

NOTE: DESIGN PRESSURES BASED ULTIMATE WIND SPEED TO OBTAIN NOMINAL "AS" WIND PRESSURES MULTIPLY VALUES SHOWN BY A FACTOR OF 0.6

### FIELD REPAIR NOTES

- MISSED FOOTING DOWELS MAY BE SUBSTITUTED W/ A STRAIGHT #5 REBAR SET IN A 3/4" DIA. x 6" DEEP HOLE FILLED W/ UNITEX PROPOXY 300 OR SIMPSON SET OR ETF ADHESIVES.
- BLOCK WALL OVERHANGING SLAB CONDITION: UP TO 7/8" - NO REPAIR NECESSARY 7/8" TO 1 1/2" - ADD FILLED CELL (NO VERTICAL STEEL) MIDPOINT OF WALL BETWEEN EXISTING FILLED CELLS (WITH STEEL) IN AREAS AFFECTED. 1 1/2" - REQUIRE SPECIAL ENGINEERING LETTER.
- PENETRATION OF PLUMBING PIPES/DRYER VENTS THRU PLATES OF A LOAD BEARING WALL MAY OCCUR PROVIDED DBL. STUDS ARE ADDED ON EITHER SIDE OF PENETRATION WITHIN 3" AND TRUSS/FLOOR TRUSS IS NO CLOSER THAN 3" FROM PENETRATION. ADD (1) MTS12 @ TOP AND BOTTOM PLATE.

### NOTES

- TYPICAL ROOF GABLE OVERHANG TO BE 12" UNLESS OTHERWISE NOTED.
- TYPICAL ROOF EAVES OVERHANG TO BE 16" UNLESS OTHERWISE NOTED.
- PROVIDE AND INSTALL FLASHING AND ROOFING AS PER NATIONAL ROOFING AND SHEET METAL ASSOC. STANDARDS AND/OR ACCEPTABLE INDUSTRY PRACTICE AND IN ACCORDANCE WITH 8TH EDITION (2023) FLORIDA RESIDENTIAL CODE.
- ALL ROOF TRUSSES, GIRDERS, BEAMS, HEADERS, ETC. TO BE SIZE BY TRUSS MANUFACTURER OR FL. REG. ENG.
- TRUSSES SHALL BE BRACED TO PREVENT ROTATION & PROVIDE LATERAL STABILITY IN ACCORDANCE WITH THE REQUIREMENTS SPECIFIED IN THE CONSTRUCTION DOCUMENTS FOR BUILDING & ON THE INDIVIDUAL TRUSS DESIGN DRAWINGS IN THE ABSENCE OF SPECIFIC BRACING REQUIREMENTS, TRUSSES SHALL BE BRACED IN ACCORDANCE WITH TP1/WTCA BCS1.1.
- REFER TO TRUSS MANUFACTURERS DRAWINGS FOR TRUSS PLACEMENT & TRUSS TO TRUSS CONNECTIONS.
- ROOF UNDERLAYMENT TO BE USED IS 30 LBS. SYNTHETIC FELT.
- SHINGLE ROOF: UNDERLAYMENT TO BE INSTALLED IAW FBCR 2023, 8TH EDITION R905.1.1.1 UNDERLAYMENT MATERIALS REQUIRED TO COMPLY WITH ASTM D226, D1970, D4869 AND D6757 SHALL BEAR A LABEL INDICATING COMPLIANCE TO THE STANDARD DESIGNATION AND, IF APPLICABLE, TYPE CLASSIFICATION INDICATED IN TABLE R905.1.1.1 UNDERLAYMENT SHALL BE APPLIED AND ATTACHED IN ACCORDANCE WITH TABLE R905.1.1.1
- OFF RIDGE VENTS MAXIMUM OPENING SIZES: REFER TO MANUFACTURE SPECIFICATIONS.

## ROOF FRAMING PLAN

C (STANDARD)  
1/8"=1'-0" (11x17) 1/4"=1'-0" (22x37)

THIS STRUCTURE IS DESIGNED IN ACCORDANCE WITH THE 8th EDITION, 2023 OF THE FLORIDA BUILDING CODE-RESIDENTIAL AND IS CERTIFIED AS SUCH

HITEG  
THOMPSON ENGINEERING GROUP, INC.  
P.O. BOX 1734  
Orlando, Florida 32811  
Tel: (407) 734-1452  
Fax: (407) 734-1736  
www.hiteg.com

REPRODUCTIONS, CHANGES OR ASSIGNMENTS ARE PROHIBITED.

A DIVISION OF PARK SQUARE ENTERPRISES, INC.  
5200 Vineyard Road, Suite 200  
Orlando, Florida 32811  
Phone: (407) 529 - 3000

## Park Square HOMES

REVISIONS

LOT: 0000, COMMUNITY

## ROOF FRAMING PLAN

DATE: 09-11-25

1860 SKY

## 40' EXPLORATION SERIES

SCALE: AS NOTED

DRAWN: MR

# S3

SHEET:

DISCLAIMER: CONTRACTOR/SUB-CONTRACTOR IS RESPONSIBLE TO REVIEW ALL INFORMATION CONTAINED HEREIN PRIOR TO COMMENCEMENT OF CONSTRUCTION. PARK SQUARE HOMES IS NOT RESPONSIBLE FOR ANY MISINTERPRETATIONS, ERRORS, OMISSIONS OR CUSTOM CHANGES MISSED AND NOT REPORTED PRIOR TO CONSTRUCTION. NO EXCEPTIONS.

## STRUCTURAL NOTES

- THIS STRUCTURE HAS BEEN DESIGNED IN ACCORDANCE WITH THE 8TH EDITION, FBCR 2023 (WIND LOAD @ 133 MPH.)  
LIVE LOAD ROOF: 20 PSF.  
FLOOR: 40 PSF, BALCONIES & STAIRS: 40 PSF  
OCCUPANCY= 1.0  
BUILDING CATEGORY R3, WIND EXPOSURE C  
INTERNAL PRESSURE COEFFICIENTS = +0.18 AND -0.18
- WINDOWS, DOORS, AND GARAGE DOORS TO BE DESIGNED TO MEET FBCR SECTION R301
- ALL FLOOR SLABS TO BE OF 2,500 PSI CONC. PLANT MIX MIN. 4" THICK WITH 6x6 10/10 WIRE MESH 6 MIL. POLY. VAPOR-BARRIER OVER TERMITE TREATED COMPACTED CLEAN FILL.
- CONCRETE MASONRY UNITS SHALL MEET: CH. 1-3 OF ACI 530-02/ ASCE 5-02/TMS 402-02 OR BIA BUILDING CODE REQUIREMENTS.
- MORTAR TO BE TYPE "M" OR "S", GROUT - 2,500 PSI @ 28 DAYS.
- MASONRY CLEAN OUTS REQUIRED @ GROUT GREATER THAN FIVE (5) FEET IN HEIGHT AND ALL VERTICALS.
- REBAR TO BE # 5'S GRADE 60, W/ MIN. LAP OF 25". USE "L" BARS @ CORNERS AND USE STANDARD HOOKS @ CHANGE IN DIRECTION WITH MIN. LAP 12"
- GYP. BD. CEILING SHALL BE INSTALLED PERP. TO FRAMING & NAILED @ 7" O.C. WITH 5d NAILS. GYP. BD. WALLS SHALL BE NAILED @ 8" O.C. WITH 5d NAILS
- UPLIFT CONNECTOR'S TO PROVIDE CONTINUITY FROM ROOF TRUSSES THRU PLATES TO SLAB AND FOUNDATION PER ENCLOSED DETAILS.
- EPOXY ANCHOR ALTERNATIVE:  
THREADED ANCHOR ROD MAY BE USED IN LIEU OF ANCHOR BOLTS FOR USE AS PLATE ANCHORS OR HURRICANE ANCHORS.  
THE FOLLOWING CRITERIA MUST BE MET:

ANCHOR SIZE	CONC. HOLE SIZE	MIN. HOLE DEPTH
1/2"	-3/4"	7"
-5/8"	-7/8"	7"
-3/4"	1"	8"
-7/8"	1-1/8"	9"

AFTER HOLE IS DRILLED, ALL CONCRETE DUST MUST BE REMOVED PRIOR TO EPOXY INSTALLATION. THREADED ROD TO BE MIN. A36 STEEL AND FREE OF DIRT OR GREASE. LOAD ON ROD CANNOT BE APPLIED UNTIL 12 HOURS AFTER INSTALLATION. 2 COMPONENT EPOXY RESIN MATERIAL TO BE MIXED PER MFG. DIRECTIONS.

- SOIL BEARING CAPACITY 2000 PSF MINIMUM

## WOOD STRUCTURAL NOTES




- ALL WOOD TO BE SPECIES, GROUP, AND GRADE AS NOTED BELOW. DAMAGED WOOD NOT TO BE USED.
- ALL STRUCTURAL LUMBER SHALL BE SPF (SPRUCE-PINE-FIR) #2 OR BETTER UNLESS OTHERWISE NOTED. (PRE ENG. TRUSSES EXCLUDED)
- END JOINT IN STRUCTURAL DOUBLE TOP PLATE TO BE OFFSET AT LEAST 4". STRUCTURAL DOUBLE PLATES TO BE NAILED @ 6" O.C..
- PLYWOOD OR OSB. WALL SHEATHING NAIL PATTERN TO BE 10d @ 6" O.C.. UNLESS OTHERWISE NOTED.
- NUMBER OF HEADER STUDS AND ADJACENT FULL LENGTH STUDS PER WALL AND HEADER STUD REQUIREMENT SCHEDULE.
- MAX. 1" HOLE DRILLED INTO EXTERIOR STRUCTURAL STUDS.
- DBL. STUDS @ EA. END OF SHEAR WALL.
- WHEN ANCHORING MULTIPLE WD. ITEMS TOGETHER, THE LENGTH OF HURRICANE STRAP MUST BE CENTERED.
- NAIL PATTERN  
-DOUBLE PLATE 12" O.C.. OUTSIDE SPLICE ZONE (SEE NOTE 4)  
-DOUBLE STUDS @ 12" O.C..  
-DOUBLE OR TRIPLE HEADER @ 6" O.C.. @ EDGE @ 12" O.C., INTERMEDIATE.  
-HEADER TO STUD @ 4" O.C.. EA. HEADER MEMBER.  
-STUD TO TOP OR BOTTOM PLATE : (2) 16d THRU PLT. OR (2) 16d EA. SIDE TOE NAILED TO PLT.
- ROOF SHEATHING FOR SHINGLE ROOF TO BE MIN. 15/32 OSB, NAILED (10d RING SHANK NAILS) TO ROOF TRUSSES SPACED @ 24" O.C. (MAX) WITHOUT BLOCKING.  
-ROOF SHEATHING FOR TILE ROOF TO BE MIN. 19/32" OSB, 1/2" CDX PLYWOOD OR 1/2" ADVANTECH. NAILED (10d RING SHANK NAILS) TO ROOF TO ROOF TRUSS SPACED @ 24" O.C. (MAX) WITHOUT BLOCKING.
- FLOOR SHEATHING TO BE MIN. 23/32" PLYWOOD NAILED @ 6" O.C. W/ #8 RING SHANK NAILS AND LIQUID NAIL ADHESIVE.
- ALL FLOOR TRUSSES TO BE END BLOCKED @ BEARING LOCATIONS
- TRUSS BRACING PER TRUSS MANUFACTURE'S DRAWINGS.
- ALL NAILING SPECIFIED TO BE APPLIED BY NAIL GUN OR MANUALLY
- ALL WOOD IN DIRECT CONTACT WITH MASONRY SHALL BE PRESSURE TREATED.
- 2000 PSF MINIMUM SOIL BEARING CAPACITY
- NON BEARING WALL: 2X4 SPACED AT 24" O.C. UP TO 12'-0" HEIGHT WITH 2 ROWS OF HORIZONTAL 2X4 BLOCKING SPACE AT 4'-0" O.C.

## GENERAL CONTRACTOR:


IT IS RESPONSIBILITY OF THE GENERAL CONTRACTOR TO INSTALL ALL MATERIALS MEETING FLORIDA APPROVAL COMPLIANCE TO AVOID WATER INTRUSION AND MOISTURE INTRUSION ON WINDOWS, DOORS, ROOF, AND ANY OTHER AREA AROUND EACH UNIT/ HOUSE/ APARTMENT/ CONDOMINIUM/ TOWNHOUSE.

## FIELD REPAIR NOTES

- MISSED LINTEL STRAPS FOR MASONRY CONSTRUCTION MAY BE SUBSTITUTED W/ (1) USP MTW16 OR HC10 OR SIMPSON MTSM16 W/ (4) -1/4" X 2-1/4" TAPCONS TO BOND BEAM AND (7) 10d NAILS TO TRUSS FOR UPLIFTS LESS THAN 860 LBS (USE (2) MTSM16 FOR UPLIFTS LESS THAN 1720#). NO MORE THAN 10 STRAPS MAY BE SUBSTITUTED OR NO MORE THAN 3 IN A ROW. IF GIRGER TRUSS CONNECTIONS ARE MISSED CONTACT ENGINEER FOR SUBSTITUTION.
- MISSED J-BOLTS FOR FRAMED EXTERIOR/ BEARING WALLS MAY BE SUBSTITUTED W/ 1/2" DIA. x 7" LONG WEDGE ANCHORS (REDHEADS).
- MISSED FOOTING DOWELS MAY BE SUBSTITUTED W/ A STRAIGHT #5 REBAR SET IN A 3/4" DIA. x 6" DEEP HOLE FILLED W/ UNITEX PROPOXY 300 OR SIMPSON SET OR ETF ADHESIVES.
- BLOCK WALL OVERHANGING SLAB CONDITION:  
UP TO -7/8" - NO REPAIR NECESSARY  
-7/8" TO 1-1/4" - ADD FILLED CELL (NO VERTICAL STEEL) MIDPOINT OF WALL BETWEEN EXISTING FILLED CELLS (WITH STEEL) IN AREAS AFFECTED.  
1-1/4"+ - REQUIRE SPECIAL ENGINEERING LETTER.
- PENETRATION OF PLUMBING PIPES/DRYER VENTS THRU PLATES OF A LOAD BEARING WALL MAY OCCUR PROVIDED DBL. STUDS ARE ADDED ON EITHER SIDE OF PENETRATION WITHIN 3" AND TRUSS/ FLOOR TRUSS IS NO CLOSER THAN 3" FROM PENETRATION. ADD (1) MTS12 @ TOP AND BOTTOM PLATE.

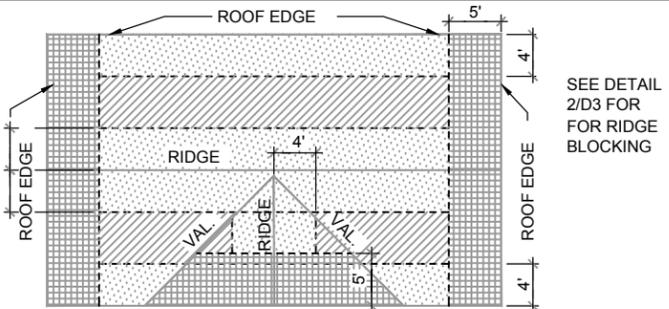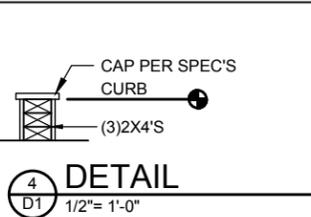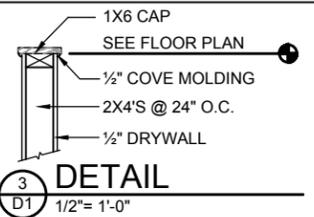


ROOF NAILING PATTERN	
ZONE: [Hatched]	10d RING SHANK NAILS @ 6" O.C. EDGES AND 6" O.C. FIELD
ZONE: [Dotted]	10d RING SHANK NAILS @ 6" O.C. EDGES AND 6" O.C. FIELD
ZONE: [Solid]	10d RING SHANK NAILS @ 4" O.C. EDGES AND 6" O.C. FIELD

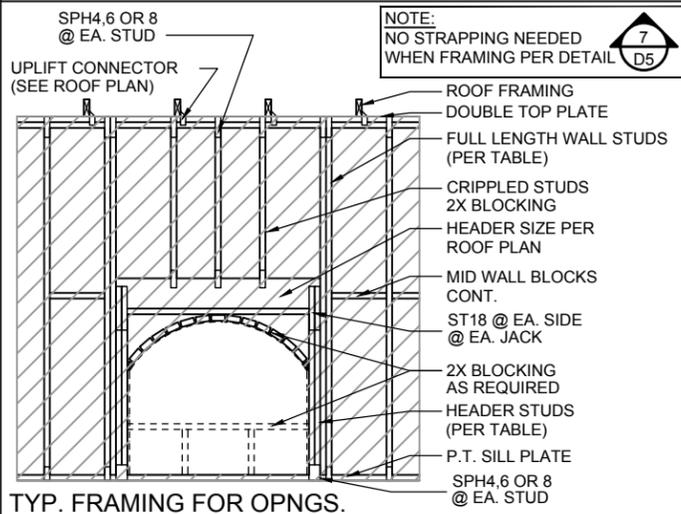

TYP. FRAMING FOR OPNGS.

 1/2"X6" (4 1/2" EMB.) HILTI KWIK BOLT WITH 2" WASHERS LOCATED @ 1'.4.&7" (WITHIN 6" OF SUPPORT BRACKET FOR GARAGE DOOR) FROM THE BOTTOM & MIN. EDGE DISTANCE.




- DETAIL TO SATISFY 150 MPH WIND LOAD
- MASONRY FRAME SHALL BE MIN 8X16 ASTM C-9D
- GROUT FILLED CELL W/1/2" ASTM 2 #5 REBAR (GRADE 60) @ EA. SIDE OF GARAGE DOOR OPENING
- MAX. DISTANCE TO CORNER OF C.B.S. WALL REINF. 48"
- REINF. TO BE CONT. FROM FTG. TO TIE BEAM W/ ALL "ACI" DETAILS & DEVELOPMENT LENGTHS ADHERED TO
- GARAGE DOOR MANUF. TO PROVIDE ATTACHMENT TO "BUCK"


- THE GARAGE DOOR ASSEMBLY SHALL BE DESIGNED FOR POSITIVE AND NEGATIVE WIND PRESSURES OF 25 PSF IN ACCORDANCE WITH SECTION R301 OF THE FLORIDA RESIDENTIAL CODE CERTIFICATION SHALL BE SUBMITTED FROM THE GARAGE DOOR MANUFACTURER TO THE BUILDING DEPARTMENT FOR THE FOLLOWING ITEMS:

- THE DESIGN OF THE DOOR CAN WITHSTAND POSITIVE AND NEGATIVE WIND PRESSURES OF 25 PSF.
- THE DESIGN OF THE DOOR COMPLIES WITH THE CRITERIA SPECIFIED IN SECTION R609 OF THE 2023 FLORIDA BUILDING CODE RESIDENTIAL, 8TH EDITION
- DOOR SIZE, TYPE AND GLAZING
- TRACK SIZE AND FASTENER DETAILS.
- TRACK BRACKET QUANTITY, SPACING AND FASTENER DETAILS.
- REINFORCING MEMBER QUANTITY, LOCATION, SIZE, TYPE AND FASTENER DETAILS. (IF REQUIRED)

## GARAGE BUCK DETAIL

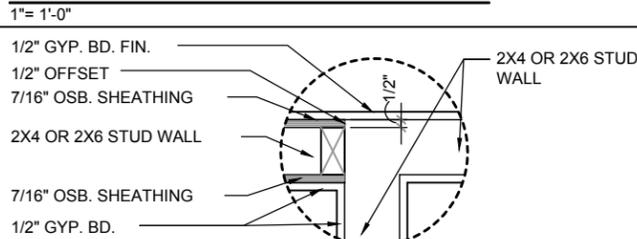

## DETAIL @ CONN. TO REG. WALL


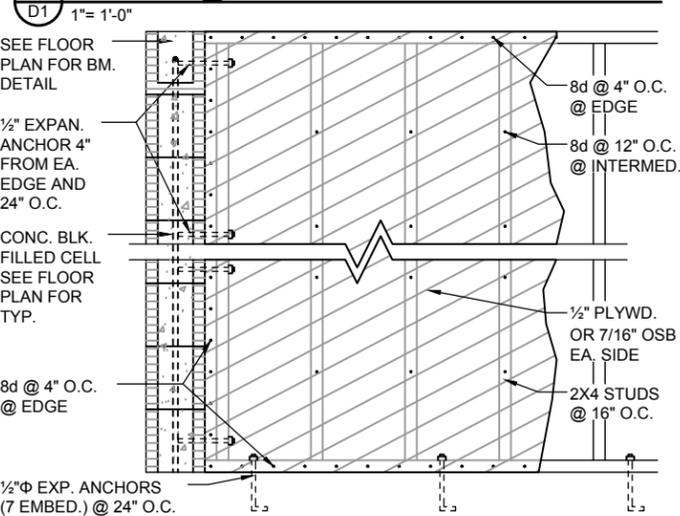


## SHEAR WALL DETAIL

USE ONLY WHEN NOTED AS SHEAR WALL ON PLANS


## MIN. WALL AND HEADER REQUIREMENTS

UNSUPPORTED WALL HEIGHT	STUD SPACING	MAXIMUM HEADER SPAN (ft.)					
		3'	6'	9'	12'	15'	18'
10' OR LESS	1	NUMBER OF FULL-LENGTH STUDS @ EACH END OF HEADER					
		2	2	3	3	3	3
GREATER THAN 10'	2	NUMBER OF FULL-LENGTH STUDS @ EACH END OF HEADER					
		2	2	3	4	5	5

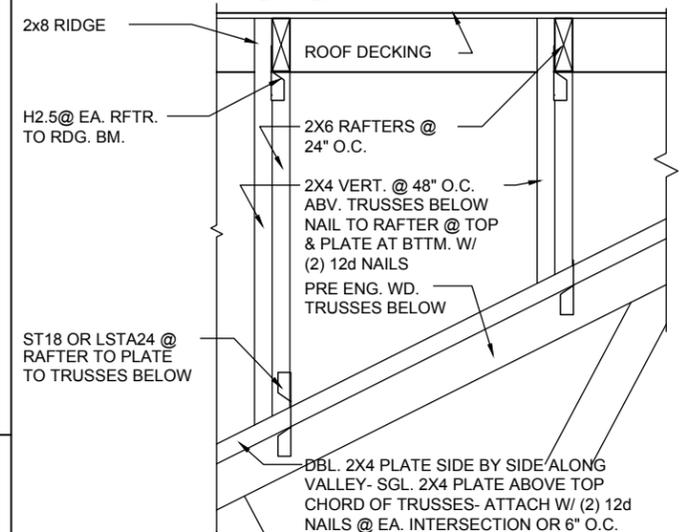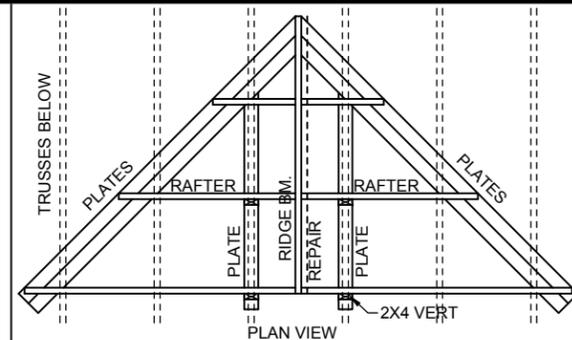

## VALLEY DETAIL

1/2" = 1'-0"

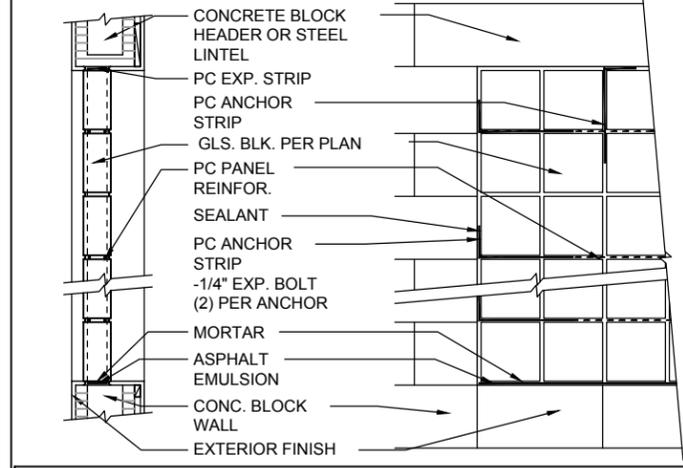

## PANEL ANCHOR CONSTRUCTION

PC PANEL REINFORING (TOP): USED IN PANELS OVER 25'S.F. IN AREA, IS EMBEDDED HORIZONTALLY IN THE MORTAR JOINTS BETWEEN EVERY OTHER COURSE. PANEL REINFORING IS FORMED OF TWO PARALLEL WIRES, EITHER 1-5/8" O.C. (FOR USE WITH "THINLINE" SERIES GLS. BLK.) OR 2" O.C. (FOR USE W/ "PREMIERE" SERIES GLS. BLK.), W/ BUTT WELDED CROSSWIRES AT REGULAR INTERVALS. 4' AND 10' LENGTHS AVAILABLE.

PC PANEL ANCHORS (MIDDLE): ARE USED TO TIE PITTSBURGH CORNING GLASS BLOCK PANELS INTO THE SURROUNDING FRAMEWORK WHEN CHANNELS ARE NOT USED. FORMED FROM 20 GAUGE PERFORATED- THEN GALVANIZED STEEL STRIPS, PANEL ANCHORS ARE AVAIL. IN 1-3/4" WIDTHS X 24" LENGTHS.

PC EXPANSION STRIPS (BOTTOM): MADE OF WHITE POLYETHYLENE, ARE INSERTED AT THE HEAD AND THE STRIPS REPLACE MORTAR AT THESE POINTS TO CUSHION THE GLASS BLOCK AND ALLOW THE PANEL TO EXPAND & CONTRACT FREELY. FOR METAL CHANNEL OR MASONRY CHASE CONSTRUCTION, PC EXPANSION STRIPS ARE AVAILABLE 3/8" THICK X 4" WIDE X 24" LONG. FOR PANEL ANCHOR CONSTRUCTION, STD. 4" WIDE STRIPS ARE EASILY CUT TO 3" WIDTH, FOR 3-7/8" "PREMIERE" SERIES BLK., AND TO 2-1/4" WIDTH, FOR 3-1/8" "THINLINE" SERIES BLOCK.

## GLASS BLOCK DETAIL

1/2" = 1'-0"

THIS STRUCTURE IS DESIGNED IN ACCORDANCE WITH THE 8TH EDITION, 2023 OF THE FLORIDA BUILDING CODE-RESIDENTIAL AND IS CERTIFIED AS SUCH.

LOT: 0000, COMMUNITY

**HITEG**  
TRIMPSON ENGINEERING GROUP, INC.  
P.O. BOX 1344  
Orlando, Florida 32811  
Tel: (407) 734-1489  
Fax: (407) 734-1790  
www.hiteg.com




A DIVISION OF PARK SQUARE ENTERPRISES, INC.  
5200 Vineyard Road, Suite 200  
Orlando, Florida 32811  
Phone: (407) 529-3000


**Park Square HOMES**

STRUCTURAL NOTE & DETAILS


1860 SKY  
40' EXPLORATION SERIES

REVISIONS	
DELTA #	DATE
DATE:	09-11-25
SCALE:	AS NOTED
DRAWN:	MR
SHEET:	D1

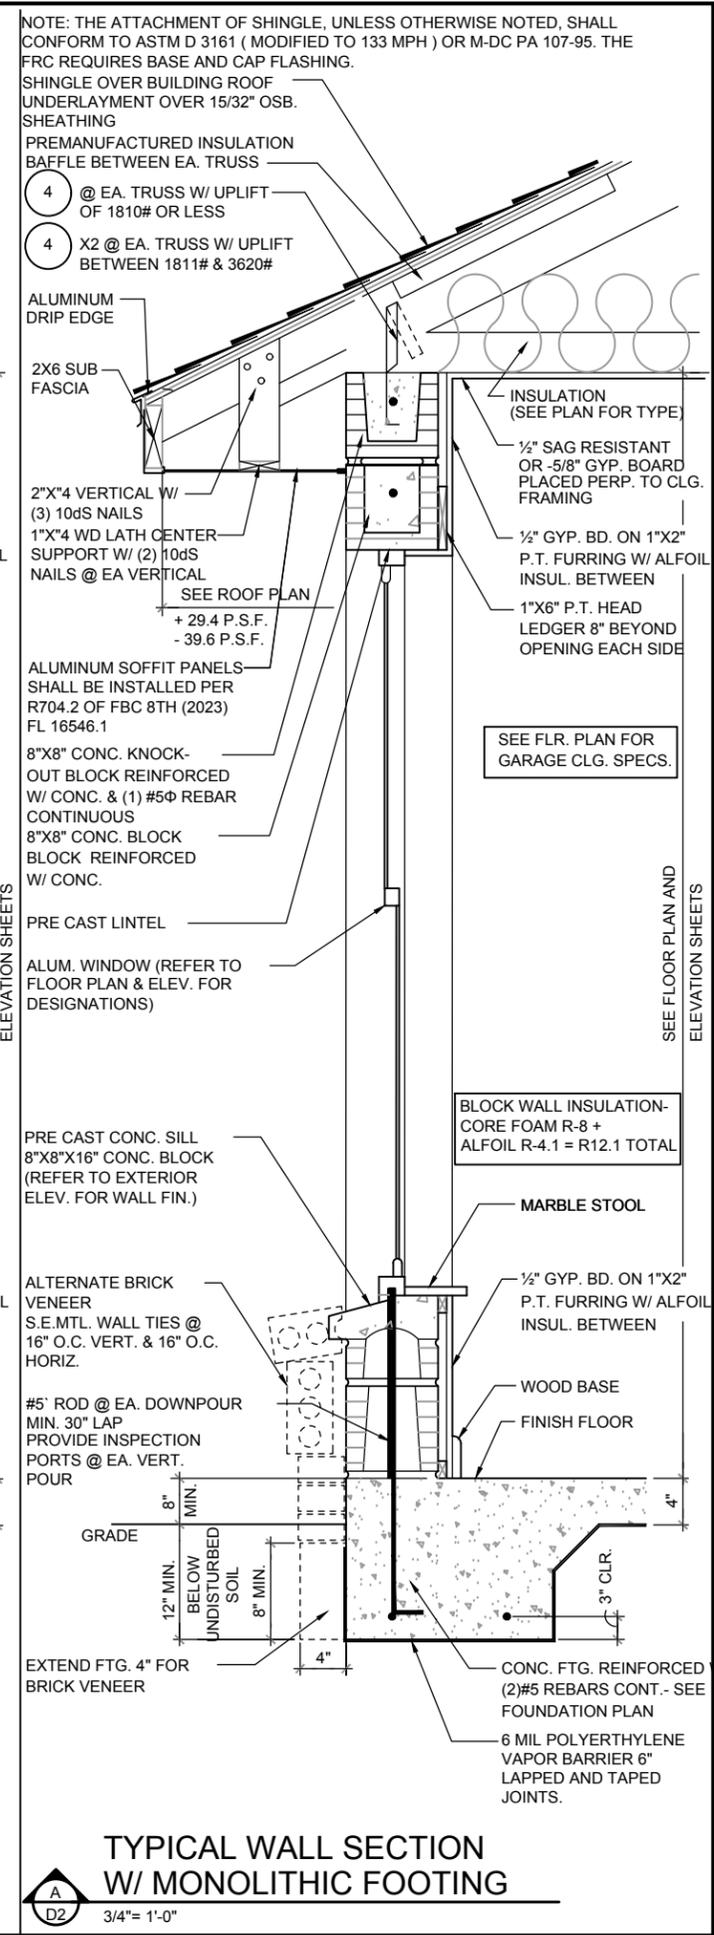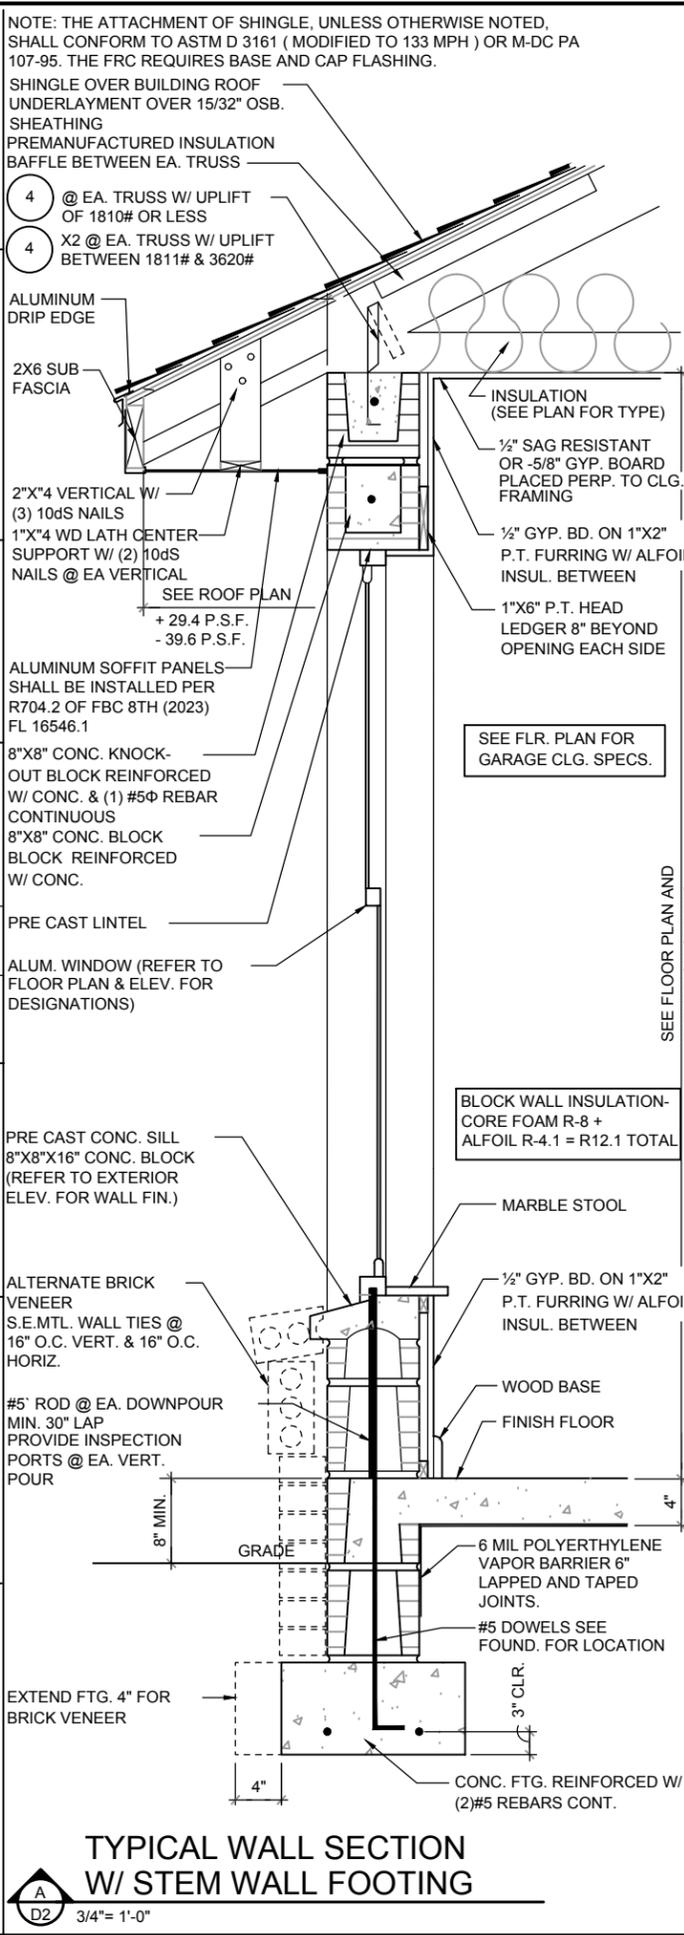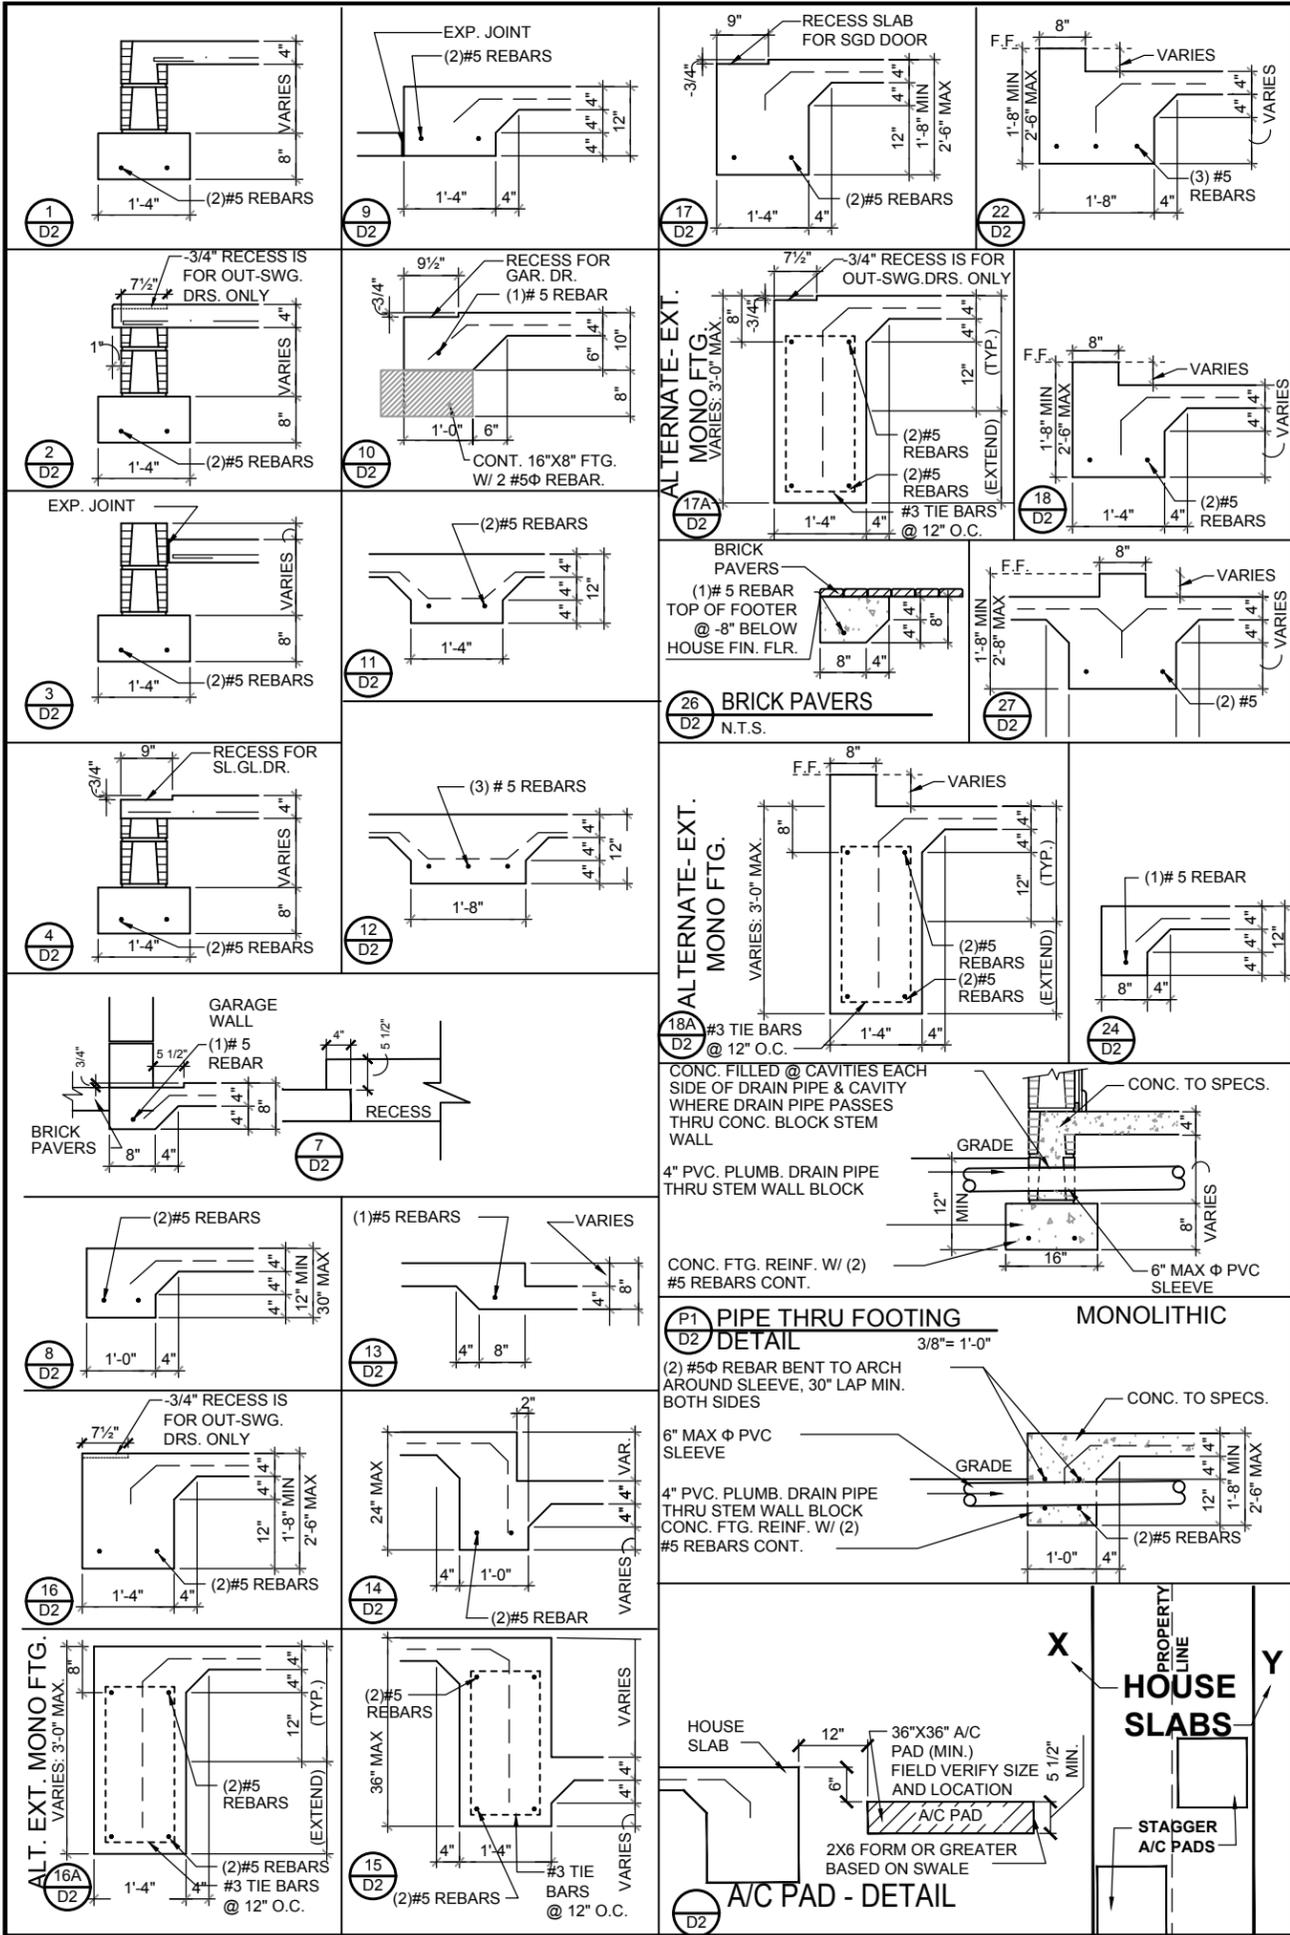


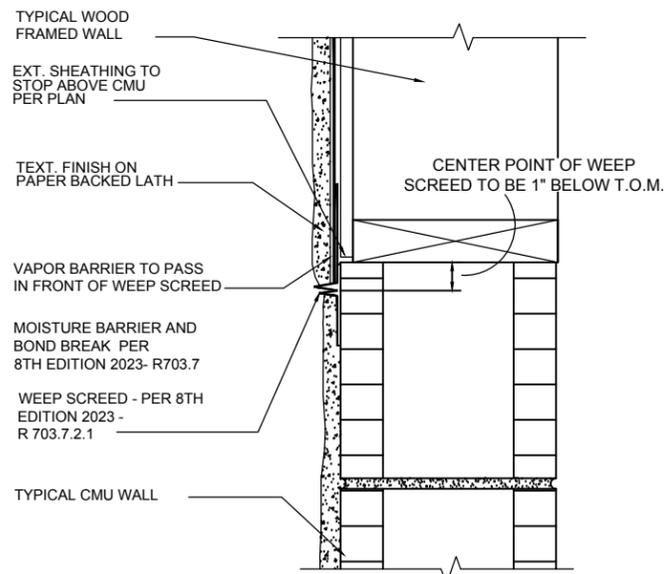

**FLASHING DETAIL**

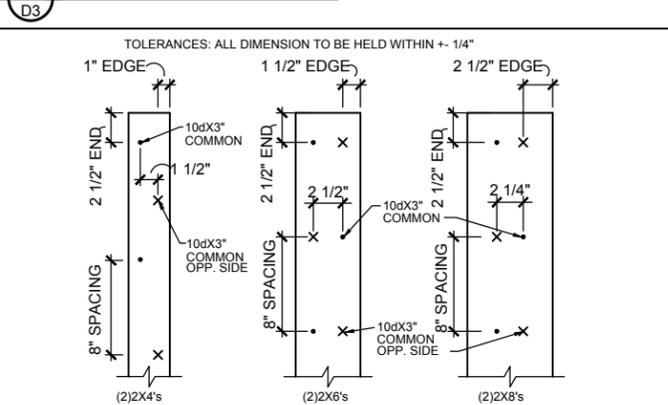

**2X BUILT-UP STUD COLUMN DETAILS**

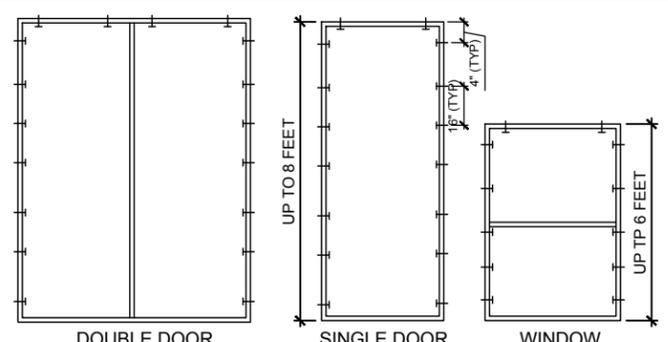

FOR MULTIPLE WINDOWS AND DOORS USE 2 TAPCONS PER WINDOW AT THE HEAD AND 4 TAPCONS AT THE JAMB.

**BUCK ATTACHMENT DATA**


BUCKS SHALL BE 1x4 OR 2x8 PT AT WINDOWS OR 2x8 PT AT DOORS IN PINE OR SPRUCE. AT WINDOWS ATTACH BUCKS TO BLOCK WITH COMMON T-NAILS AND PLACEMENT SIMILAR TO TAPCONS SHOWN. AT DOORS OR FIN WINDOWS IN BLOCK, ATTACH BUCKS w/ 2 T-NAILS TOP AND BOTTOM AND 8" O.C. STAGGERED IN THE FIELD.

USE MIN. 2-1/4" T-NAILS w/ 1x BUCK. USE MIN. -1/4" x 3" TAPCONS w/ 2x BUCK. START ALL END TAPCONS WITHIN 4" OF CORNERS AND 16" ON CENTER MAXIMUM.


FOR FRAME ANCHORING USE MIN. 2-1/4" T-NAILS w/ 1x BUCK. USE MIN. -1/4" x 3" TAPCONS w/ 2x BUCK. START ALL END TAPCONS WITHIN 6" OF CORNERS AND 14" ON CENTER MAXIMUM.

**NOTE**


IN CASE OF BLOCK OPENINGS LARGER THAN DOOR FRAMING: ATTACH ADDITIONAL 2X FRAMING TO THE BLOCK WALL USING 1/4" x 4" TAPCONS AT 3" FROM END AND 12" O.C. IN THE CENTER. ATTACH TOP FRAMING TO HEADER USING 1/4"x1-3/4" TAPCONS w/ (1) 6" FROM END TO END AND 12" O.C. IN THE CENTER.

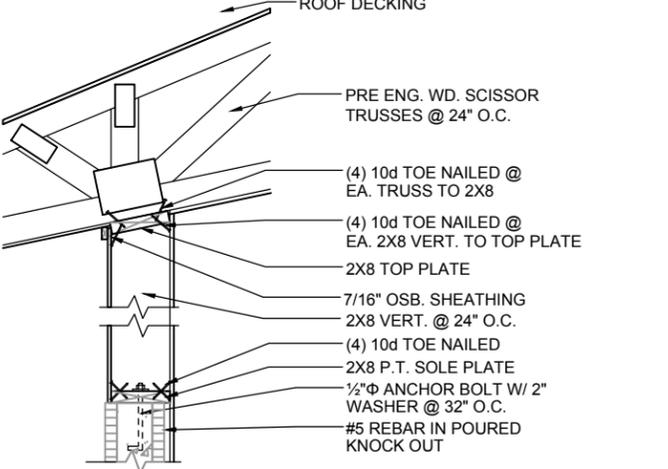

**NON-BEARING**

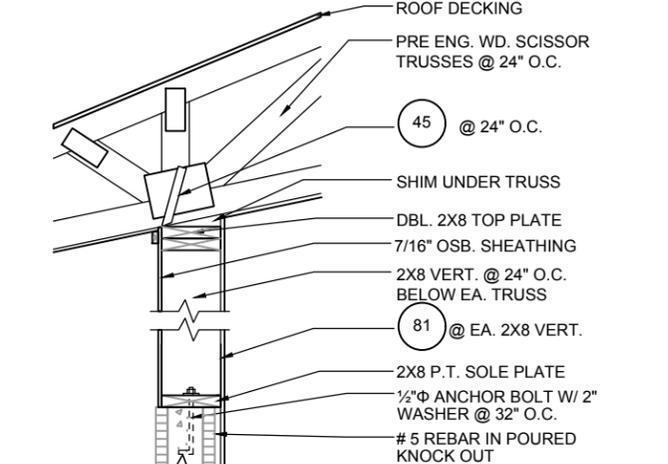


**BEARING**

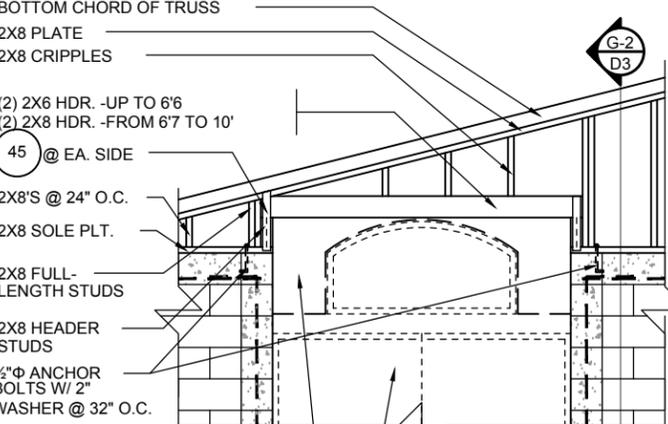


**BLOCKING & SHEATHING**


GLASS OPENING

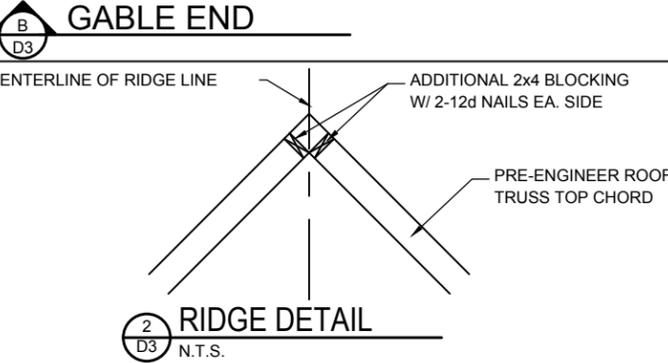


**RIDGE DETAIL**

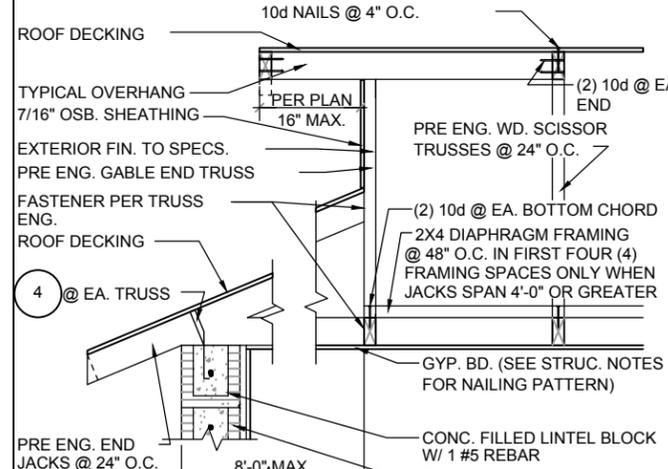


**GABLE END**

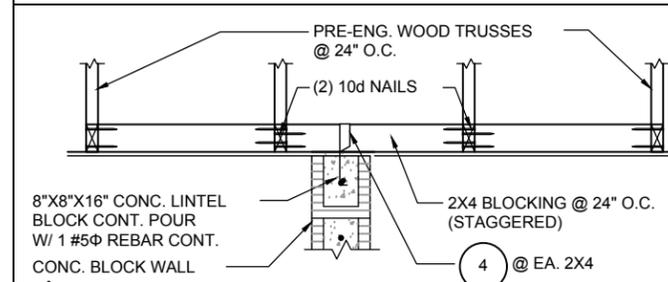


**DETAIL**

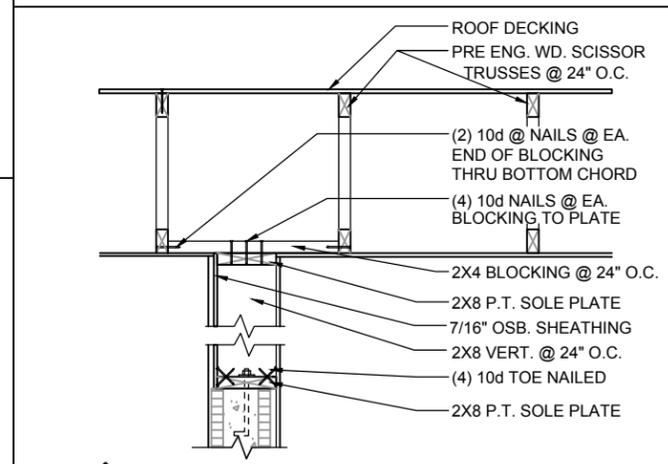


**GABLE END**

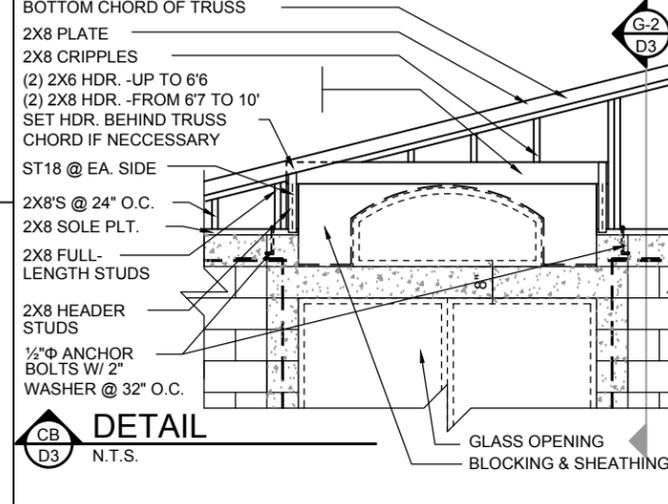


**DETAIL**

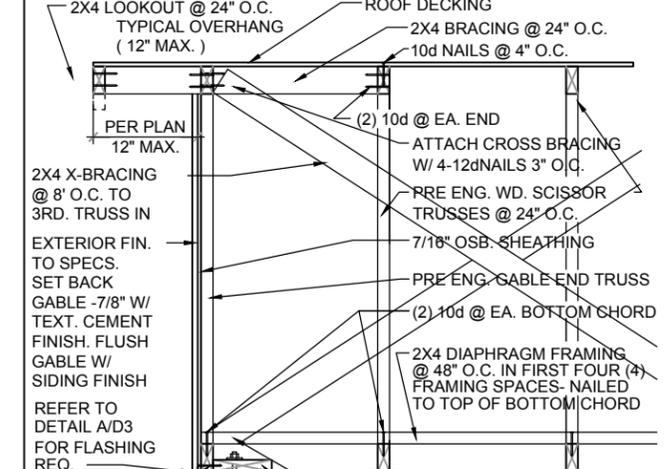


**GABLE END**

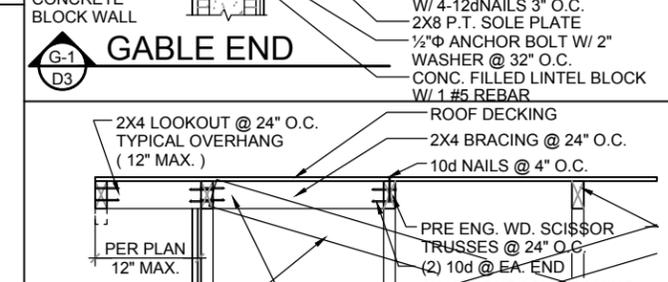

**GABLE END**

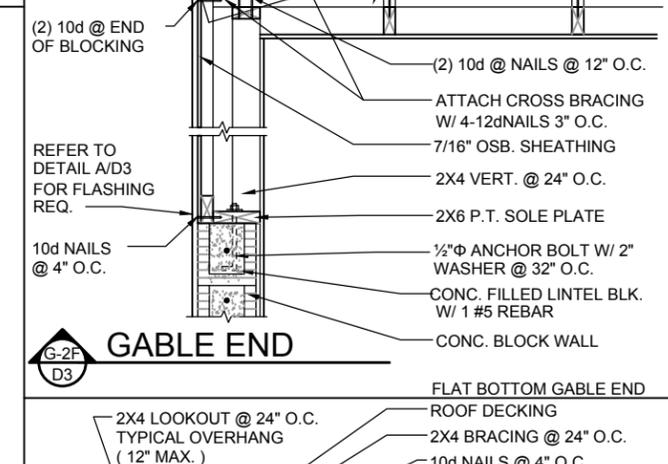

**GABLE END**

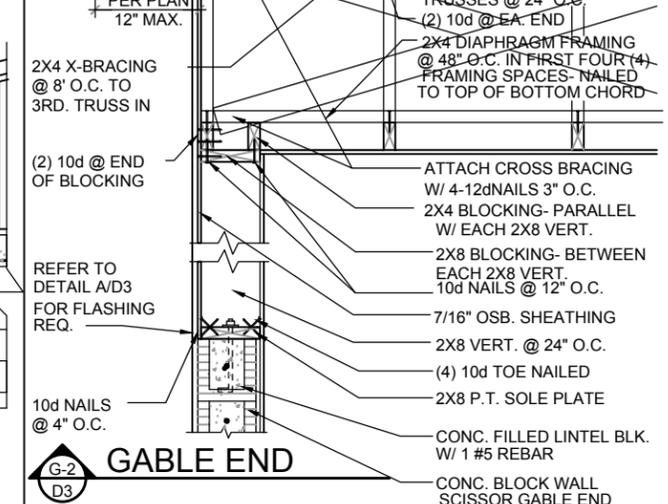

**GABLE END**

THIS STRUCTURE IS DESIGNED IN ACCORDANCE WITH THE 8th EDITION, 2023 OF THE FLORIDA BUILDING CODE-RESIDENTIAL AND IS CERTIFIED AS SUCH.

**LOT: 0000, COMMUNITY**

**1860 SKY**

**40' EXPLORATION SERIES**

**REVISIONS**

DELTA #	DATE
	09-11-25


DATE: 09-11-25  
SCALE: AS NOTED  
DRAWN: MR  
SHEET: D3

**HITEG**  
THOMPSON ENGINEERING GROUP, INC.  
PARK SQUARE HOMES ENTERPRISES, INC.  
5200 Vineand Road, Suite 200  
Orlando, Florida 32811  
Phone: (407) 529-3000  
www.hiteg.com


**Park Square HOMES**

**STRUCTURAL DETAILS**


**DISCLAIMER: CONTRACTOR/SUB-CONTRACTOR IS RESPONSIBLE TO REVIEW ALL INFORMATION CONTAINED HEREIN PRIOR TO COMMENCEMENT OF CONSTRUCTION. PARK SQUARE HOMES IS NOT RESPONSIBLE FOR ANY MISINTERPRETATIONS, ERRORS, OMISSIONS OR CUSTOM CHANGES MISSED AND NOT REPORTED PRIOR TO CONSTRUCTION. NO EXCEPTIONS.**

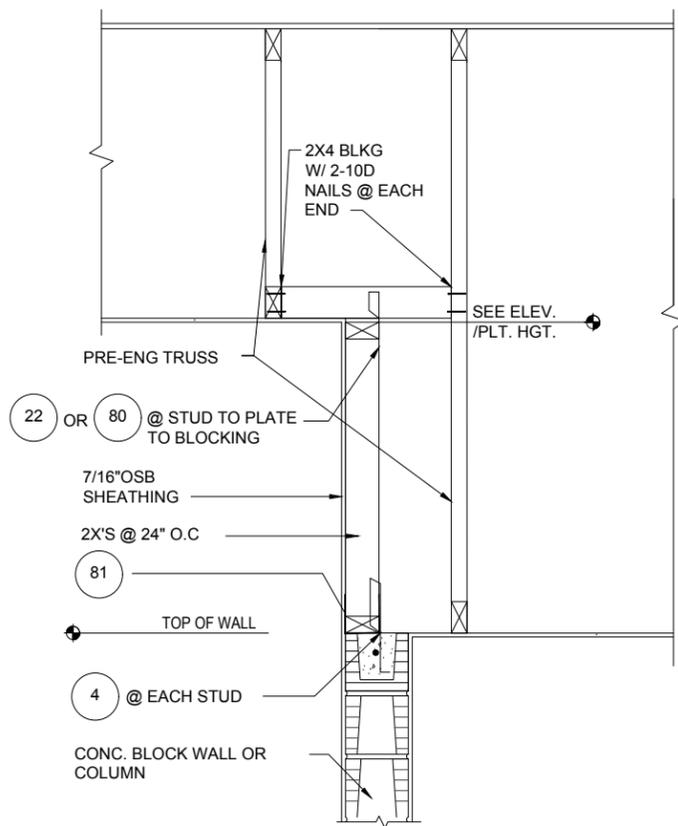


**1**  
D4  
**DETAIL**  
1/2"=1'-0" (11X17) 1"=1'-0" (22X34)

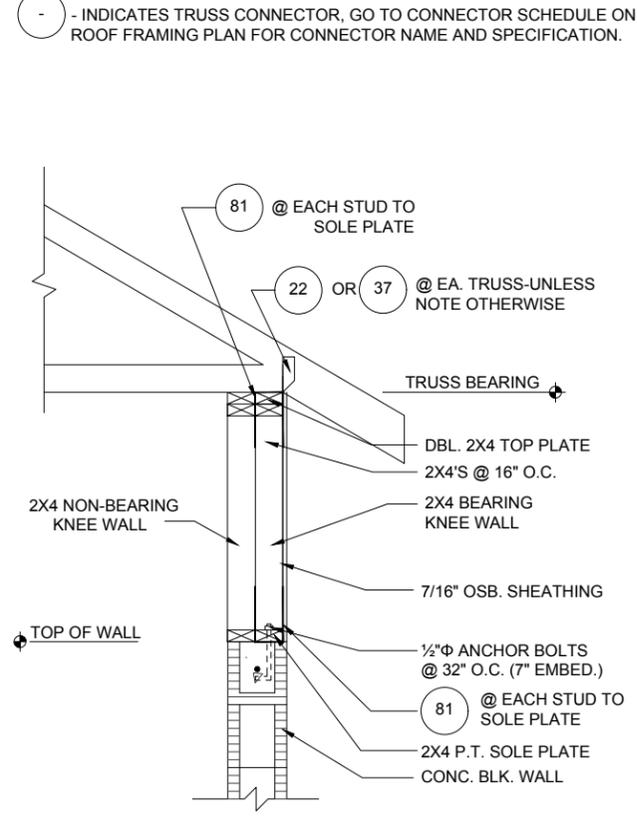


**2**  
D4  
**DETAIL**  
1/2"=1'-0" (11X17) 1"=1'-0" (22X34)

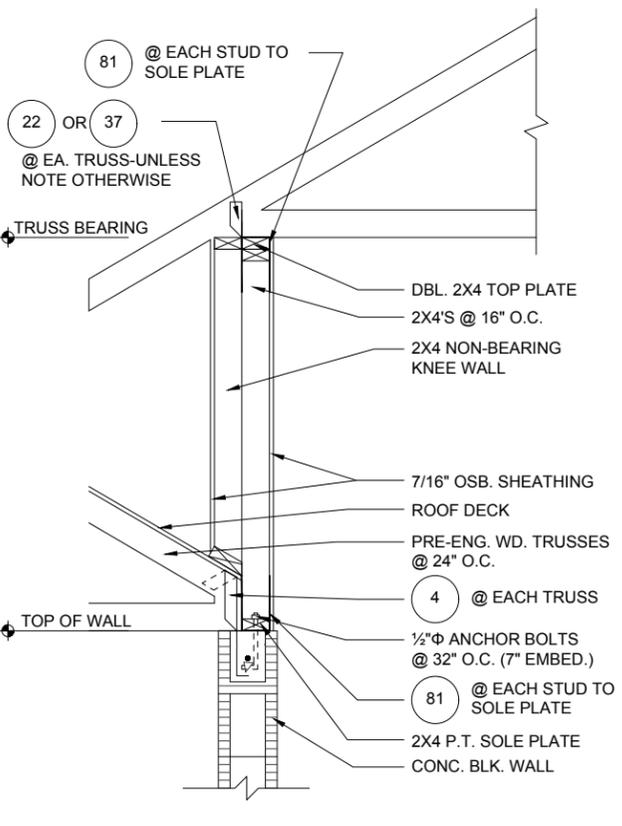


**3**  
D4  
**DETAIL**  
1/2"=1'-0" (11X17) 1"=1'-0" (22X34)

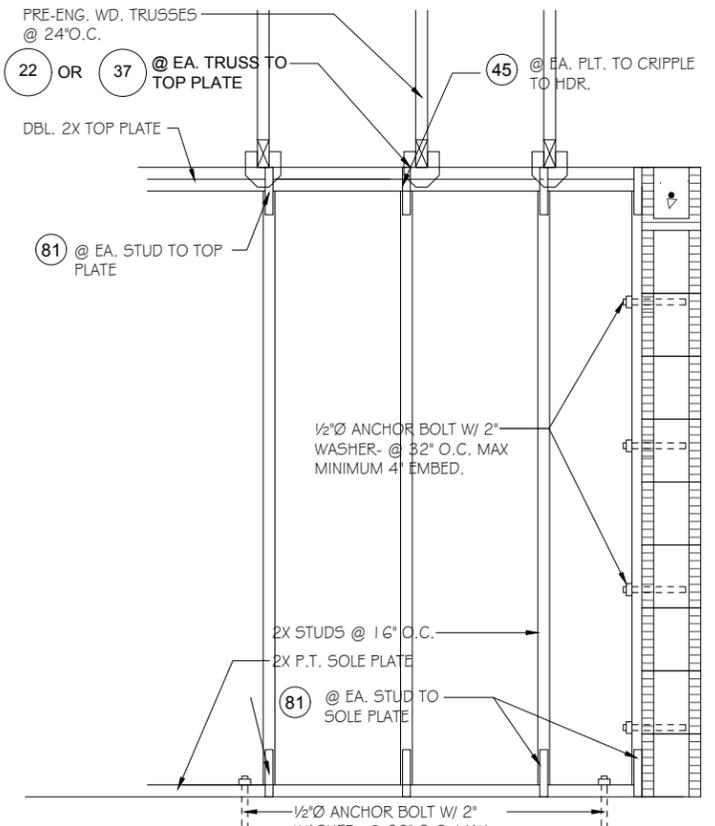


**7**  
D4  
**DETAIL**  
1/2"=1'-0" (11X17) 1"=1'-0" (22X34)

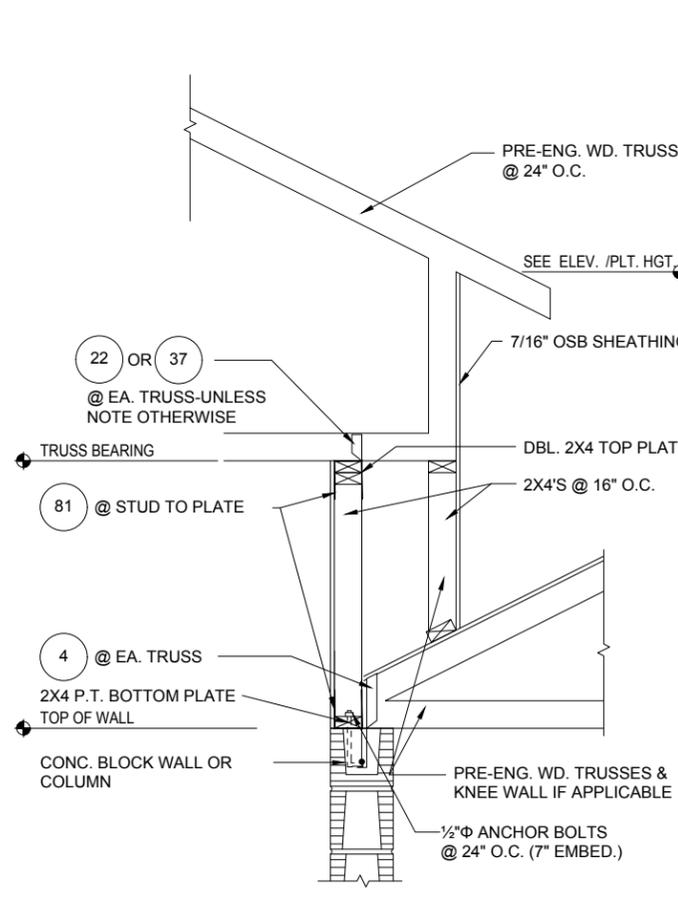


**4**  
D4  
**DETAIL**  
1/2"=1'-0" (11X17) 1"=1'-0" (22X34)

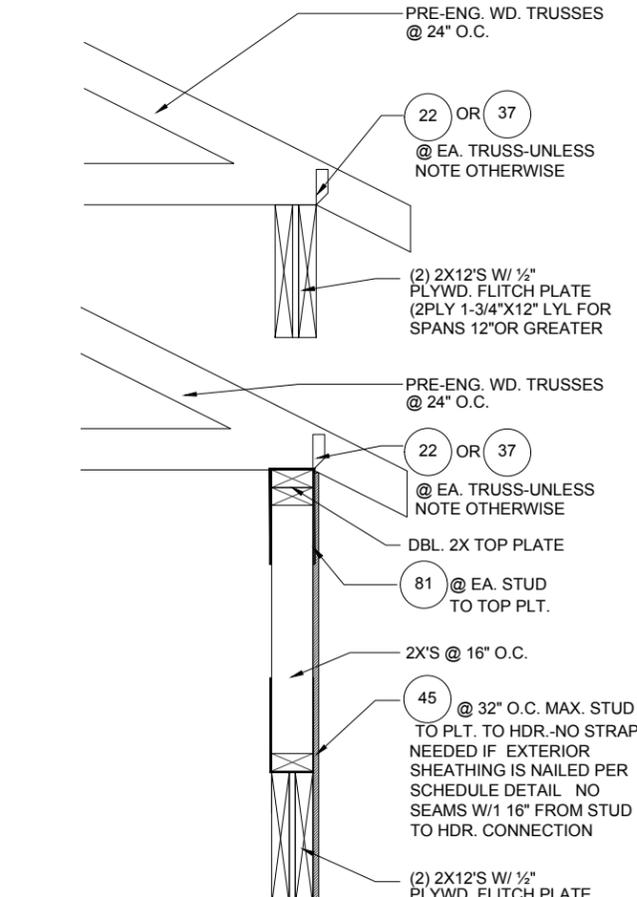

**5**  
D4  
**DETAIL**  
1/2"=1'-0" (11X17) 1"=1'-0" (22X34)

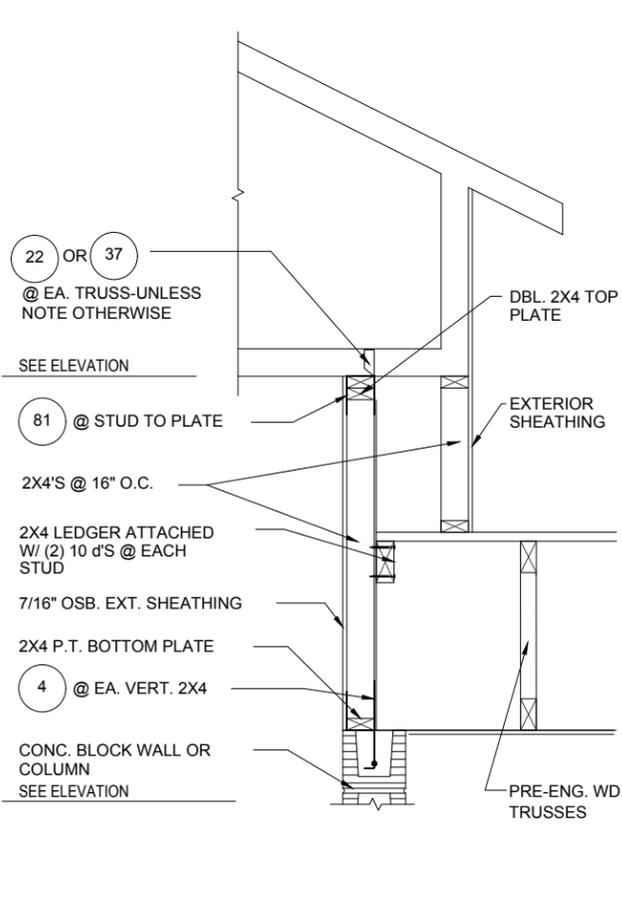

**6**  
D4  
**DETAIL**  
1/2"=1'-0" (11X17) 1"=1'-0" (22X34)

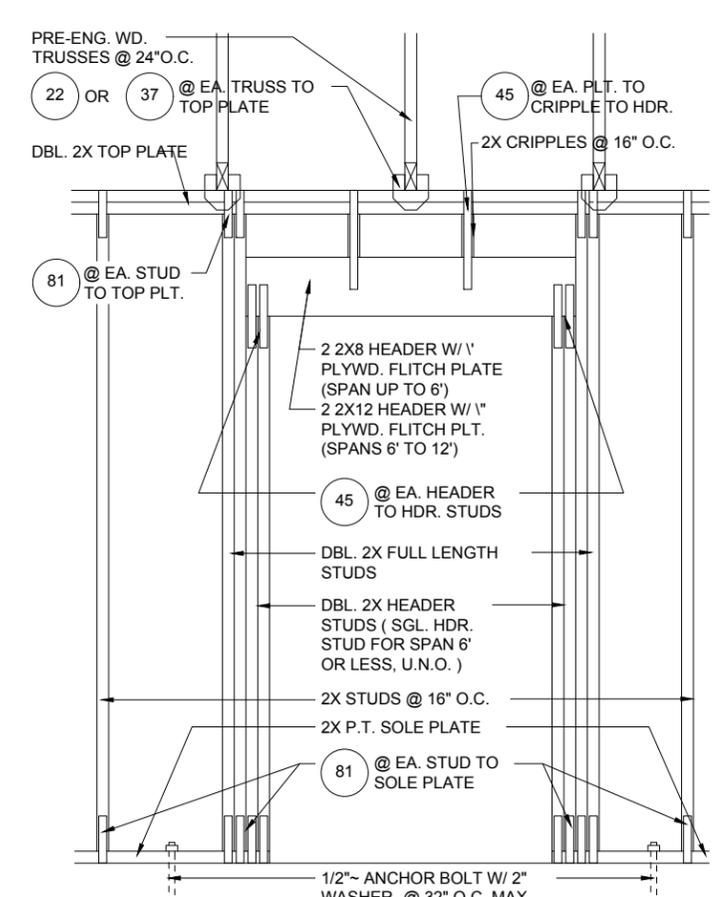

**8**  
D4  
**DETAIL**  
1/2"=1'-0" (11X17) 1"=1'-0" (22X34)


DISCLAIMER: CONTRACTOR/SUB-CONTRACTOR IS RESPONSIBLE TO REVIEW ALL INFORMATION CONTAINED HEREIN PRIOR TO COMMENCEMENT OF CONSTRUCTION. PARK SQUARE HOMES IS NOT RESPONSIBLE FOR ANY MISINTERPRETATIONS, ERRORS, OMISSIONS OR CUSTOM CHANGES MISSED AND NOT REPORTED PRIOR TO CONSTRUCTION. NO EXCEPTIONS.

THIS STRUCTURE IS DESIGNED IN ACCORDANCE WITH THE 8th EDITION, 2003 OF THE FLORIDA BUILDING CODE-RESIDENTIAL AND IS CERTIFIED AS SUCH  
**LOT: 0000, COMMUNITY**  
 PARK SQUARE HOMES RESERVES COPYRIGHT & OTHER RIGHTS RESTRICTING THESE DOCUMENTS TO THE ORIGINAL SITE OR PURPOSE FOR WHICH THEY WERE PREPARED. REPRODUCTIONS, CHANGES OR ASSIGNMENTS ARE PROHIBITED.


**1860 SKY**  
**40' EXPLORATION SERIES**  
**STRUCTURAL DETAILS**  
**Park Square HOMES**  
 A DIVISION OF PARK SQUARE ENTERPRISES, INC.  
 THOMPSON ENGINEERING GROUP, INC.  
 5200 Vineyard Road, Suite 200  
 Orlando, Florida 32811  
 Phone: (407) 529-3000  
 Fax: (407) 734-1790  
 www.psh.com

REVISIONS	
DELTA #	DATE


DATE: 09-11-25  
 SCALE: AS NOTED  
 DRAWN: MR  
 SHEET: **D4**

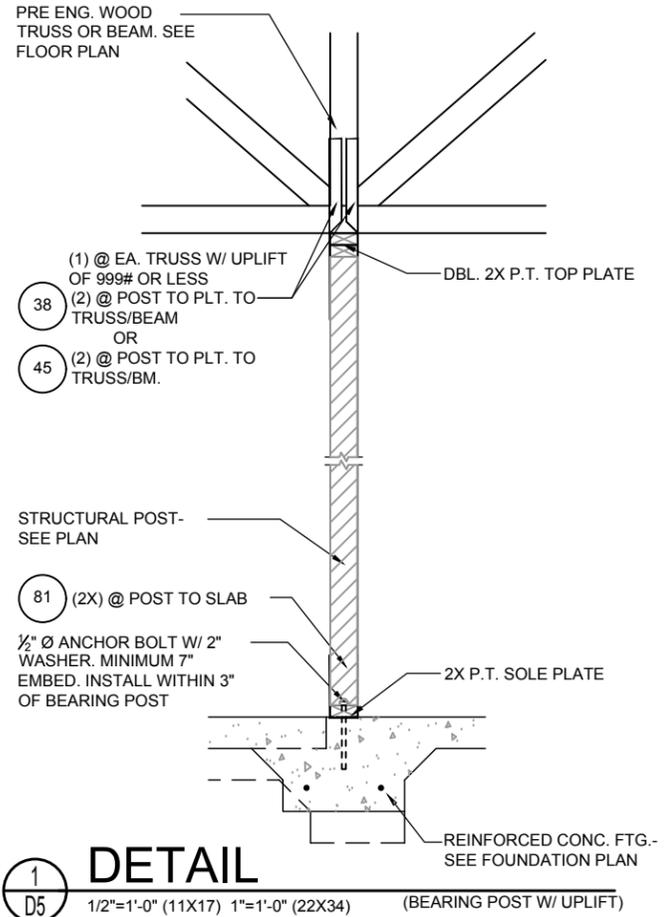


**1** **DETAIL**  
**D5** 1/2"=1'-0" (11X17) 1"=1'-0" (22X34) (BEARING POST W/ UPLIFT)

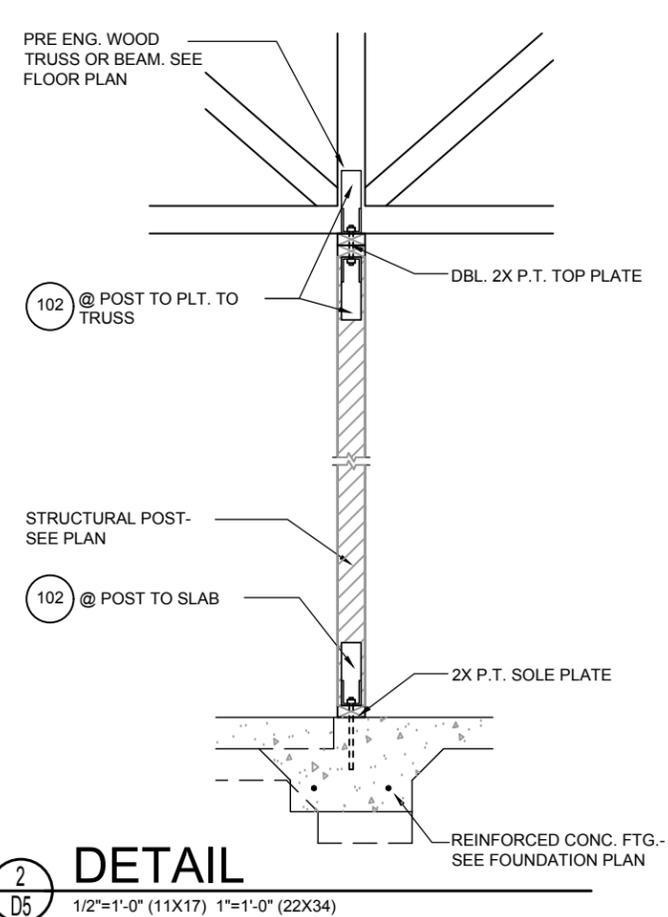

**2** **DETAIL**  
**D5** 1/2"=1'-0" (11X17) 1"=1'-0" (22X34)

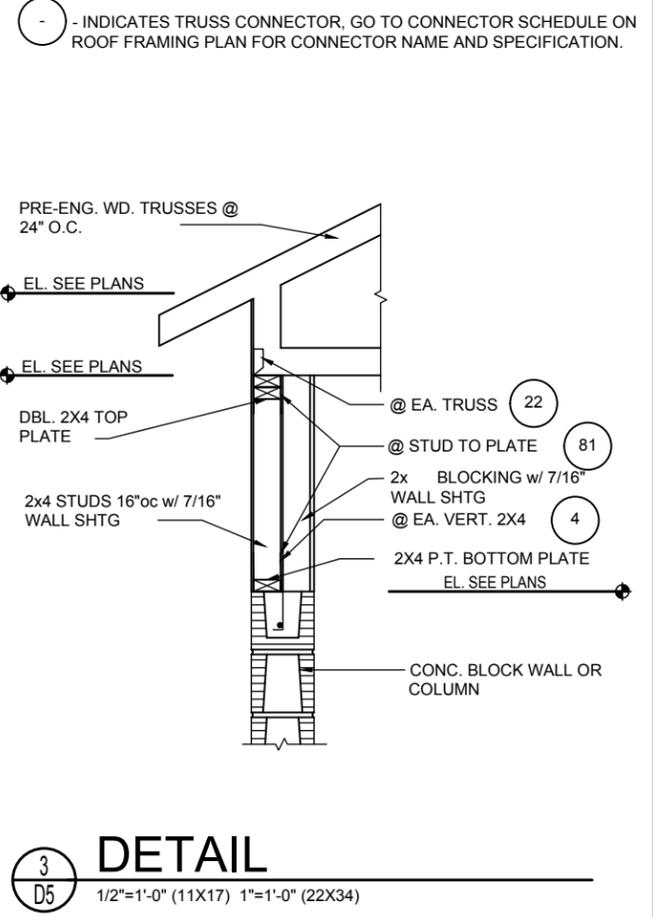


**3** **DETAIL**  
**D5** 1/2"=1'-0" (11X17) 1"=1'-0" (22X34)

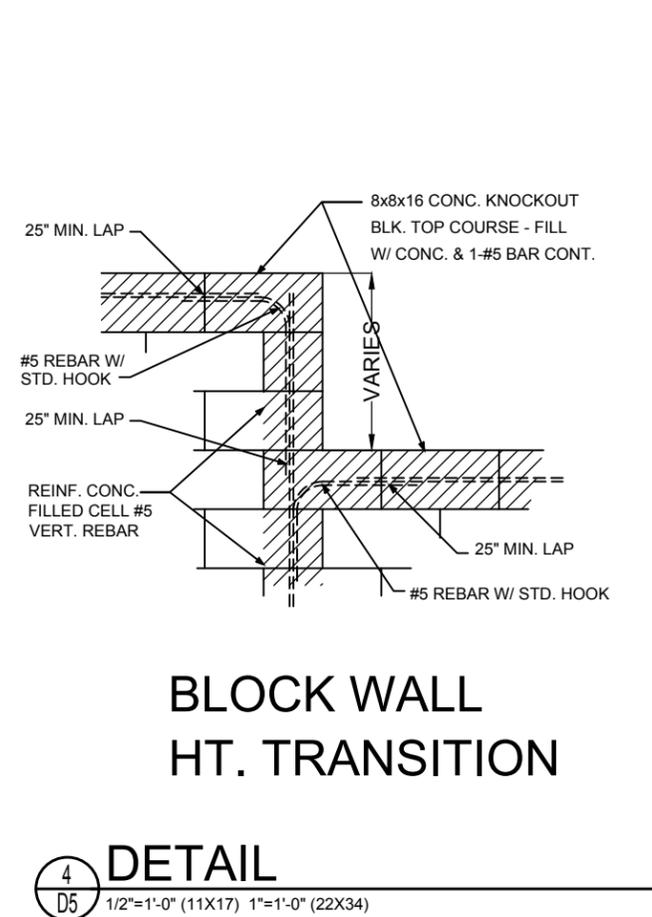


**4** **DETAIL**  
**D5** 1/2"=1'-0" (11X17) 1"=1'-0" (22X34)

**NOTE:**  
 1/2" PLYWOOD OR 7/16" O.S.B. TO BE USED AS UPLIFT RESISTANCE NO OTHER FASTENERS REQ'D. AT STUD/FLOOR TRUSS, EXCEPT AS NOTED ON PLANS IN TWO STORY FRAME APPLICATIONS, SHEATHING SHALL EXTEND MIN. 1'-0" W/O BREAK ABV. 2nd FLOOR BOTTOM PLT. TO T.O.M.


**NAILING SCHEDULE:**  
 (2) ROWS @ 3" O.C. AT TOP AND (1) ROW AT BOTTOM OF WALL, 6" O.C. ALL OTHER EDGES AND 12" IN FIELD. BLOCKING SHALL BE PLACED AT ALL SHEATHING JOINTS.

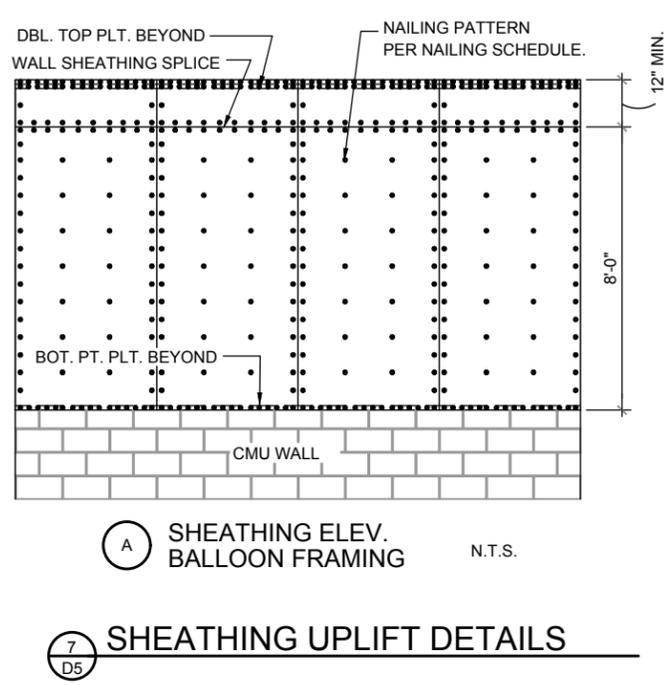


**7** **DETAIL**  
**D5** SHEATHING UPLIFT DETAILS

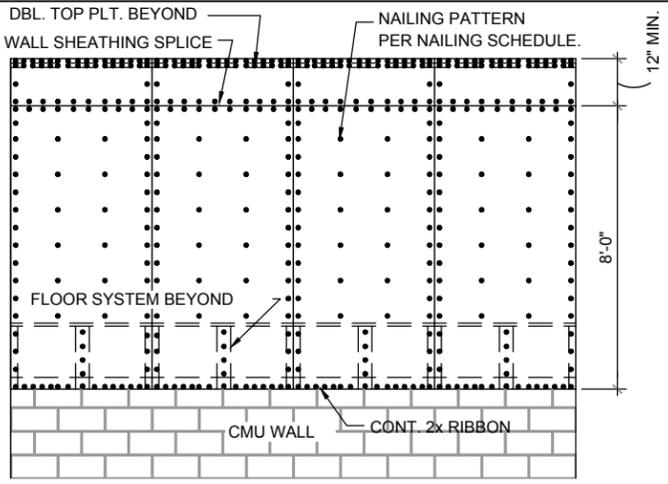


**B** SHEATHING ELEV. 2-STORY FRAMING N.T.S.

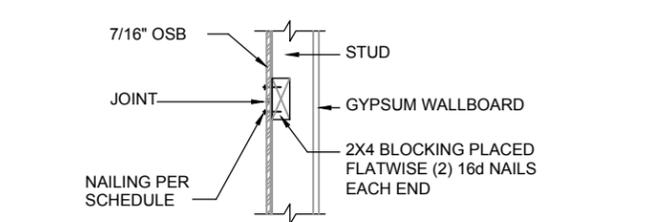

**C** SHEATHING BLOCKING @ HORIZONTAL JOINTS N.T.S.

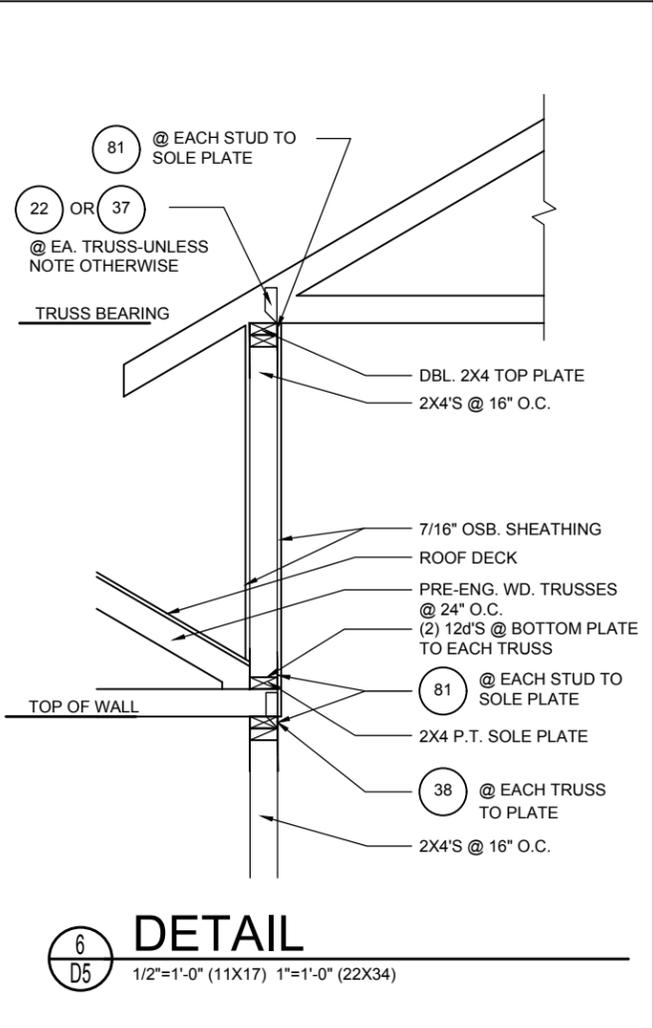

**6** **DETAIL**  
**D5** 1/2"=1'-0" (11X17) 1"=1'-0" (22X34)

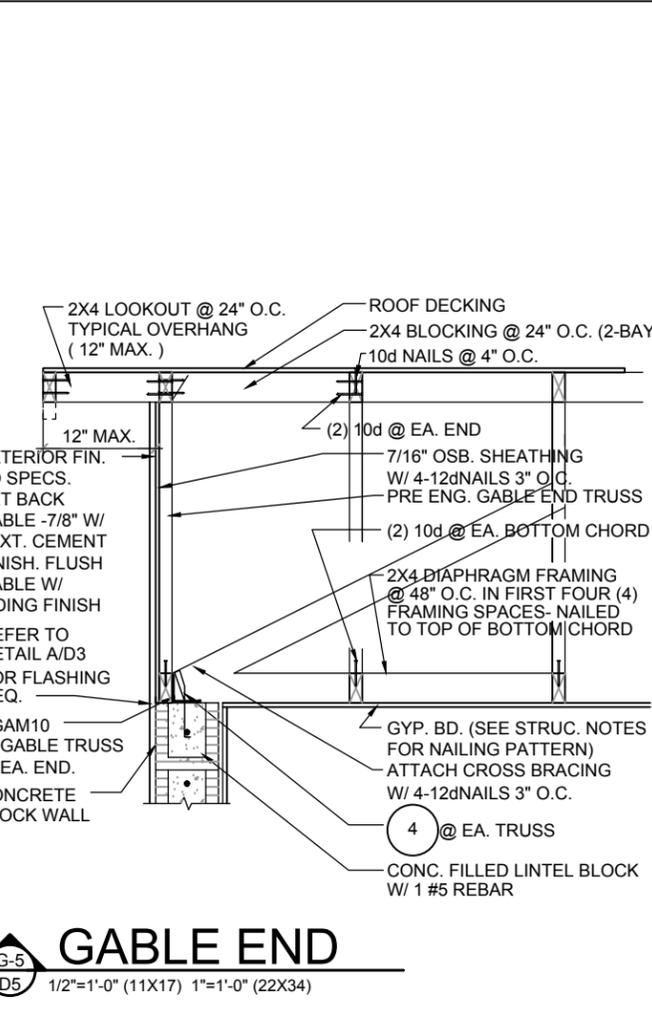

**G-5** **DETAIL**  
**D5** 1/2"=1'-0" (11X17) 1"=1'-0" (22X34)

THIS STRUCTURE IS DESIGNED IN ACCORDANCE WITH THE 8th EDITION, 2003 OF THE FLORIDA BUILDING CODE-RESIDENTIAL AND IS CERTIFIED AS SUCH.  
**LOT: 0000, COMMUNITY**  
**1860 SKY**  
**40' EXPLORATION SERIES**  
**REVISIONS**  

DELTA #	DATE
	09-11-25

**SCALE: AS NOTED**  
**DRAWN: MR**  
**SHEET: D5**

**HITEG**  
 THOMPSON ENGINEERING GROUP, INC.  
 A DIVISION OF PARK SQUARE ENTERPRISES, INC.  
 5200 Vineyard Road, Suite 200  
 Orlando, Florida 32811  
 Phone: (407) 529-3000  
 Fax: (407) 734-1790  
 www.hiteg.com

**Park Square HOMES**  
 STRUCTURAL DETAILS

REPRODUCTIONS, CHANGES OR ASSIGNMENTS ARE PROHIBITED.  
 PARK SQUARE HOMES RESERVES COPYRIGHT & OTHER RIGHTS RESTRICTING THESE DOCUMENTS TO THE ORIGINAL SITE OR PURPOSE FOR WHICH THEY WERE PREPARED.